



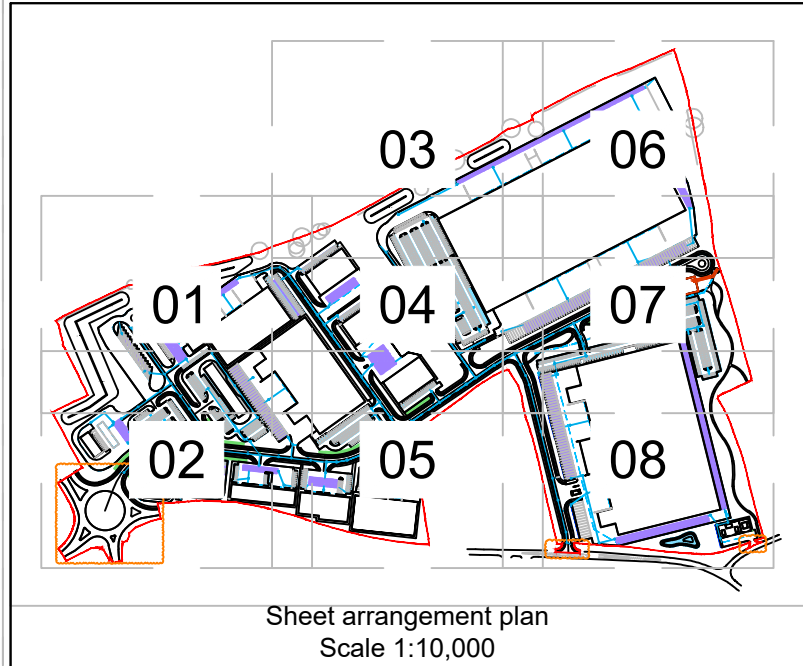

- | | | | | | |
|-----|------------|-----|---|-----|-----|
| P05 | 12.01.2024 | FJB | Updated to include Unit 02 substation. | WL | PJB |
| P04 | 06.11.2023 | FJB | Updated to the latest layout. Key update. | WL | PJB |
| P03 | 29.06.2023 | FJB | Drainage, key and notes update. | WL | PJB |
| P02 | 15.06.2023 | FJB | Drainage and red line update. | WL | PJB |
| P01 | 02.06.2023 | FJB | First issue. | WL | PJB |
| Rev | Date | By | Description | Chk | App |

PLANNING

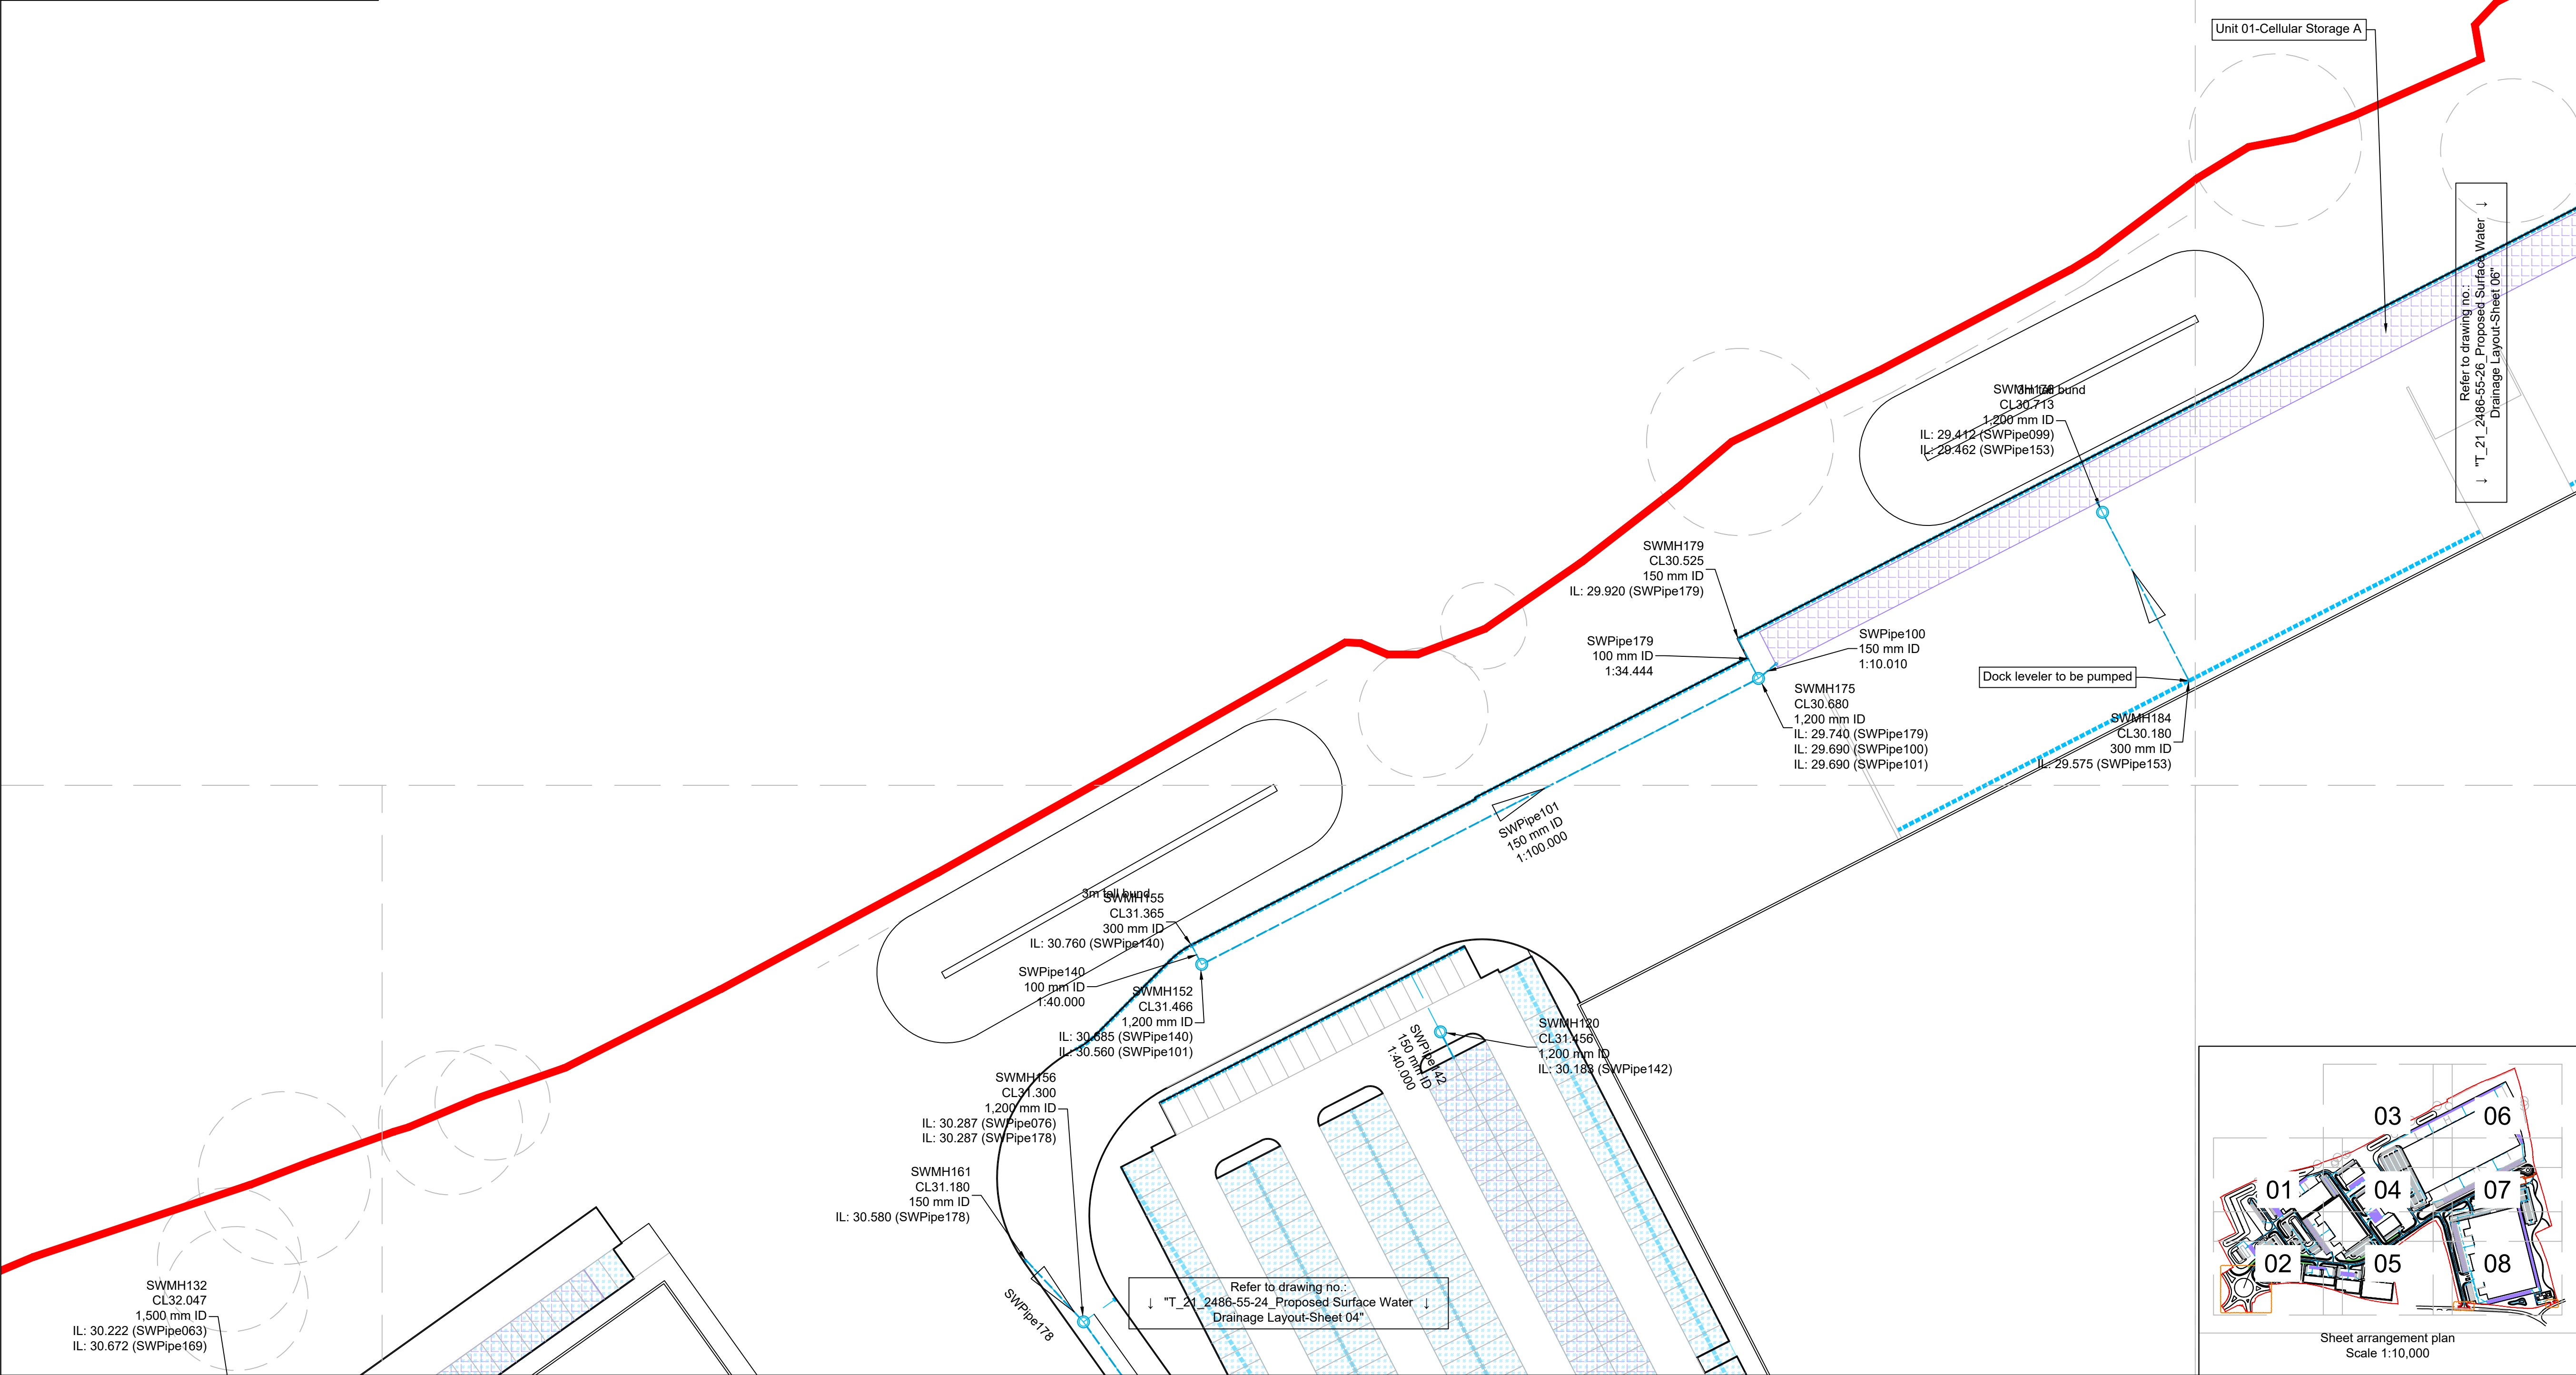

TIER CONSULT.
Richmond House,
Sandpiper Court,
Chester Business Park,
Chester | CH4 9QZ
T: 01244 684 900

Client
CBRE Ltd
One St Peters Square, 10th Floor,
Manchester, M2 3DE

Project
Bryn Lane, Wrexham,
Wrexham Industrial Estate, Phase 2

Title	Proposed Surface Water Drainage Layout-Sheet 03
-------	--

Scale 1:500@A1	Drawn F.J.BEDNARSKI	Revision P05
Date 02.06.2023	Checked W.N.LLOYD	

T 21 2486-55-23