
 


SITE LOCATION

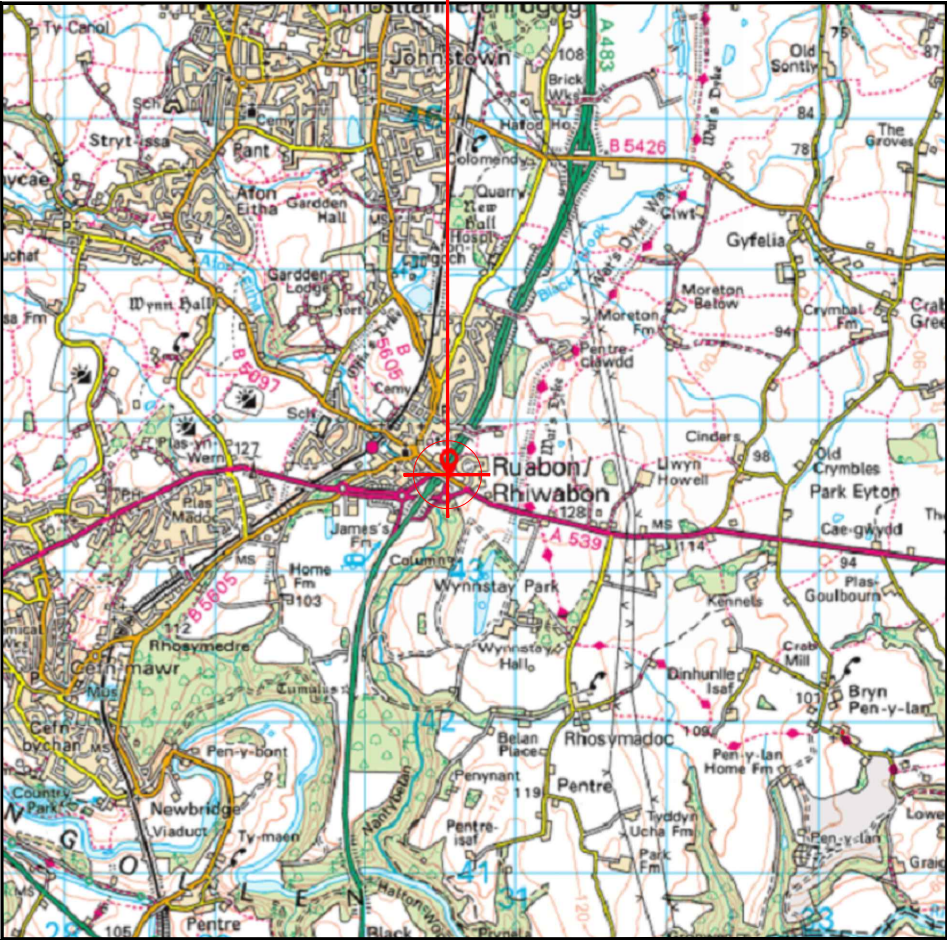


Reproduced by permission of Ordnance Survey on behalf of the Controller of Her Majesty's Stationery Office  
All rights reserved. © Crown Copyright licence no. 100022432

SITE AREA PLAN




SITE PHOTOGRAPH

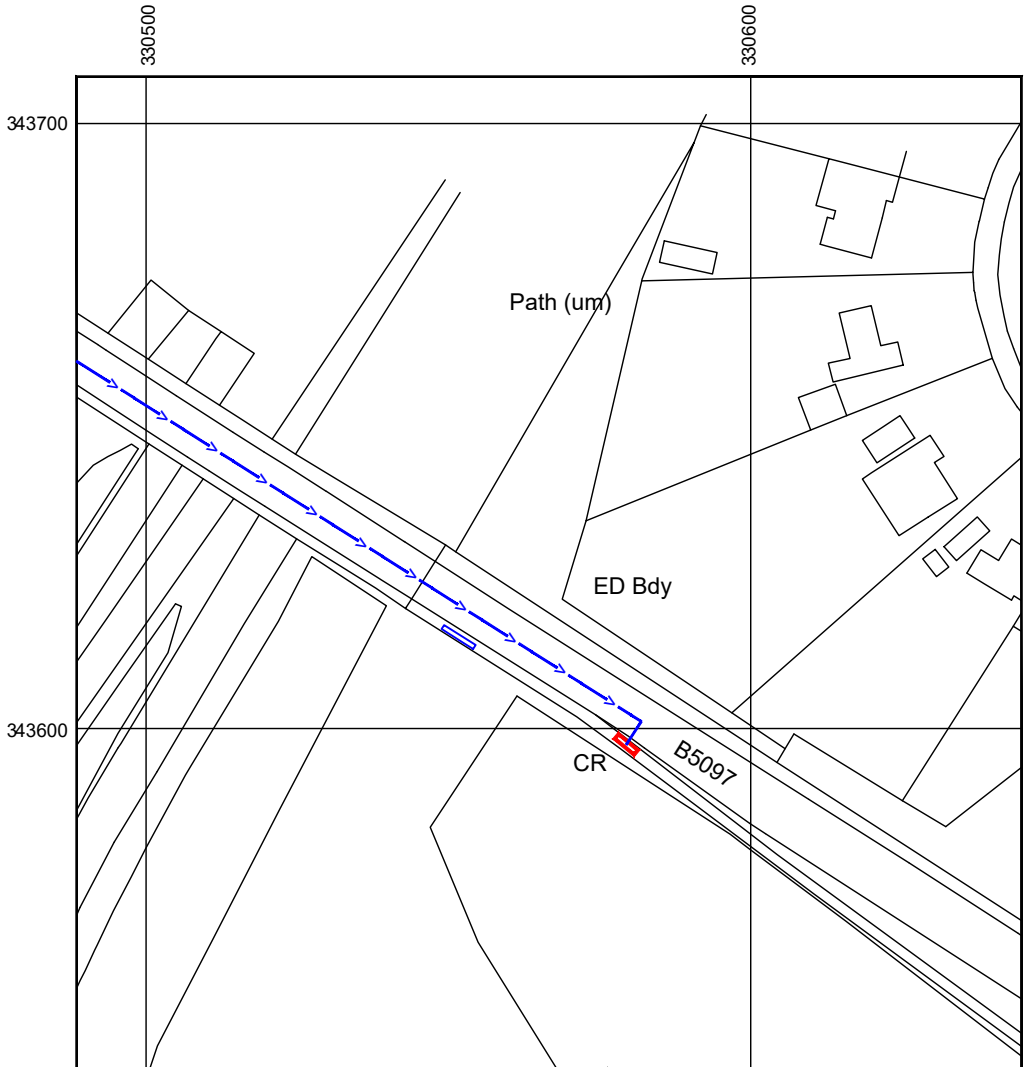

Reproduced by permission of Ordnance Survey on behalf of the Controller of Her Majesty's Stationery Office  
All rights reserved. © Crown Copyright licence no. 100022432

E : NGR UK E: 330558 N: 343612  
P : NGR UK E: 330577 N: 343600

 SITE LOCATION PLAN



GOOGLE MAPS QR CODE


GOOGLE MAPS - <https://goo.gl/maps/yiXveipuoVBDLoon6>

GOOGLE STREETVIEW - <https://goo.gl/maps/NByAoRoXu6z2fq3T9>

NOTES:

1. ALL DIMENSIONS IN MM UNLESS OTHERWISE NOTED.

DIRECTIONS TO SITE: HEAD SOUTHEAST TOWARD PONT ADAM/B5097 THEN TURN RIGHT ONTO PONT ADAM/B5097 AND THEN TURN RIGHT ONTO HIGH ST/B5605 AFTER THAT TURN LEFT ONTO PARK ST/B5097

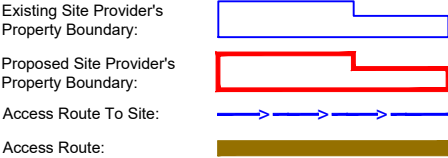

|           |                  |                                          |                   |        |
|-----------|------------------|------------------------------------------|-------------------|--------|
| Master:   | MBNL / EE / H3G: | Project:                                 | Purpose of Issue: | Issue: |
| M001      | H3G              | MBNL - 3UK BUY-IN                        | Planning          | A      |
| Date:     | 14/09/22         | Revision / Upgrade Description:          |                   |        |
| Drawn:    | M.P              | First Issue - Site nomination dated: TBC |                   |        |
| Checked:  | RAJ              |                                          |                   |        |
| Approved: | GJ               |                                          |                   |        |



Hutchison 3G UK Limited  
Star House, 20 Grenfell Road  
Maidenhead, SL6 1EH  
Tel: 01628 765 000  
Fax: 01628 765 001



Hatfield Business Park  
Hatfield  
Hertfordshire  
AL10 9BW  
Tel: 01707 315000  
Fax: 01707 319001



Mobile Broadband Network Limited  
Sixth Floor, Thames Tower, Station Road, Reading, RG1 1LX

Design Consultant & Principal Contractor:

 **WHP Telecoms**  
Unit 1 Maple Park,  
Low Fields Avenue, Leeds  
LS12 6HH  
Tel: 01133023550  
e-mail: [info@whptelecoms.com](mailto:info@whptelecoms.com)

|                    |                                                                                             |               |        |
|--------------------|---------------------------------------------------------------------------------------------|---------------|--------|
| Site Name:         | LP A539 VERGE                                                                               |               |        |
| Site ID:           | 1198104                                                                                     |               |        |
| Address:           | VERGE EAST OF CRASH BARRIER AND PLEASE DRIVE SLOWLY SIGN A539 RUABON WREXHAM CONWY LL14 6LE |               |        |
| Title:             | 002 SITE LOCATION PLAN                                                                      |               |        |
| Project:           | MBNL - 3UK BUY-IN                                                                           |               |        |
| Purpose of Issue:  | GENERAL ARRANGEMENT                                                                         |               |        |
| EE Cell ID:        | 11844                                                                                       | MBNL Cell ID: | WRX036 |
| 3UK Cell ID:       | LL0374                                                                                      |               |        |
| Master Drawing No: | 1198104_WRX036_11844_LL0374_M001                                                            |               |        |
| Issue:             | A                                                                                           |               |        |



| Asset Reference | Asset Description: | Asset Status: | Antenna / Dish / MHA / RRU / Equipment Access Description: | Asset Reference | Asset Description: | Asset Status: | Antenna / Dish / MHA / RRU / Equipment Access Description: | Asset Reference | Asset Description: | Asset Status: | Antenna / Dish / MHA / RRU / Equipment Access Description: |
|-----------------|--------------------|---------------|------------------------------------------------------------|-----------------|--------------------|---------------|------------------------------------------------------------|-----------------|--------------------|---------------|------------------------------------------------------------|
| A1-C1           | Antenna            | Proposed      | Cherry picker access                                       | CAB1-4          | Cabinet            | Proposed      | Unrestricted access                                        | AMPA1           | MHA                | Proposed      | Cherry picker access                                       |
| A2-C2           | Antenna            | Proposed      | Cherry picker access                                       | CAB5-6          | Cabinet            | Relocate      | Unrestricted access                                        | AMPB1           | MHA                | Proposed      | Cherry picker access                                       |
| EA1-EC1         | Antenna            | Remove        | Cherry picker access                                       | CAB7            | Cabinet            | Remove        | Unrestricted access                                        | AMPC1           | MHA                | Proposed      | Cherry picker access                                       |
| GPS1            | GPS                | Proposed      | Cherry picker access                                       |                 |                    |               |                                                            |                 |                    |               |                                                            |

NOTES:



1. ALL DIMENSIONS IN MM UNLESS OTHERWISE NOTED.

DEFINED ACCESS ROUTE DESCRIPTION FROM SITE ENTRANCE TO THE EQUIPMENT:

SHARED CONFIGURATION SITE

RF CONFIG

 
HS2

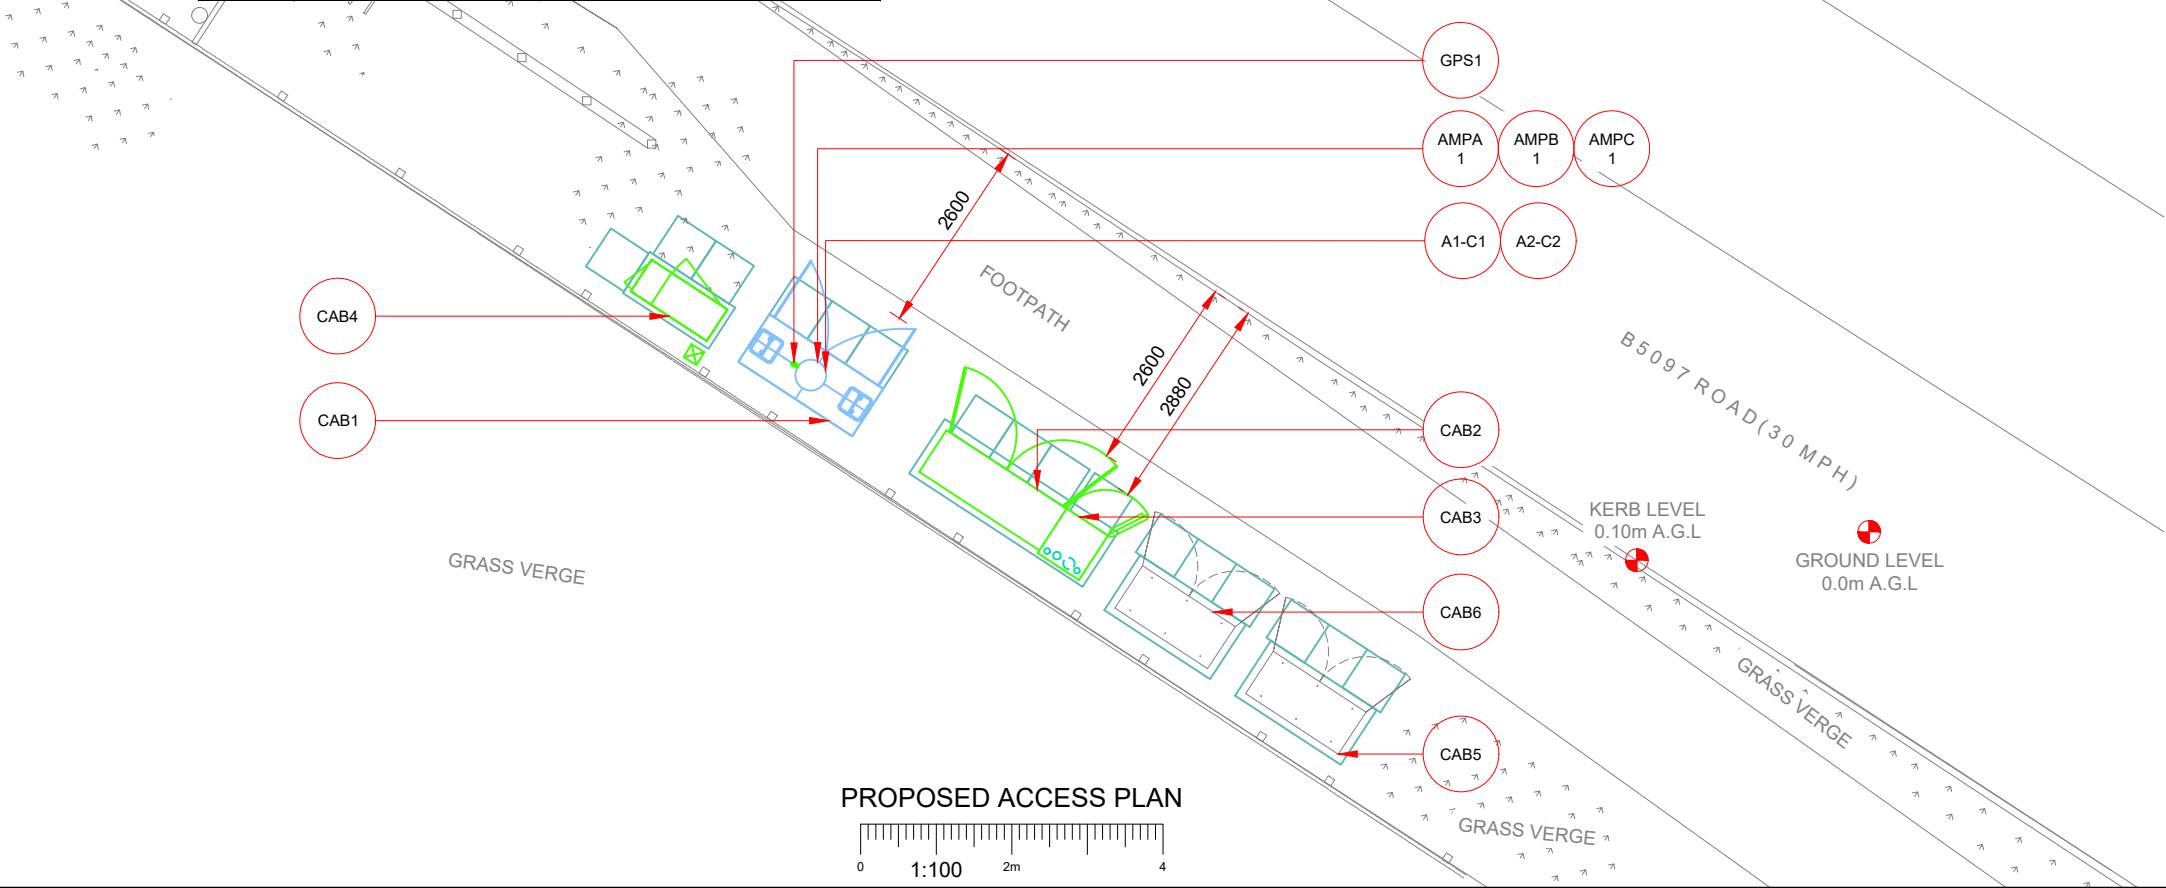

100mm

50mm

10mm

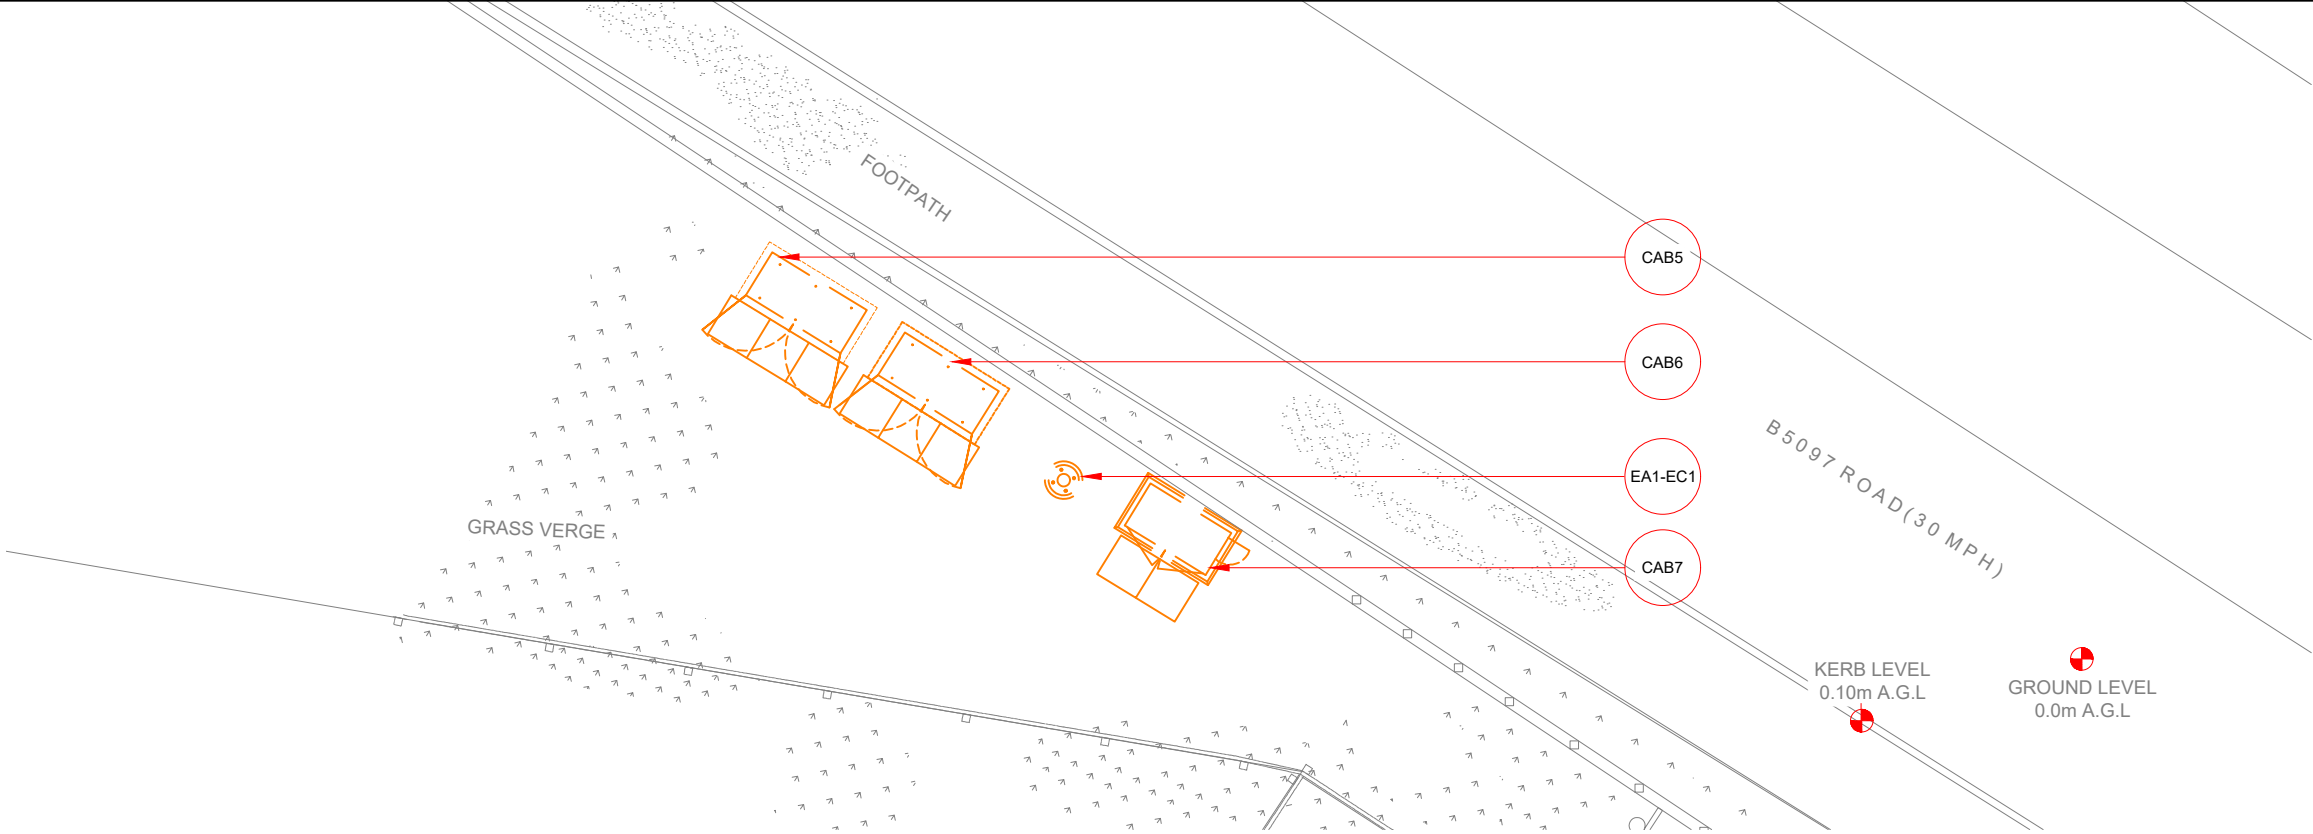

Master: M001

MBNL / EE / H3G: H3G

Project: MBNL - 3UK BUY-IN

Purpose of Issue: Planning

Issue: A

Date: 14/09/22

Drawn: M.P

Checked: RAJ

Approved: GJ

Revision / Upgrade Description: First Issue - Site nomination dated: TBC

Hutchison 3G UK Limited  
Star House, 20 Grenfell Road  
Maidenhead, SL6 1EH  
Tel: 01628 765 000  
Fax: 01628 765 001  
  
H3G Base Station Information line:  
0845 6043000  
Available 8am-8pm Monday to Friday

Hatfield Business Park  
Hatfield  
Hertfordshire  
AL10 9BW  
  
Tel: 01707 315000  
Fax: 01707 319001

Mobile Broadband Network Limited  
Sixth Floor, Thames Tower, Station Road, Reading, RG1 1LX

Design Consultant & Principal Contractor:

**WHP Telecoms**  
Unit 1 Maple Park,  
Low Fields Avenue, Leeds  
LS12 6HH  
  
Tel: 01133023550  
e-mail: info@whptelecoms.com

Site Name: LP A539 VERGE

Site ID: 1198104

Address: VERGE EAST OF CRASH BARRIER AND PLEASE DRIVE SLOWLY SIGN A539 RUABON WREXHAM CONWY LL14 6LE

Title: 003 ACCESS PLAN

Project: MBNL - 3UK BUY-IN

Purpose of Issue: GENERAL ARRANGEMENT


EE Cell ID: 11844

MBNL Cell ID: WRX036


3UK Cell ID: LL0374

Master Drawing No: 1198104\_WRX036\_11844\_LL0374\_M001

Issue: A

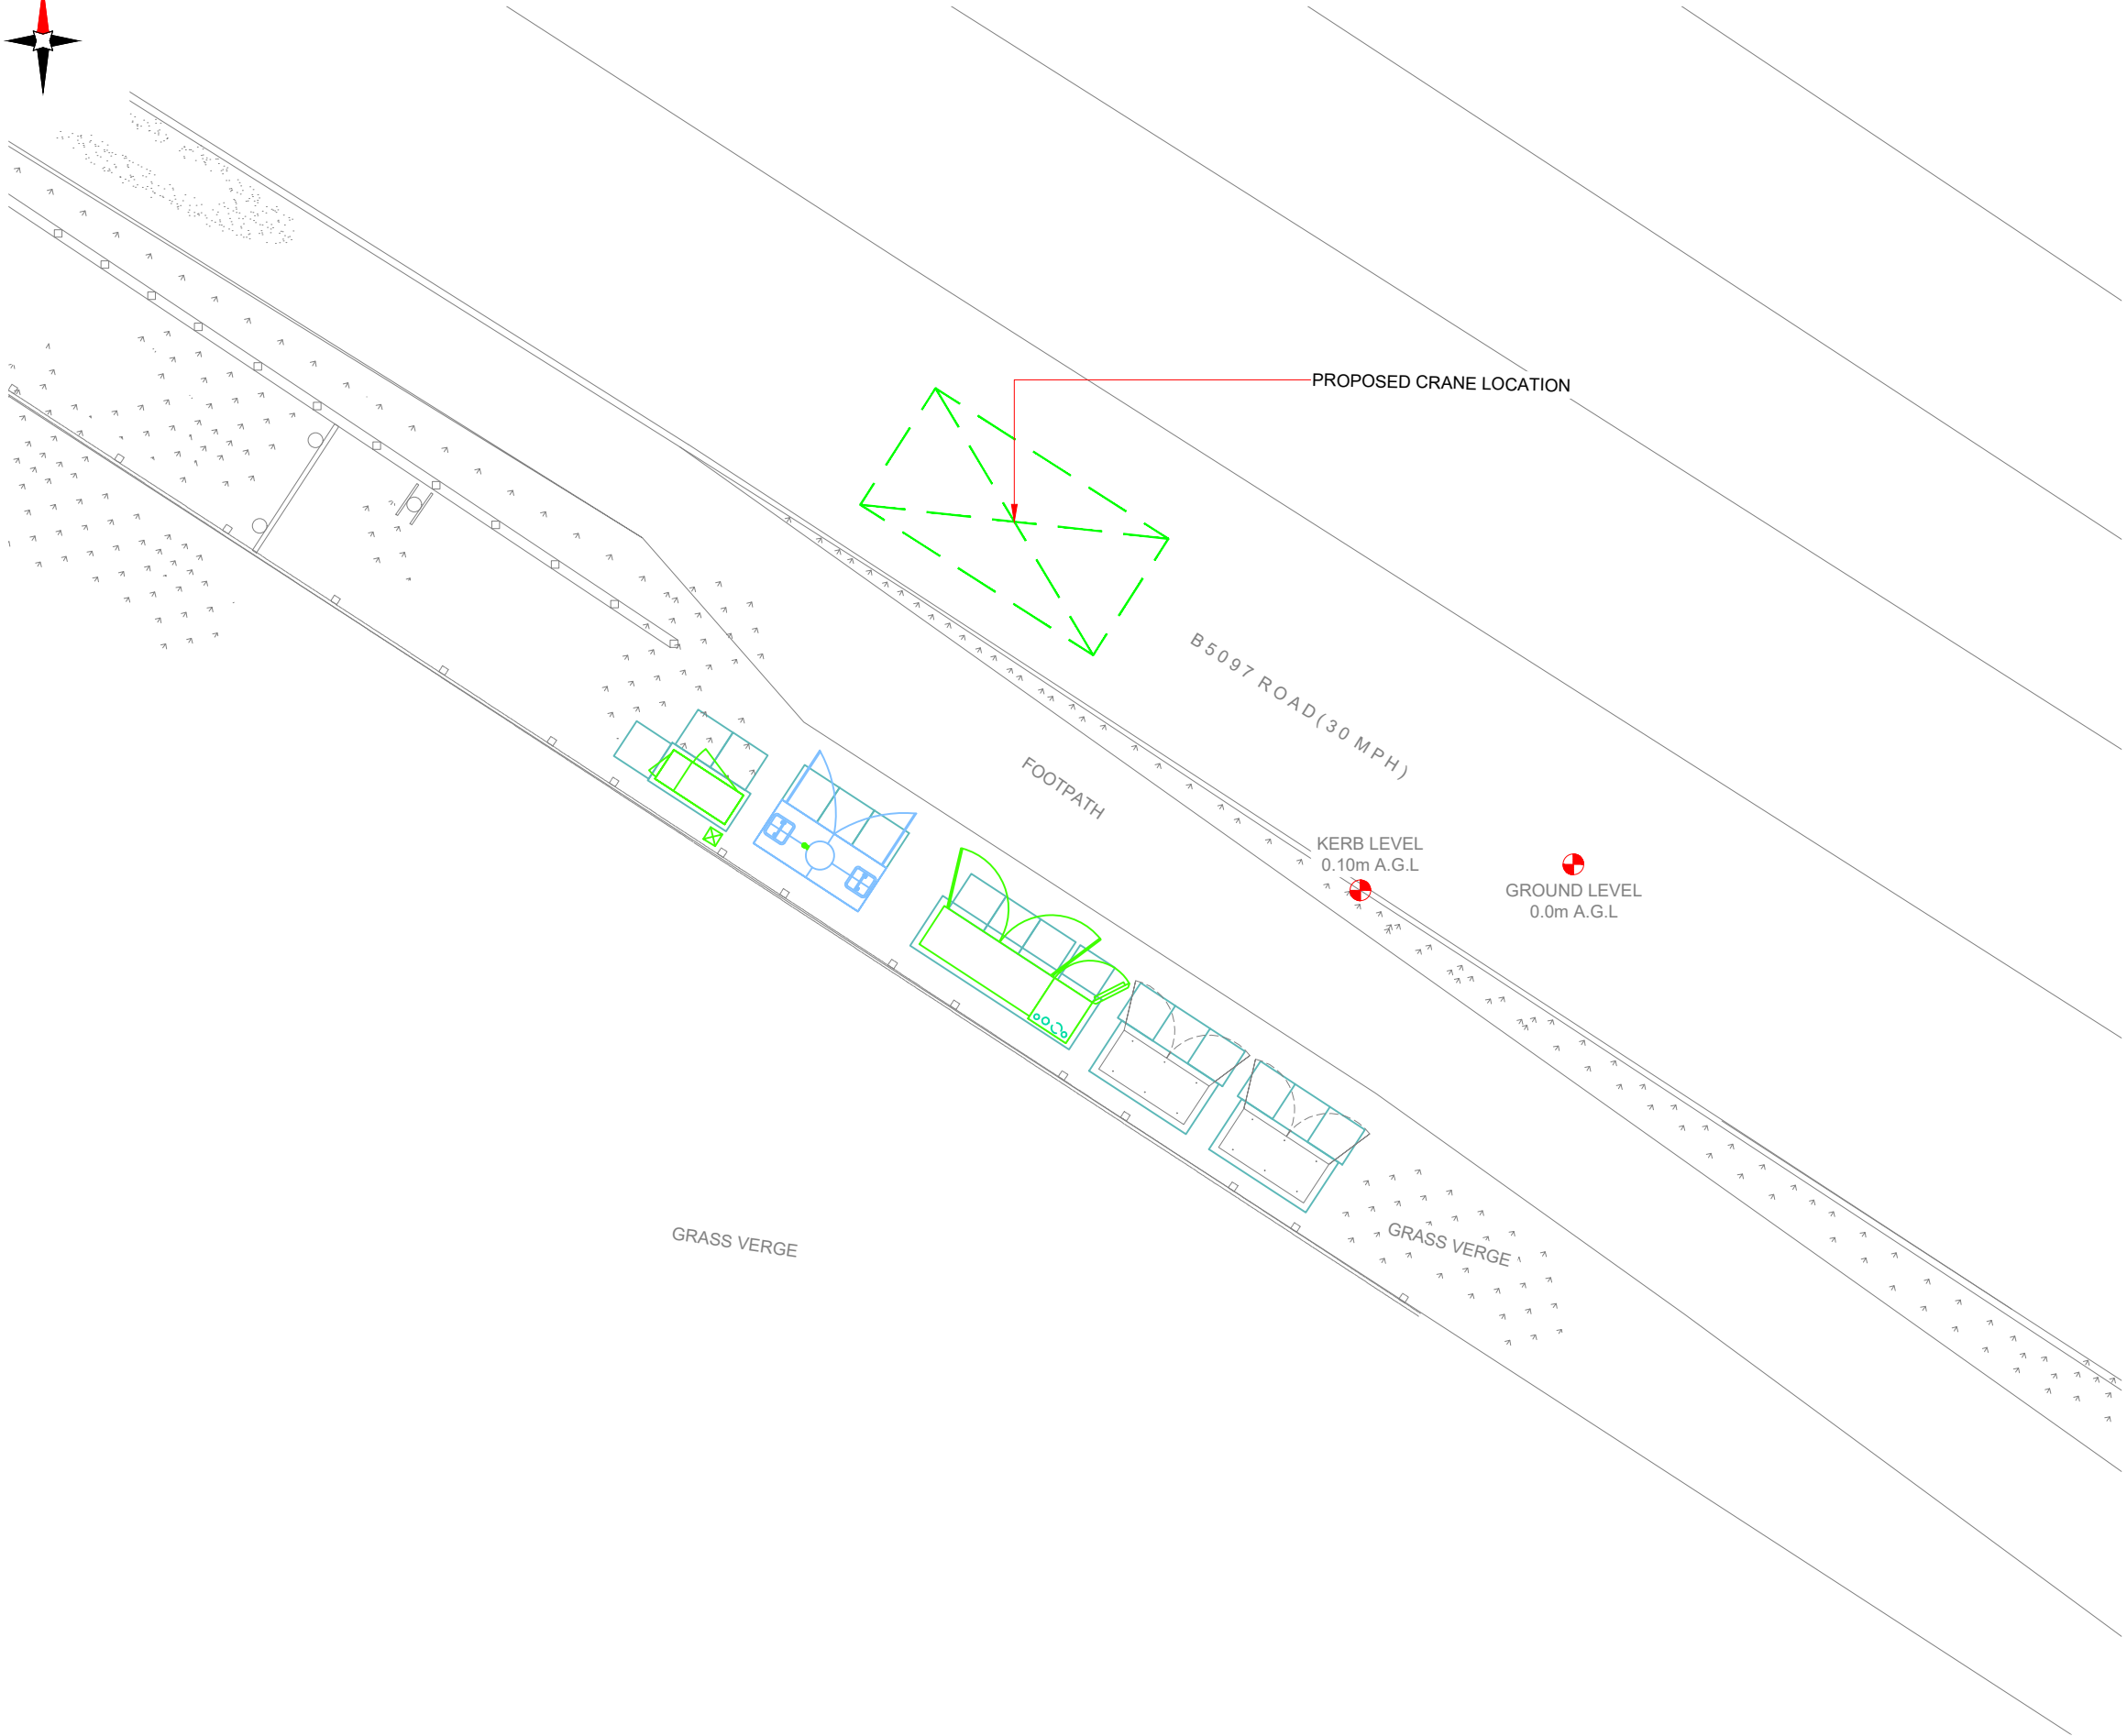

CHERRY PICKER / CRANE LOCATION PLAN

 

NOTES:  
1. ALL DIMENSIONS IN MM UNLESS OTHERWISE NOTED.  
  
PROPOSED CRANE OR CHERRY PICKER LOCATION:

|           |                  |                                          |                   |        |
|-----------|------------------|------------------------------------------|-------------------|--------|
| Master:   | MBNL / EE / H3G: | Project:                                 | Purpose of Issue: | Issue: |
| M001      | H3G              | MBNL - 3UK BUY-IN                        | Planning          | A      |
| Date:     | 14/09/22         | Revision / Upgrade Description:          |                   |        |
| Drawn:    | M.P              | First Issue - Site nomination dated: TBC |                   |        |
| Checked:  | RAJ              |                                          |                   |        |
| Approved: | GJ               |                                          |                   |        |

Hutchison 3G UK Limited  
Star House, 20 Grenfell Road  
Maidenhead, SL6 1EH  
Tel: 01628 765 000  
Fax: 01628 765 001  
  
H3G Base Station Information line:  
0845 6043000  
Available 8am-8pm Monday to Friday

Hatfield Business Park  
Hatfield  
Hertfordshire  
AL10 9BW  
  
Tel: 01707 315000  
Fax: 01707 319001

Mobile Broadband Network Limited  
Sixth Floor, Thames Tower, Station Road, Reading, RG1 1LX

Design Consultant & Principal Contractor:  

**WHP Telecoms**  
Unit 1 Maple Park,  
Low Fields Avenue, Leeds  
LS12 6HH  
  
Tel: 01133023550  
e-mail: info@whptelecoms.com

Site Name:  
**LP A539 VERGE**

Site ID:  
**1198104**

Address:  
**VERGE EAST OF CRASH BARRIER AND  
PLEASE DRIVE SLOWLY SIGN A539  
RUABON WREXHAM CONWY  
LL14 6LE**

Title:  
**005 CHERRY PICKER & CRANE LOCATION**

Project:  
**MBNL - 3UK BUY-IN**


Purpose of Issue:  
**GENERAL ARRANGEMENT**

|                             |                                |                               |
|-----------------------------|--------------------------------|-------------------------------|
| EE Cell ID:<br><b>11844</b> | MBNL Cell ID:<br><b>WRX036</b> | 3UK Cell ID:<br><b>LL0374</b> |
|-----------------------------|--------------------------------|-------------------------------|


|                                                               |                    |
|---------------------------------------------------------------|--------------------|
| Master Drawing No:<br><b>1198104_WRX036_11844_LL0374_M001</b> | Issue:<br><b>A</b> |
|---------------------------------------------------------------|--------------------|



## SERVICES PLAN

 

|                                  |        |
|----------------------------------|--------|
| Master Drawing No:               | Issue: |
| 1198104_WRX036_11844_LL0374_M001 | A      |

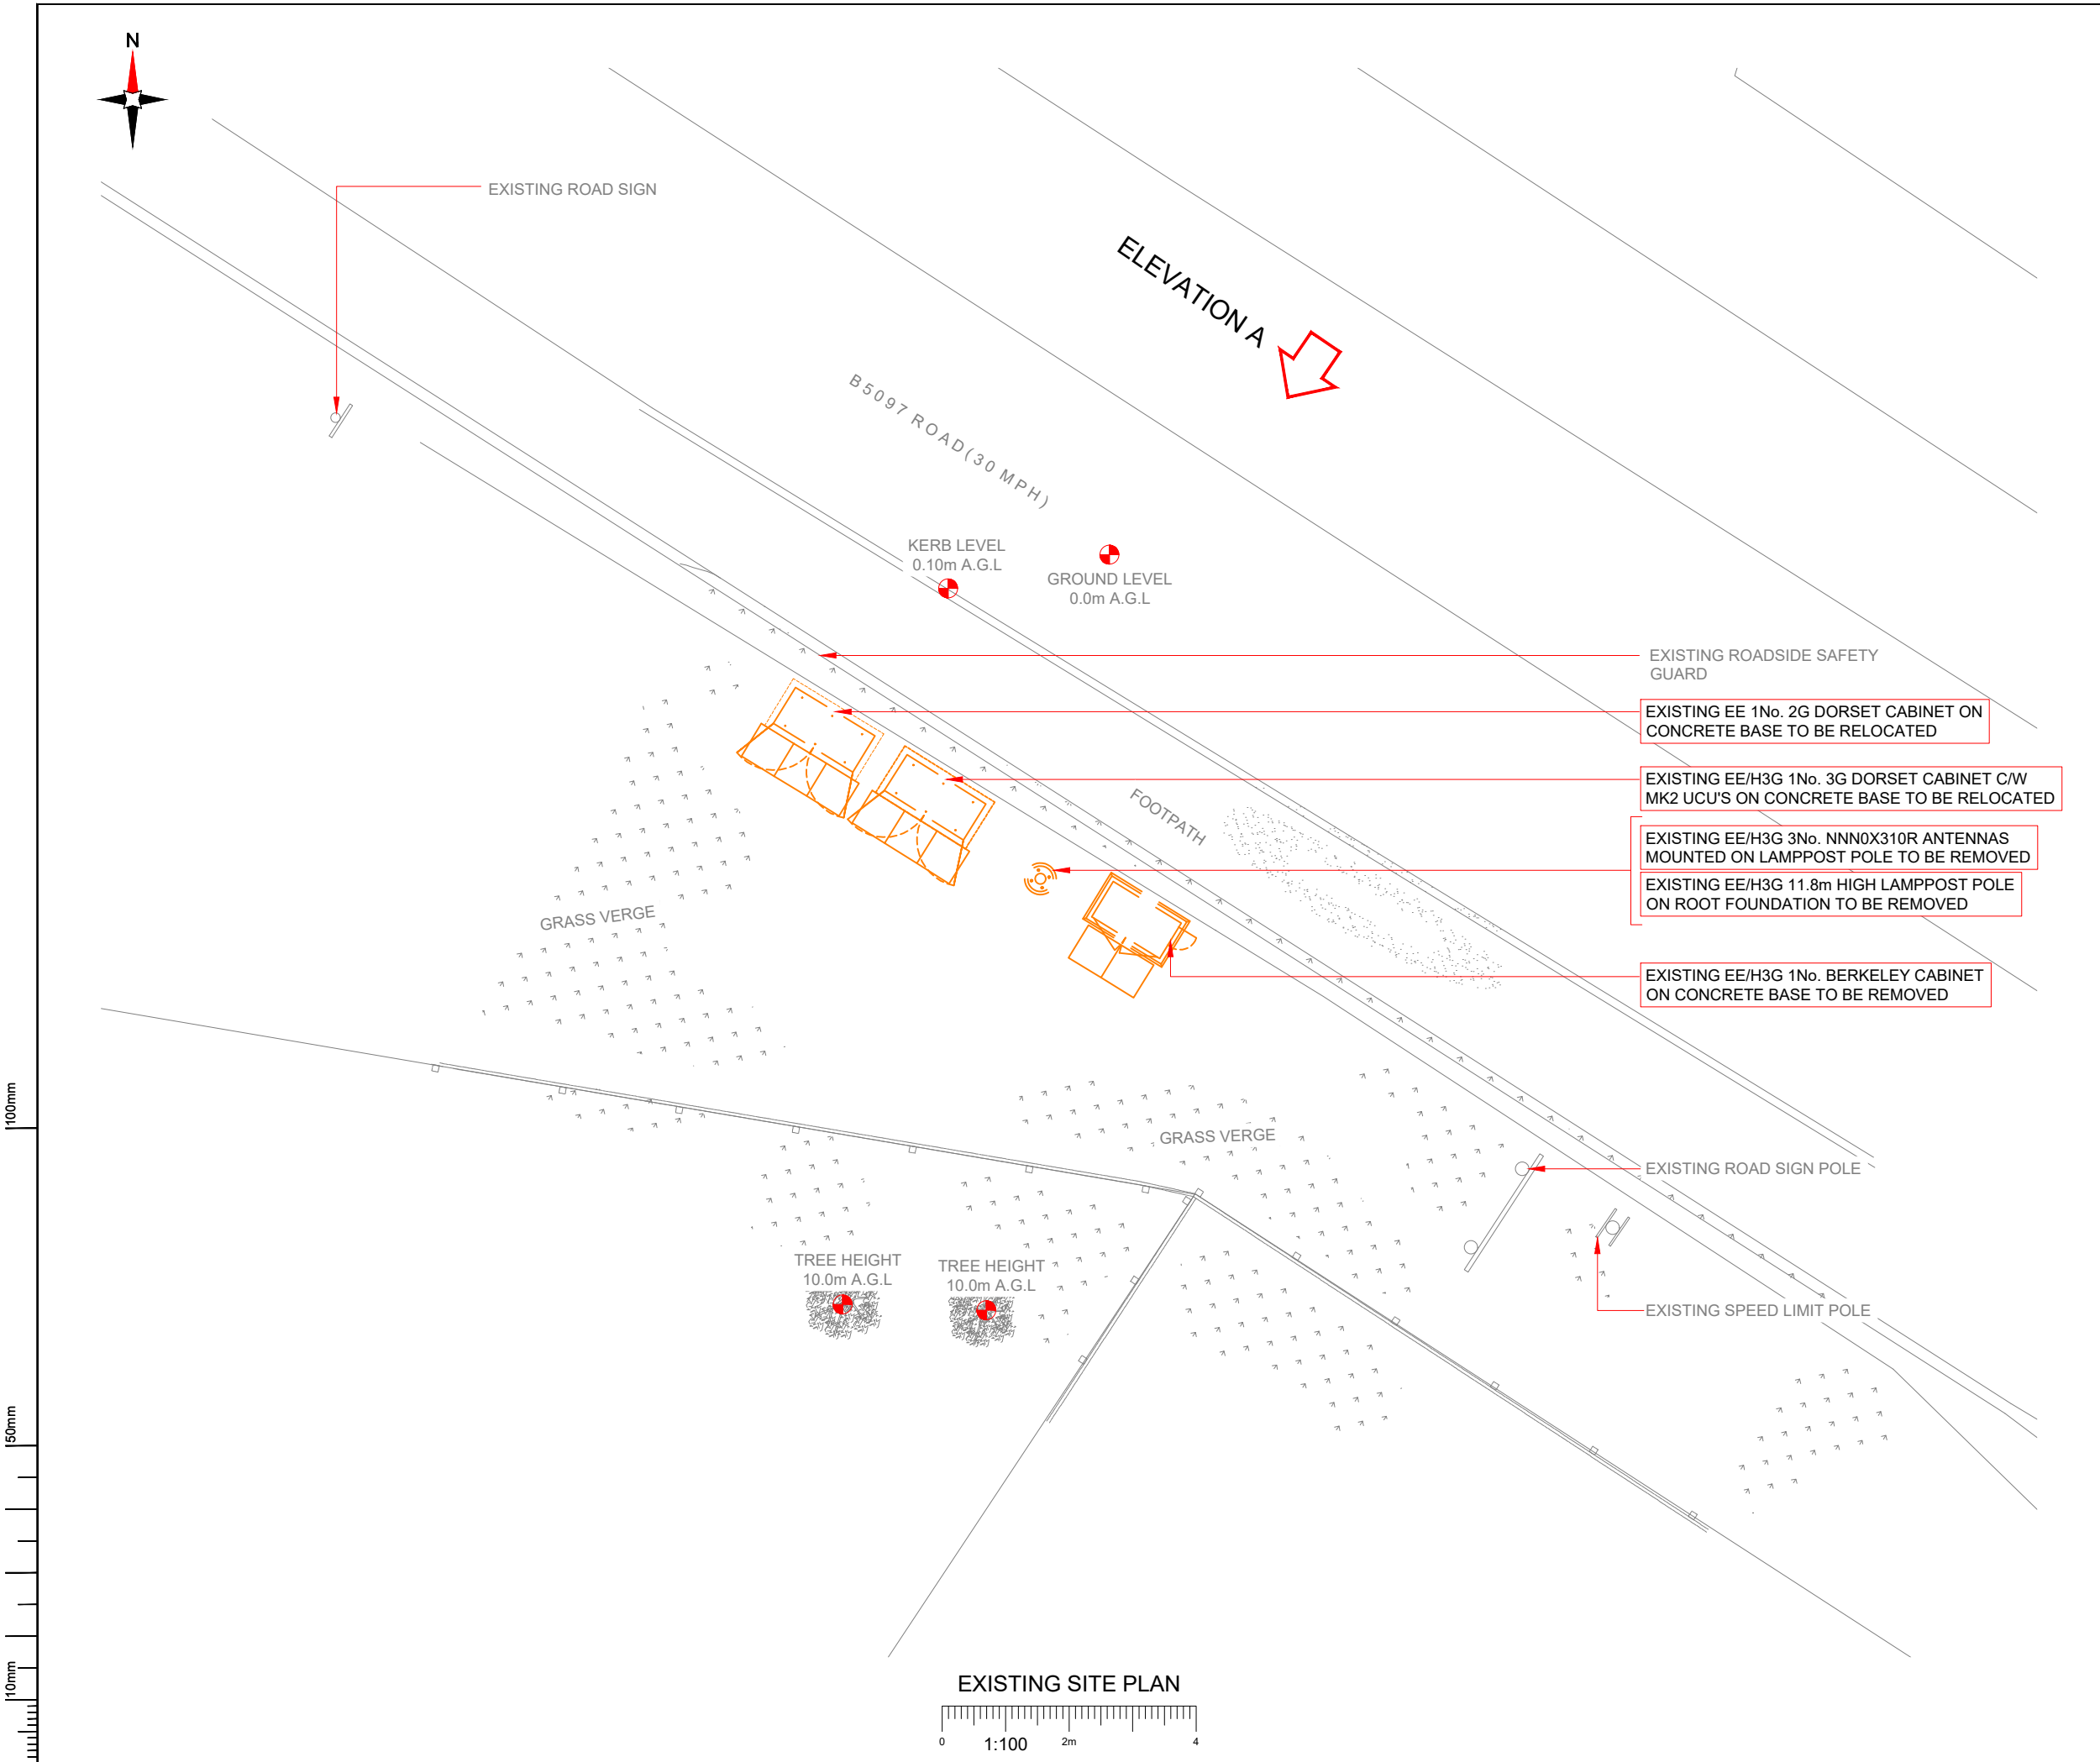

NOTES:  
1. ALL DIMENSIONS IN MM UNLESS OTHERWISE NOTED.

|           |                  |                                          |                   |        |
|-----------|------------------|------------------------------------------|-------------------|--------|
| Master:   | MBNL / EE / H3G: | Project:                                 | Purpose of Issue: | Issue: |
| M001      | H3G              | MBNL - 3UK BUY-IN                        | Planning          | A      |
| Date:     | 14/09/22         | Revision / Upgrade Description:          |                   |        |
| Drawn:    | M.P              | First Issue - Site nomination dated: TBC |                   |        |
| Checked:  | RAJ              |                                          |                   |        |
| Approved: | GJ               |                                          |                   |        |

Hutchison 3G UK Limited  
Star House, 20 Grenfell Road  
Maidenhead, SL6 1EH  
Tel: 01628 765 000  
Fax: 01628 765 001  
  
H3G Base Station Information line:  
0845 6043000  
Available 8am-8pm Monday to Friday

Hatfield Business Park  
Hatfield  
Hertfordshire  
AL10 9BW  
  
Tel: 01707 315000  
Fax: 01707 319001

Mobile Broadband Network Limited  
Sixth Floor, Thames Tower, Station Road, Reading, RG1 1LX

Design Consultant & Principal Contractor:  

**WHP Telecoms**  
Unit 1 Maple Park,  
Low Fields Avenue, Leeds  
LS12 6HH  
  
Tel: 01133023550  
e-mail: info@whptelecoms.com

Site Name:  
LP A539 VERGE

Site ID:  
1198104

Address:  
VERGE EAST OF CRASH BARRIER AND  
PLEASE DRIVE SLOWLY SIGN A539  
RUABON WREXHAM CONWY  
LL14 6LE


Title:  
100 EXISTING SITE PLAN

Project:  
MBNL - 3UK BUY-IN

Purpose of Issue:  
GENERAL ARRANGEMENT

|                      |                         |                        |
|----------------------|-------------------------|------------------------|
| EE Cell ID:<br>11844 | MBNL Cell ID:<br>WRX036 | 3UK Cell ID:<br>LL0374 |
|----------------------|-------------------------|------------------------|

|                                                        |             |
|--------------------------------------------------------|-------------|
| Master Drawing No:<br>1198104_WRX036_11844_LL0374_M001 | Issue:<br>A |
|--------------------------------------------------------|-------------|

 

1. ALL DIMENSIONS IN MM UNLESS OTHERWISE NOTED.

|                                                                                       |                                                                                                                                                                                                                                                                                                              |                                                                                       |                                                                                                                                                                     |
|---------------------------------------------------------------------------------------|--------------------------------------------------------------------------------------------------------------------------------------------------------------------------------------------------------------------------------------------------------------------------------------------------------------|---------------------------------------------------------------------------------------|---------------------------------------------------------------------------------------------------------------------------------------------------------------------|
|  | <p><b>Hutchison 3G UK Limited</b><br/>         Star House, 20 Grenville Road<br/>         Maidenhead, SL6 1EH<br/>         Tel: 01628 765 000<br/>         Fax: 01628 765 001</p> <hr/> <p>H3G Base Station Information line:<br/>         0845 6043000<br/>         Available from 8pm Monday to Friday</p> |  | <p><b>Hatfield Business Park</b><br/>         Hatfield<br/>         Hertfordshire<br/>         AL10 9BW</p> <p>Tel: 01707 315000<br/>         Fax: 01707 319001</p> |
|---------------------------------------------------------------------------------------|--------------------------------------------------------------------------------------------------------------------------------------------------------------------------------------------------------------------------------------------------------------------------------------------------------------|---------------------------------------------------------------------------------------|---------------------------------------------------------------------------------------------------------------------------------------------------------------------|

Design Consultant & Principal Contractor:



**WHP Telecoms**

Unit 1 Maple Park,  
Low Fields Avenue, Leeds  
LS12 6HH

Tel: 01133023550  
e-mail: [info@whptelecoms.com](mailto:info@whptelecoms.com)


Site ID: 1198104

Title: 150 EXISTING SITE ELEVATION

Purpose of Issue:

GENERAL ARRANGEMENT

|                                                        |             |
|--------------------------------------------------------|-------------|
| Master Drawing No:<br>1198104_WRX036_11844_LL0374_M001 | Issue:<br>A |
|--------------------------------------------------------|-------------|

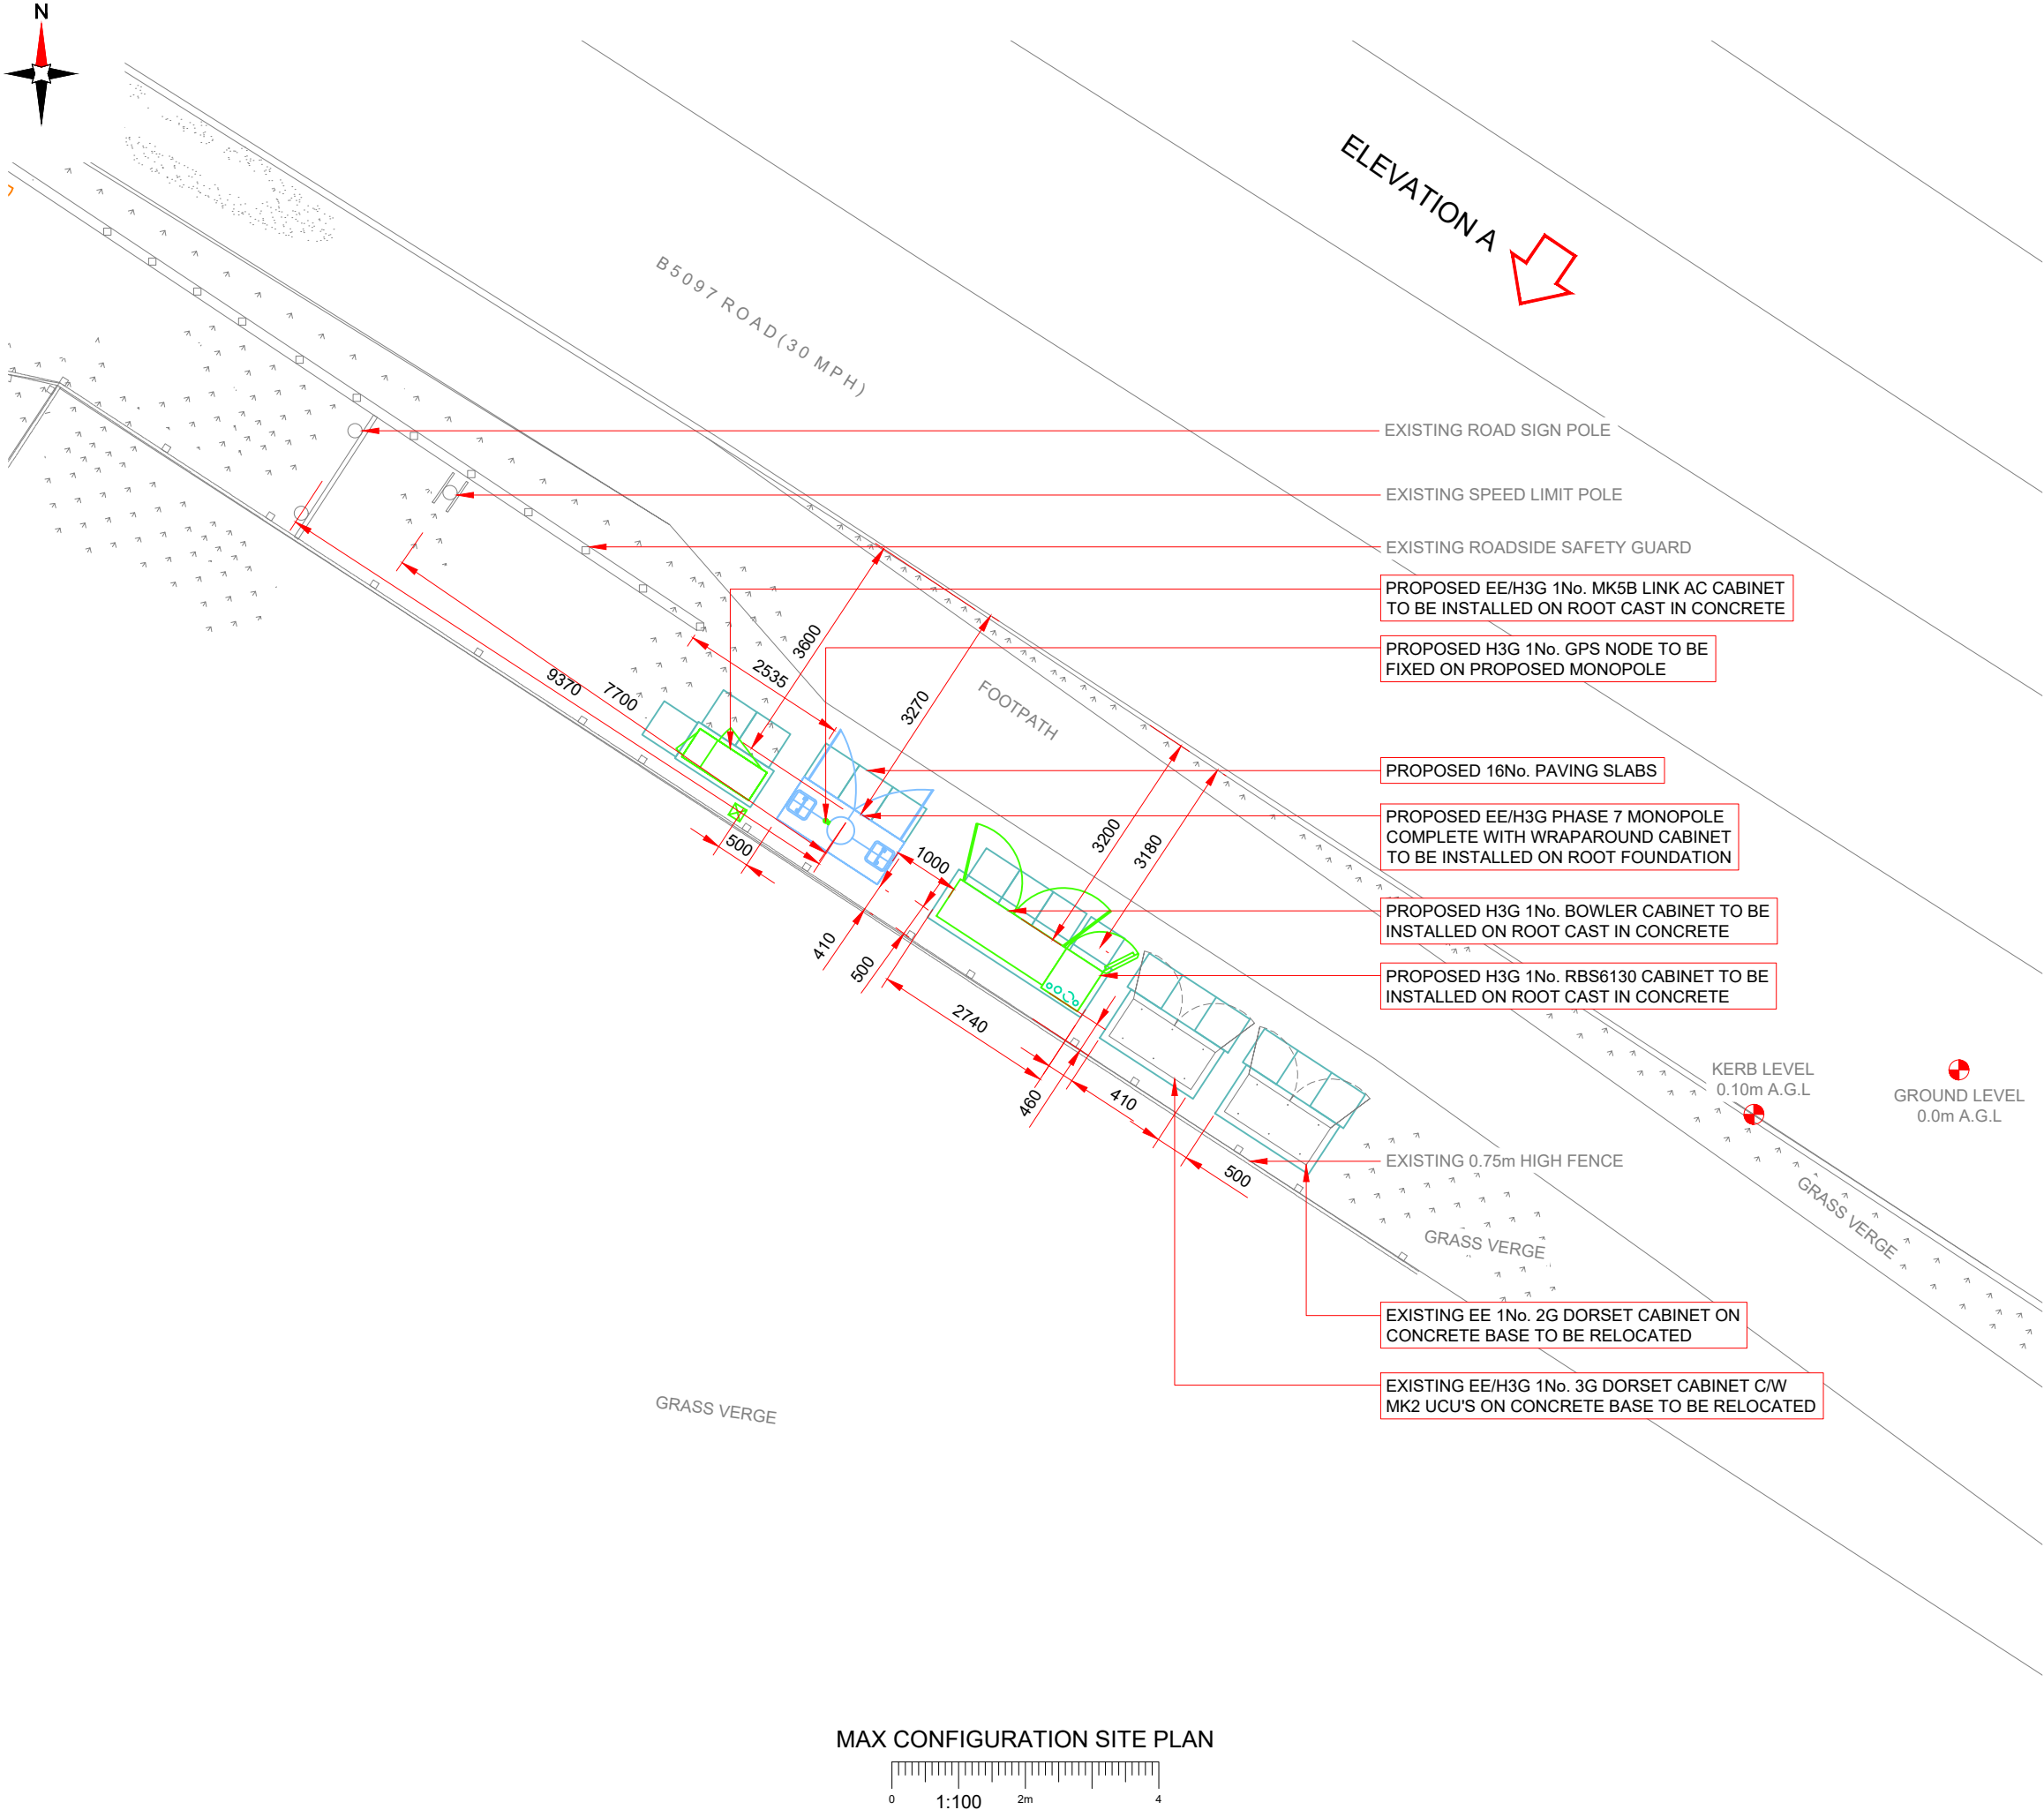

MAX CONFIGURATION SITE PLAN

0 1:100 2m 4

NOTES:

1. ALL DIMENSIONS IN MM UNLESS OTHERWISE NOTED.

EXISTING SW TO BE REMOVED

PROPOSED POLE LOCATION IS 18.3m FROM EXISTING POLE LOCATION

EXISTING NGR UK E: 330558 N: 343612  
PROPOSED NGR UK E: 330577 N: 343600

SHARED CONFIGURATION SITE

RF CONFIG

HS2

|           |                  |                                          |                   |        |
|-----------|------------------|------------------------------------------|-------------------|--------|
| Master:   | MBNL / EE / H3G: | Project:                                 | Purpose of Issue: | Issue: |
| M001      | H3G              | MBNL - 3UK BUY-IN                        | Planning          | A      |
| Date:     | 14/09/22         | Revision / Upgrade Description:          |                   |        |
| Drawn:    | M.P              | First Issue - Site nomination dated: TBC |                   |        |
| Checked:  | RAJ              |                                          |                   |        |
| Approved: | GJ               |                                          |                   |        |

Hutchison 3G UK Limited  
Star House, 20 Grenfell Road  
Maidenhead, SL6 1EH  
Tel: 01628 765 000  
Fax: 01628 765 001  
  
H3G Base Station Information line:  
0845 6043000  
Available 8am-8pm Monday to Friday

Hatfield Business Park  
Hatfield  
Hertfordshire  
AL10 9BW  
  
Tel: 01707 315000  
Fax: 01707 319001

Mobile Broadband Network Limited  
Sixth Floor, Thames Tower, Station Road, Reading, RG1 1LX

Design Consultant & Principal Contractor:

WHP Telecoms  
Unit 1 Maple Park,  
Low Fields Avenue, Leeds  
LS12 6HH  
  
Tel: 01133023550  
e-mail: info@whptelecoms.com

Site Name:

LP A539 VERGE

Site ID:

1198104

Address:

VERGE EAST OF CRASH BARRIER AND  
PLEASE DRIVE SLOWLY SIGN A539  
RUABON WREXHAM CONWY  
LL14 6LE

Title:

215 MAX CONFIGURATION SITE PLAN

Project:

MBNL - 3UK BUY-IN

Purpose of Issue:

GENERAL ARRANGEMENT

|             |               |              |
|-------------|---------------|--------------|
| EE Cell ID: | MBNL Cell ID: | 3UK Cell ID: |
| 11844       | WRX036        | LL0374       |

Master Drawing No:

1198104\_WRX036\_11844\_LL0374\_M001


Issue:

A

100mm

50mm

10mm

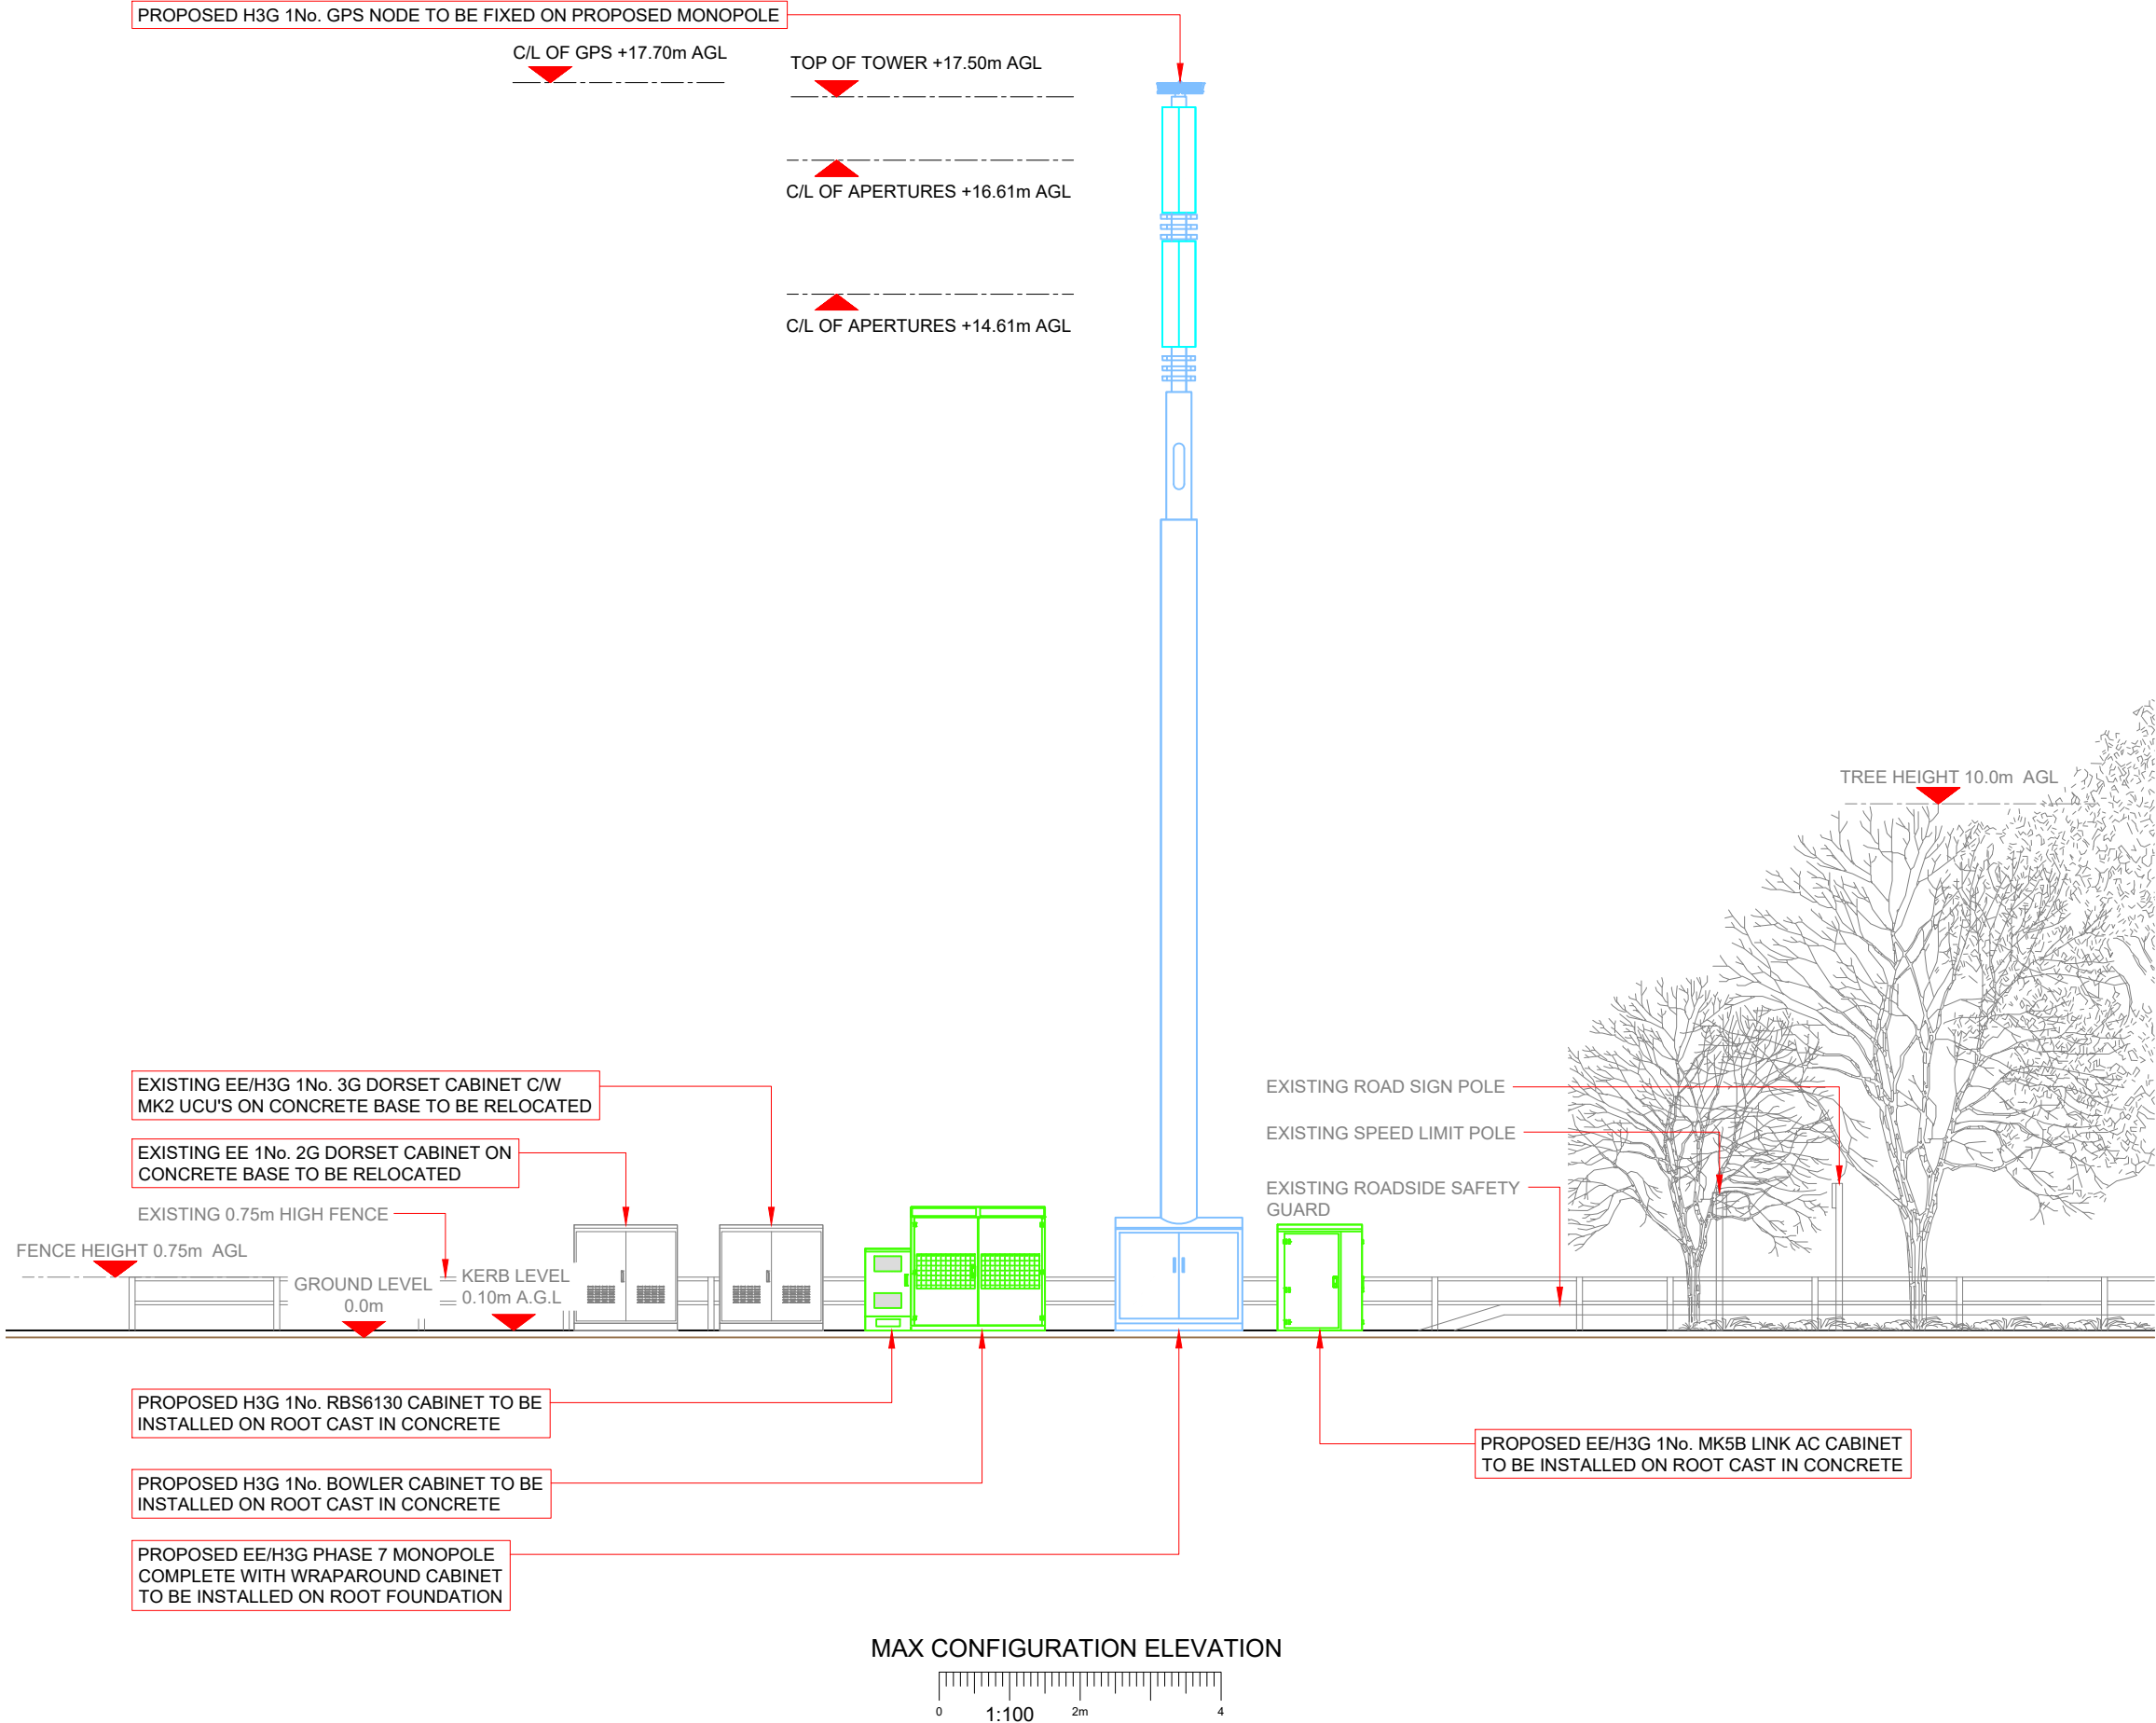

NOTES:  
1. ALL DIMENSIONS IN MM UNLESS OTHERWISE NOTED.  

EXISTING SW TO BE REMOVED

PROPOSED POLE LOCATION IS 18.3m FROM EXISTING POLE LOCATION

EXISTING NGR UK E: 330558 N: 343612  
PROPOSED NGR UK E: 330577 N: 343600

SHARED CONFIGURATION SITE

RF CONFIG

HS2

|           |                  |                                          |                   |        |
|-----------|------------------|------------------------------------------|-------------------|--------|
| Master:   | MBNL / EE / H3G: | Project:                                 | Purpose of Issue: | Issue: |
| M001      | H3G              | MBNL - 3UK BUY-IN                        | Planning          | A      |
| Date:     | 14/09/22         | Revision / Upgrade Description:          |                   |        |
| Drawn:    | M.P              | First Issue - Site nomination dated: TBC |                   |        |
| Checked:  | RAJ              |                                          |                   |        |
| Approved: | GJ               |                                          |                   |        |

Hutchison 3G UK Limited  
Star House, 20 Grenfell Road  
Maidenhead, SL6 1EH  
Tel: 01628 765 000  
Fax: 01628 765 001  
  
H3G Base Station Information line:  
0845 6043000  
Available 8am-8pm Monday to Friday

Hatfield Business Park  
Hatfield  
Hertfordshire  
AL10 9BW  
  
Tel: 01707 315000  
Fax: 01707 319001

Mobile Broadband Network Limited  
Sixth Floor, Thames Tower, Station Road, Reading, RG1 1LX

Design Consultant & Principal Contractor:  

WHP Telecoms  
Unit 1 Maple Park,  
Low Fields Avenue, Leeds  
LS12 6HH  
  
Tel: 01133023550  
e-mail: info@whptelecoms.com

Site Name:  
LP A539 VERGE

Site ID:  
1198104

Address:  
VERGE EAST OF CRASH BARRIER AND  
PLEASE DRIVE SLOWLY SIGN A539  
RUABON WREXHAM CONWY  
LL14 6LE

Title:  
265 MAX CONFIGURATION ELEVATION

Project:  
MBNL - 3UK BUY-IN

Purpose of Issue:  
GENERAL ARRANGEMENT

|                      |                         |                        |
|----------------------|-------------------------|------------------------|
| EE Cell ID:<br>11844 | MBNL Cell ID:<br>WRX036 | 3UK Cell ID:<br>LL0374 |
|----------------------|-------------------------|------------------------|

Master Drawing No:  
1198104\_WRX036\_11844\_LL0374\_M001

Issue:  
A