


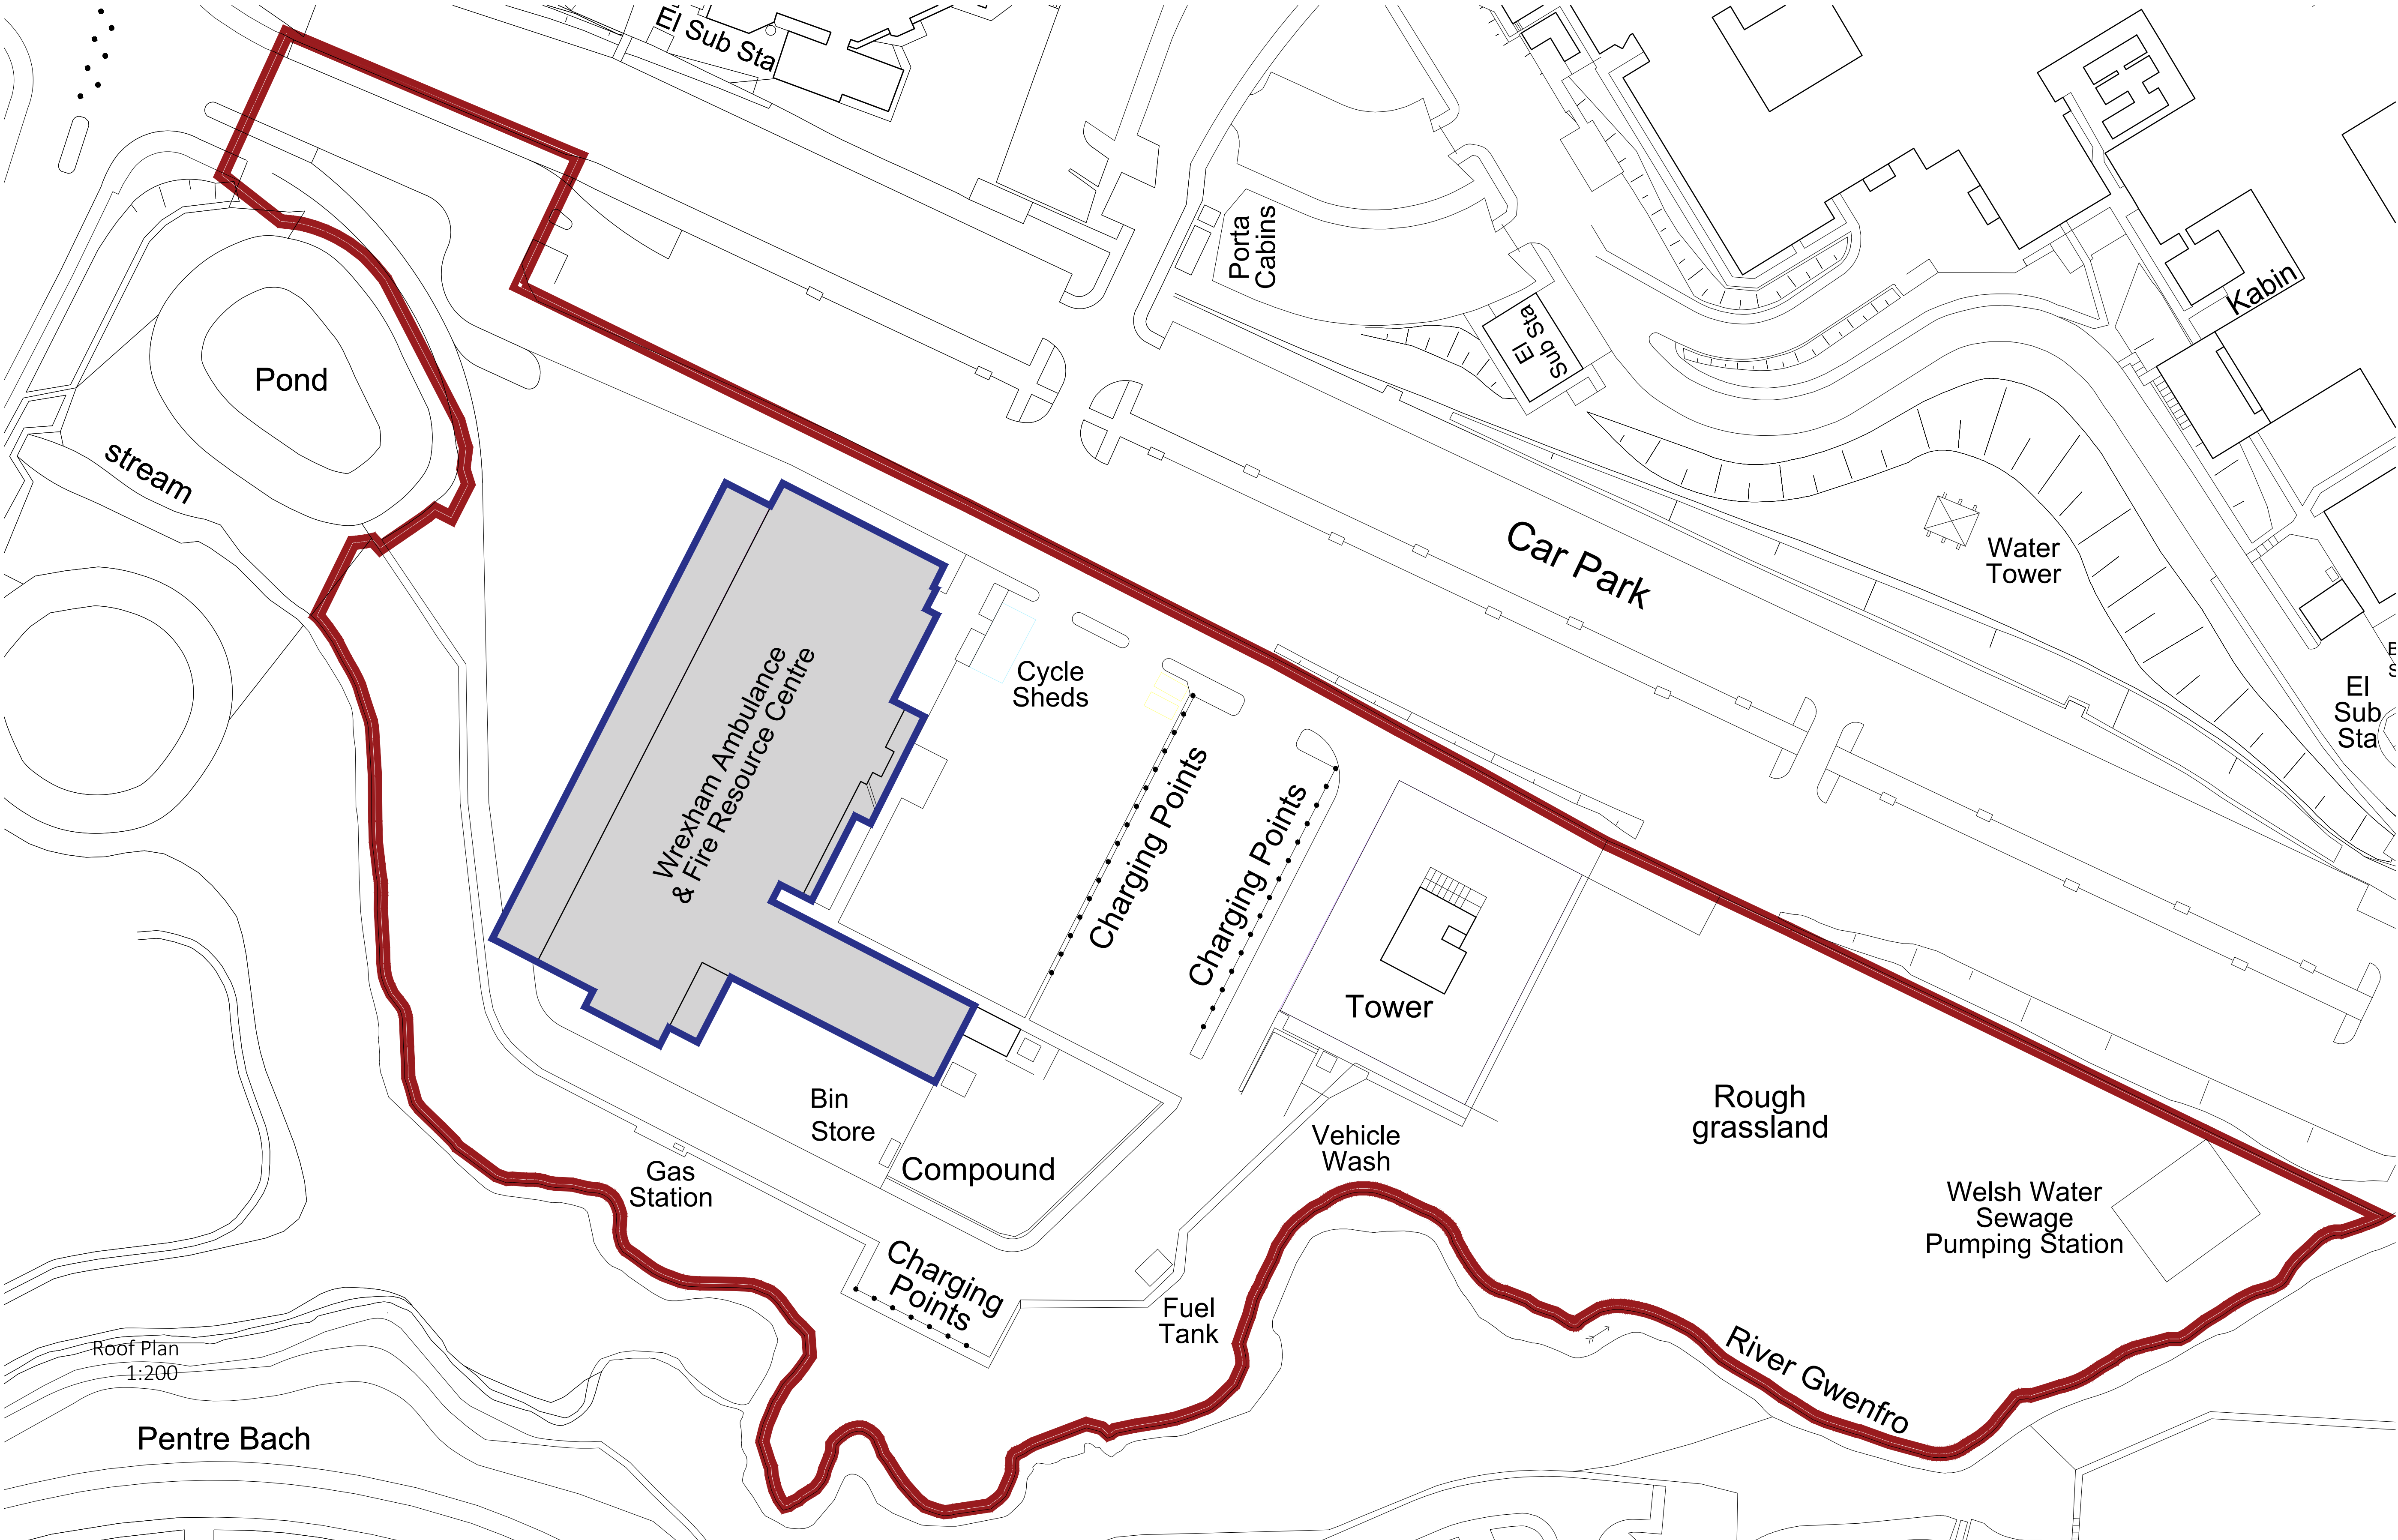

Roof Plan
1:200

Pentre Bach

Site Plan
1:500

All levels, measurements, details, positions of existing services & drainage etc. to be checked on site by contractor before work commences - any discrepancies are found, they should be reported immediately. If in doubt - ask! Copyright protected.

Installation of Renewable Energy	HJ	20/09/2023
	Drawn By	
	1:500@ A2 Scale	
Wrexham Ambulance Station	Project Address	1051/03
	Job No.	