
 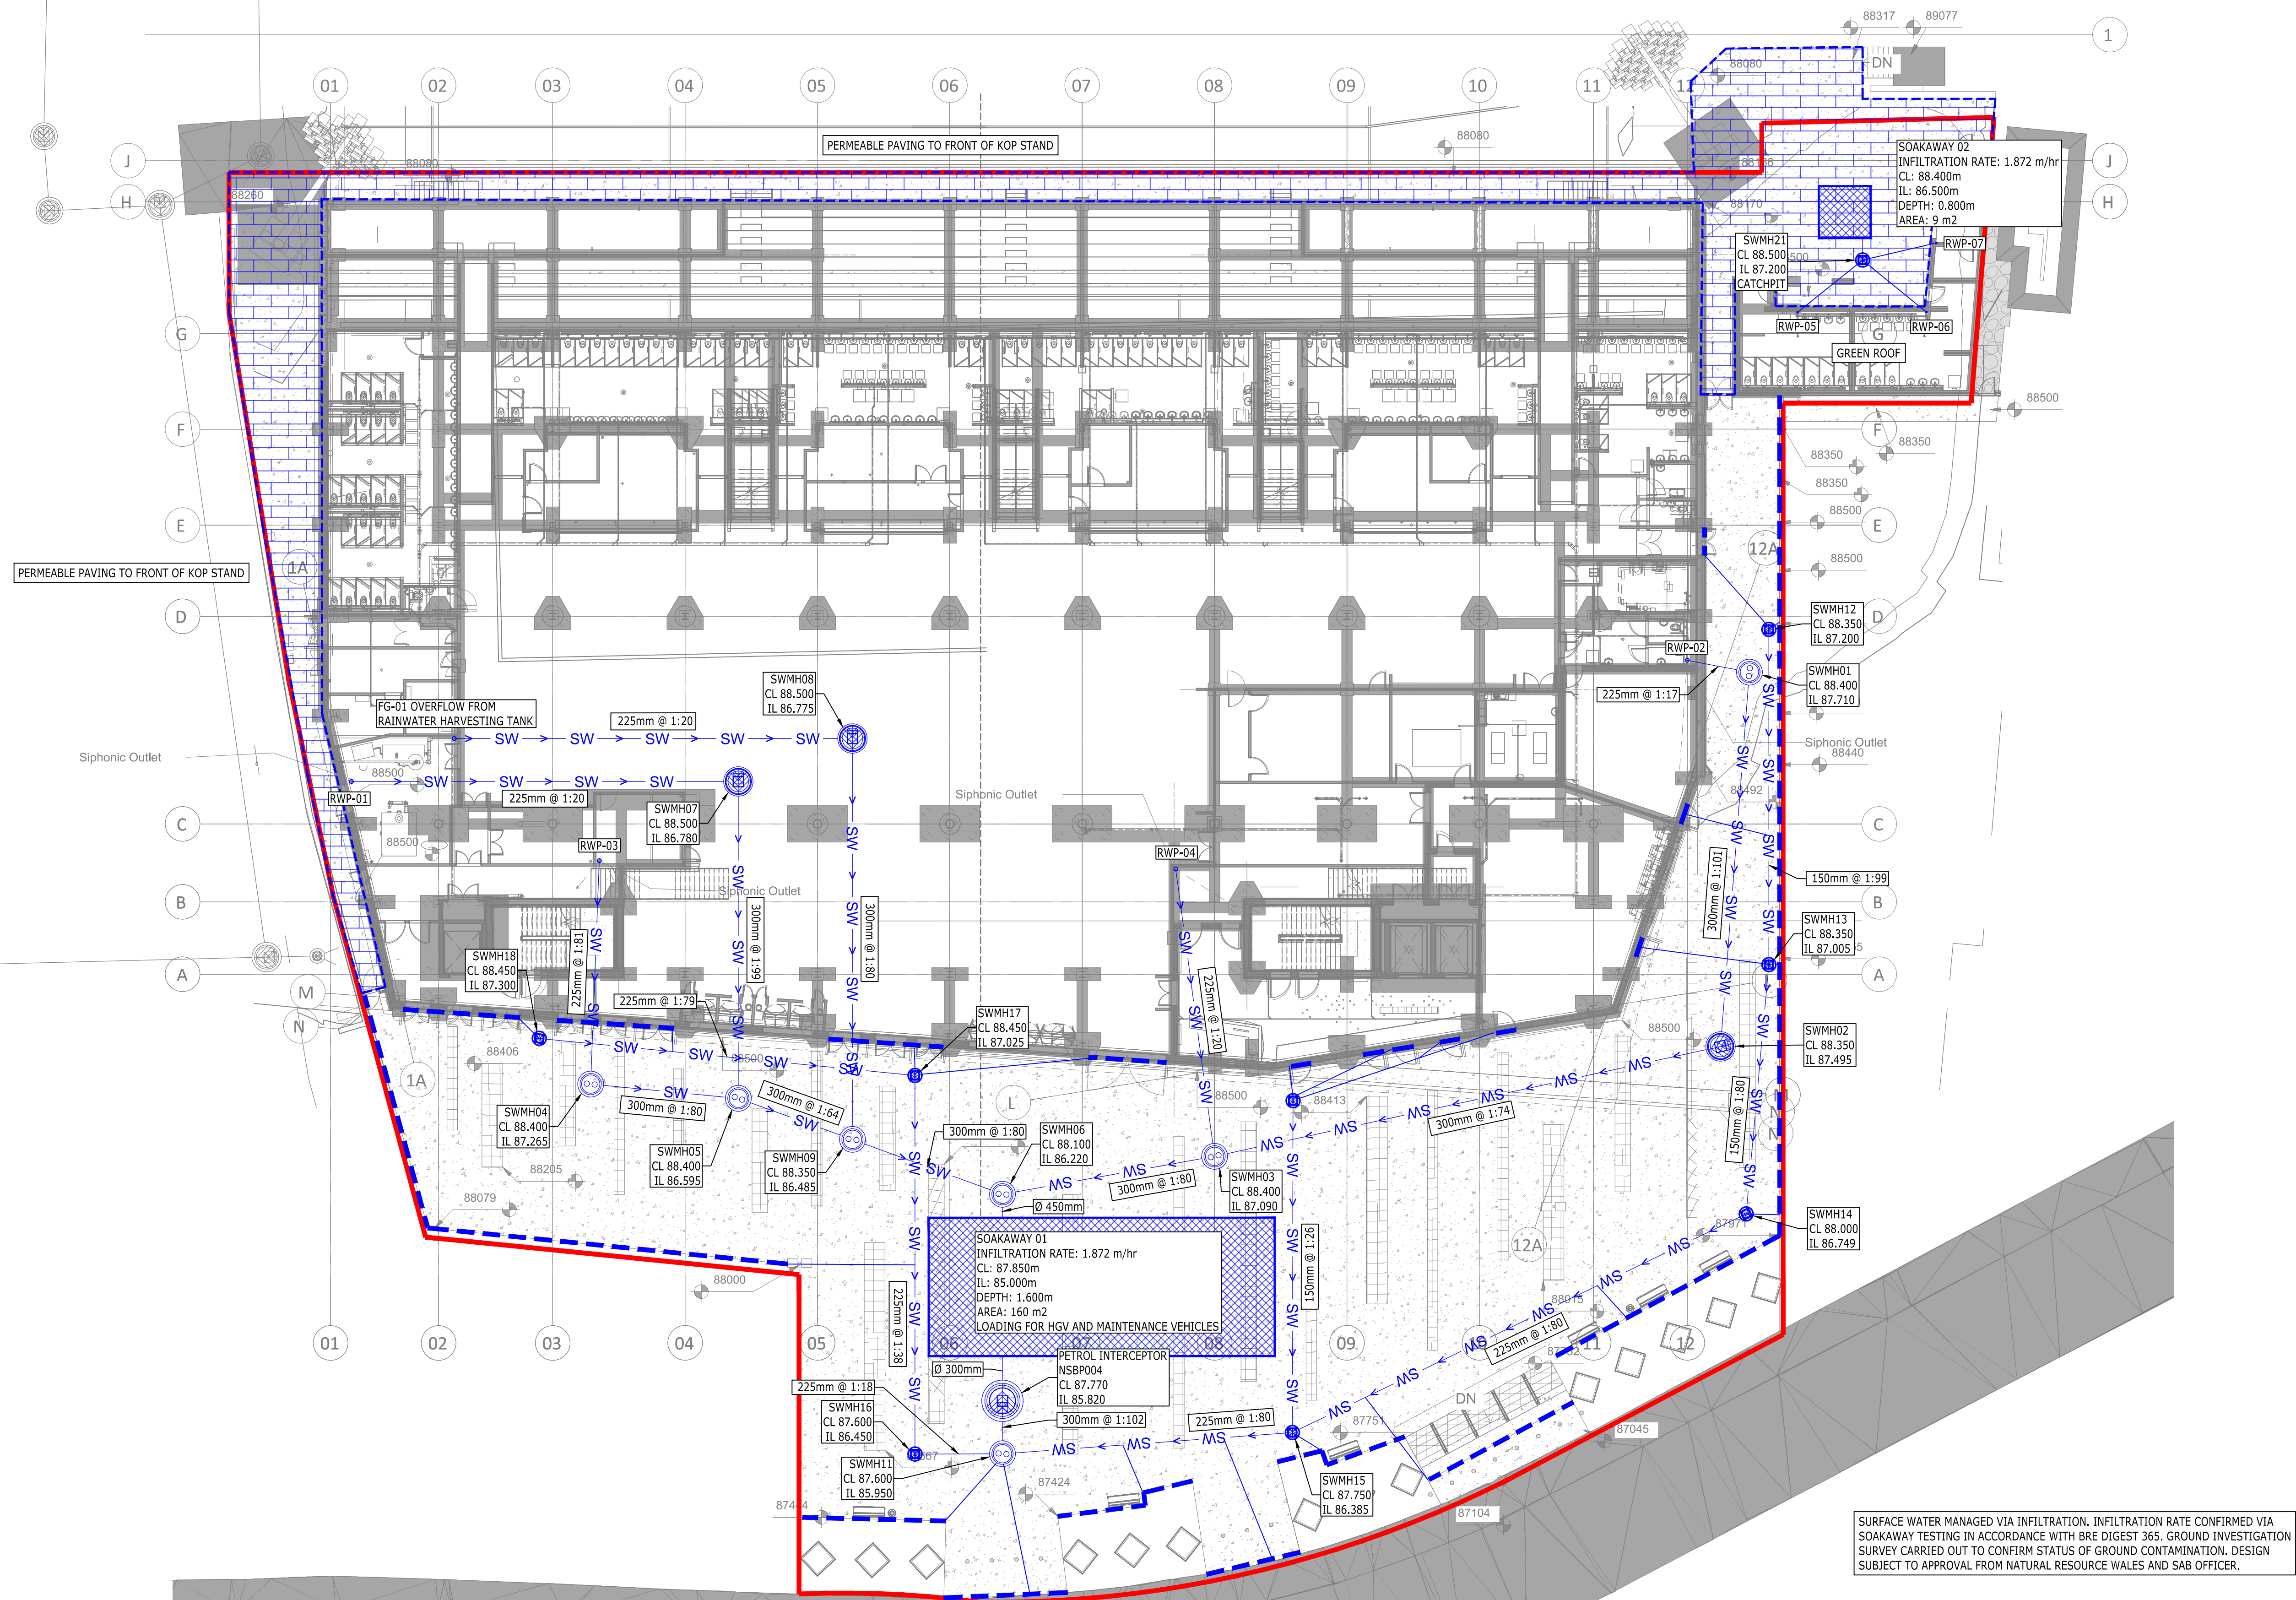
 




- KEY:**
- | | |
|---|---------------------------------|
|  | SITE BOUNDARY |
|  | PROPOSED SURFACE WATER DRAINAGE |
|  | SURFACE WATER DRAINAGE MANHOLE |
|  | PERMEABLE PAVING |
|  | SOAKAWAY |
|  | PPIC SURFACE WATER MANHOLE |
|  | LINEAR DRAIN |

P04	STAGE 4A ISSUE	28.04 2023	NK JW	PC
P03	STAGE 4A ISSUE	19.04 2023	NK JW	PC
P02	PRELIMINARY ISSUE	31.03 2023	NK JW	PC
P01	PRELIMINARY ISSUE	28.10 2022	MHW JW	PC
Rev	Description	Date	By CHK	App

PRELIMINARY

WREXHAM AFC
KOP STAND



SURFACE WATER DRAINAGE LAYOUT

Project No: 1620012485	Scale (@A1): 1:200	Drawn: MHW	Date: OCT'22
Drawing No: WRX-RAM-ZZ-ZZ-DR-CD-00102		Suitability: S3	Rev: P04