


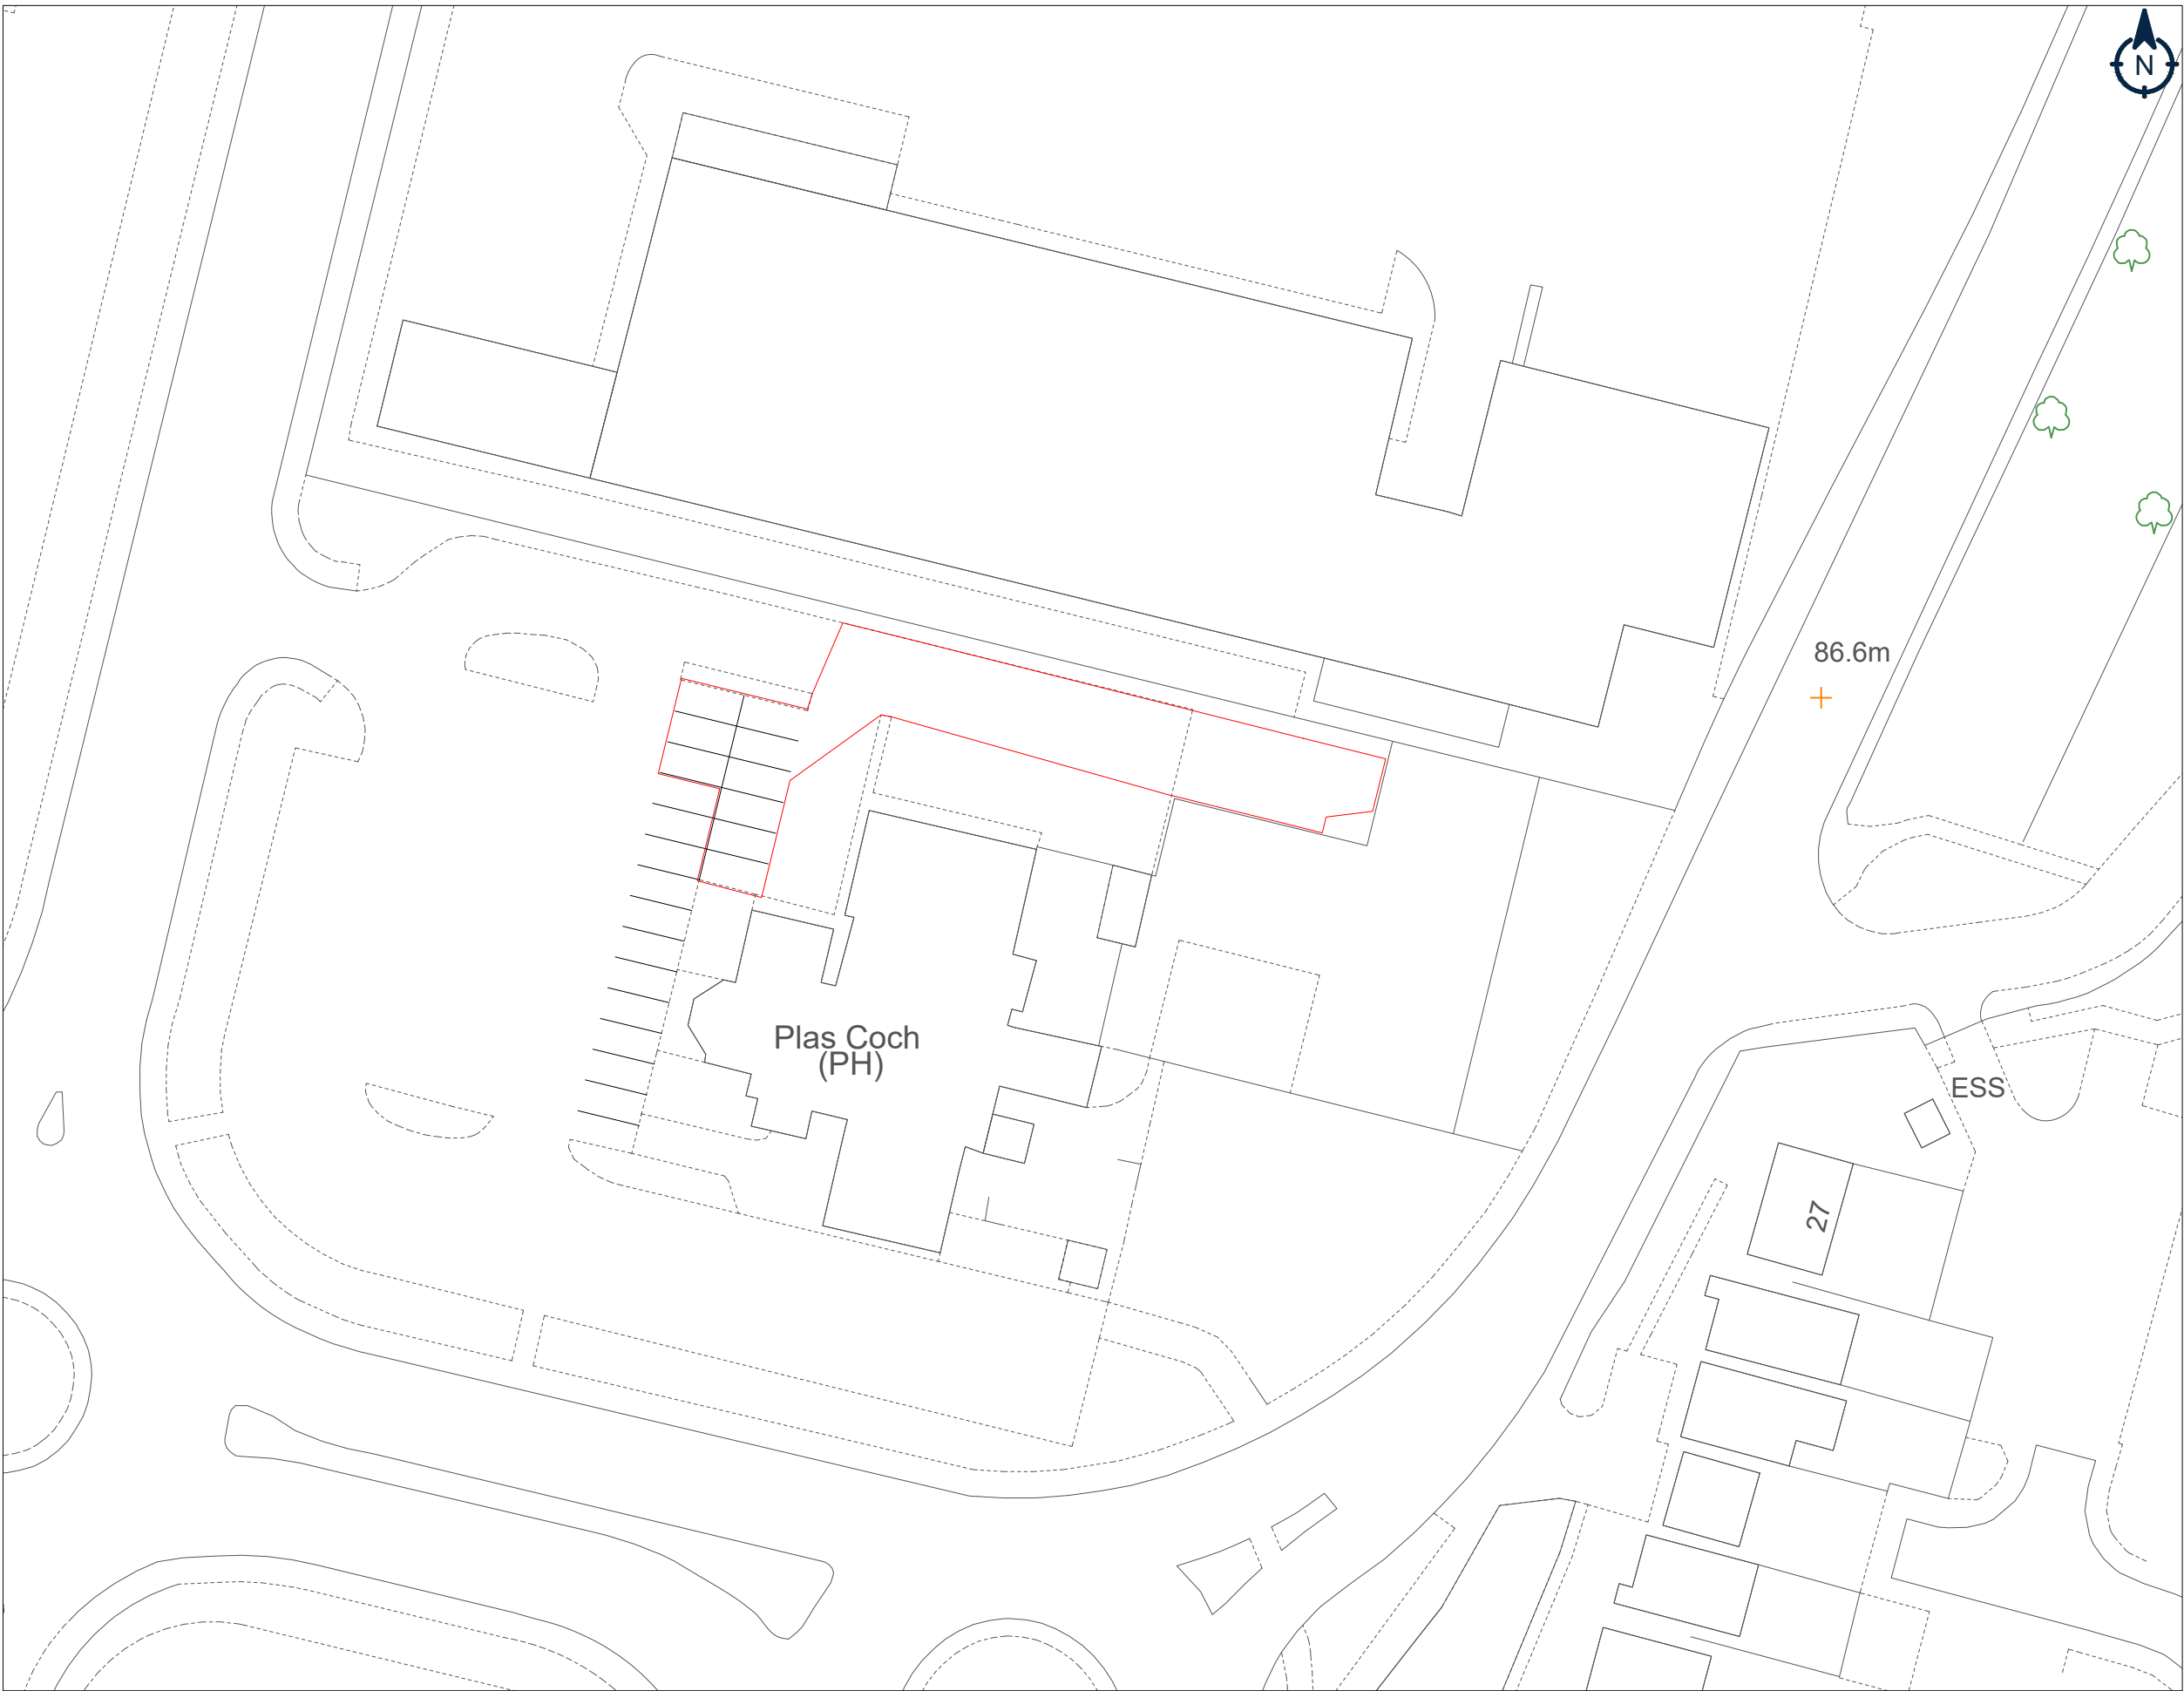

Plan 2

Notes:

- Development Site
- Feeder Pillar
- EV Chargepoint
- Bollard
- Power Unit
- Substation

V1	Initial Draft	TL	21/09/23
REV:	DESCRIPTION:	BY:	DATE:

AMENDMENTS:



Osprey Charging Network Ltd
3rd Floor, Martin House, 5 Martin Lane,
London, EC4R 0DP
T: 0800 058 8400
www.ospreycharging.co.uk

CLIENT:
Marstons Brewery Group

SITE:
Plas Coch Wrexham - LL11 2BW

TITLE:
Site Plan Existing

SCALE AT A3:	DATE:	DRAWN:	REVISION:
1:500	21/09/2023	TL	V1

© CROWN COPYRIGHT AND DATABASE RIGHTS 2023 - ORDNANCE SURVEY 0100031673

Whilst working on behalf of Osprey, all site staff are required to work safely and any safety incidents must be reported to james.reason@ospreycharging.co.uk as soon as possible. Construction works carried out and safety precautions must comply with Construction Design and Management 2015 regulation - In the event of an emergency with an Osprey charge point, or to report a fault, please contact the 24/7 Helpline - 03300 101 757

