




Plan to work commencing ①

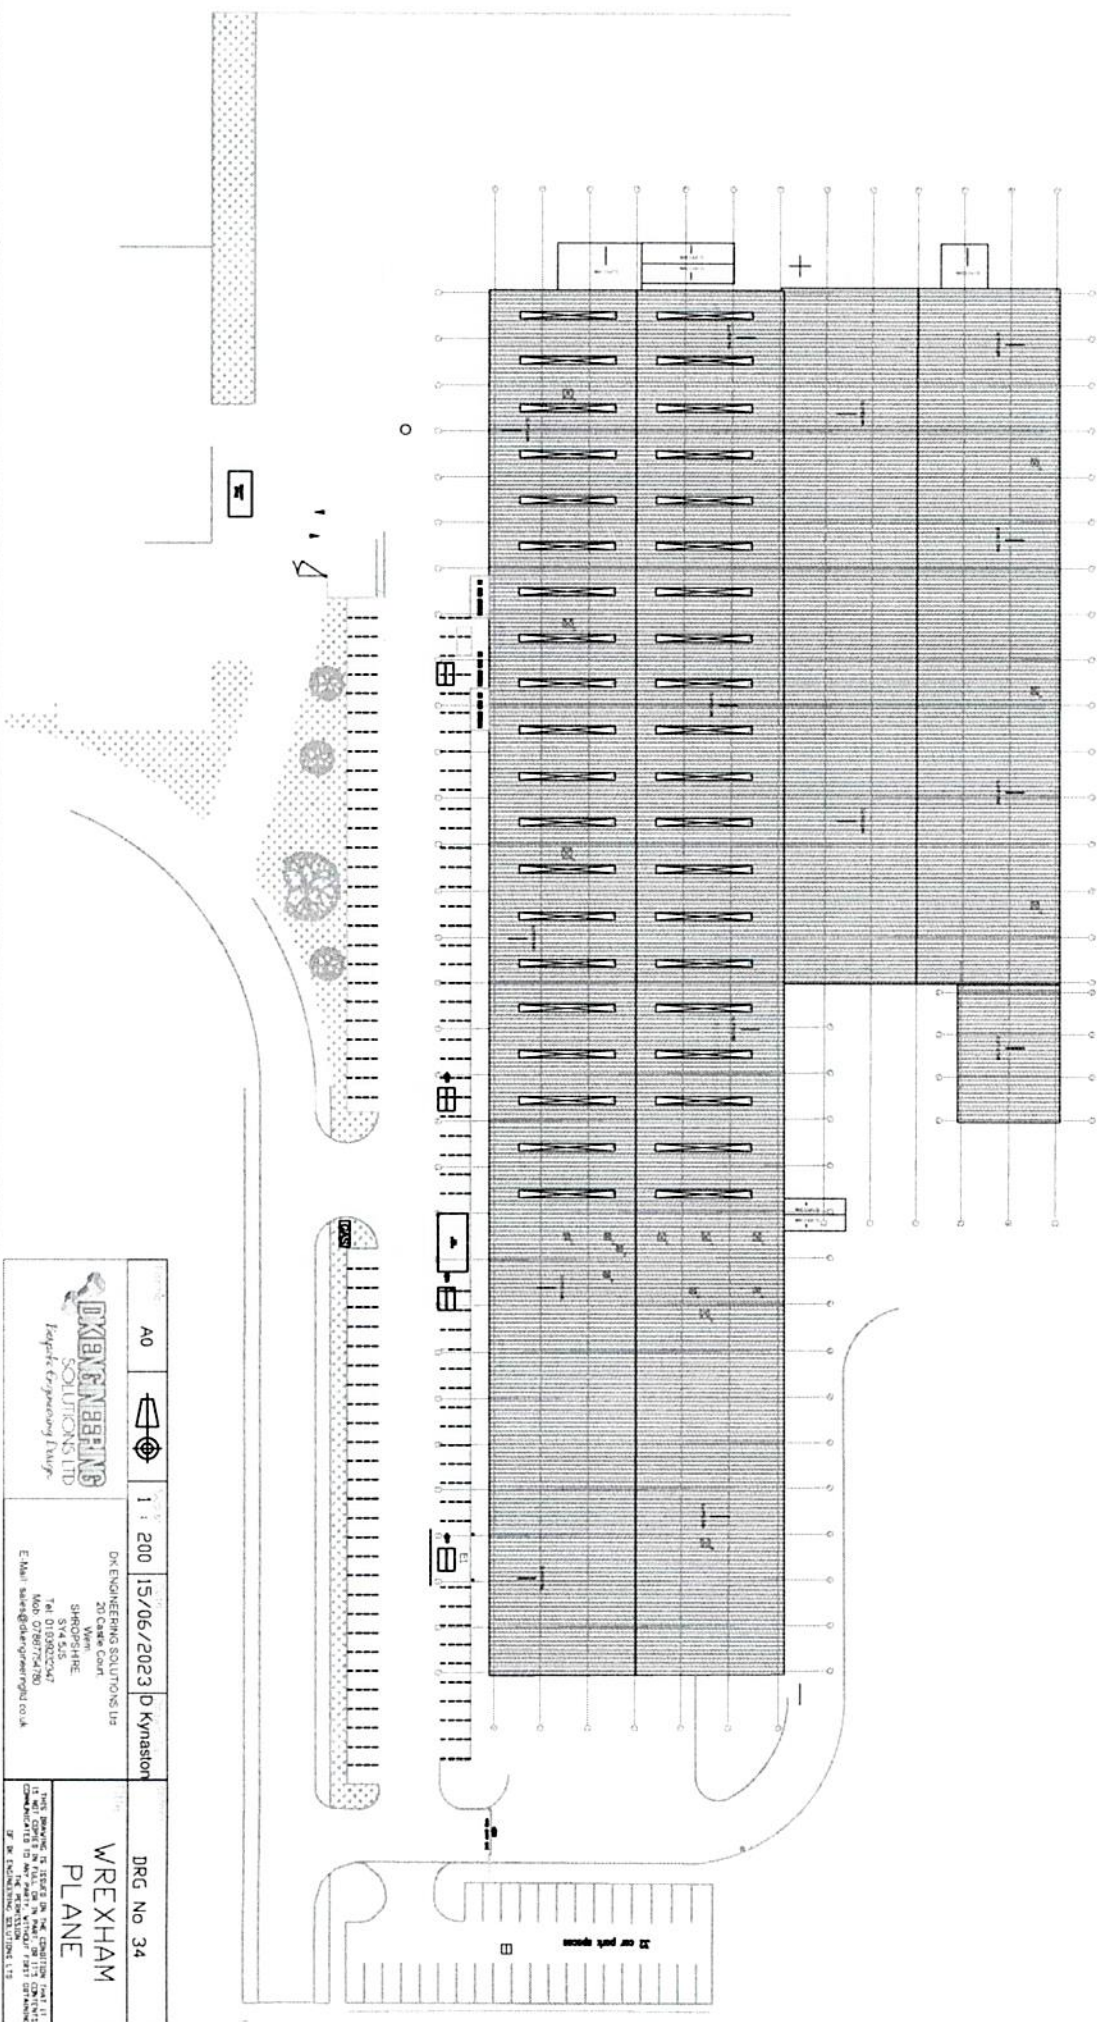

A0 1 : 200 15/06/2023 D Kynaston	DRG No 34
 KYNASTON ENGINEERING SOLUTIONS LTD <i>Resolute Engineering Group</i> 20 Caele Court SHROPSHIRE SY4 4LS Tel: 01930222467 Mob: 07867724180 E-Mail: sales@kynastonsolutions.co.uk	WREXHAM PARK THIS DRAWING IS ISSUED AS AN EXHIBITION COPY IT WILL COVER IN FULL OR IN PART OR PART OF THE CONSTRUCTION OF THE PROJECT IF NOT EXHIBITION COPY OF THE PROJECT

- 1) COOLING WATER TOWER.
- 2) 2 X SHIPPING CONTAINERS.
 - a. STEAM BOILER.
 - b. AIR COMPRESSOR.


Post work

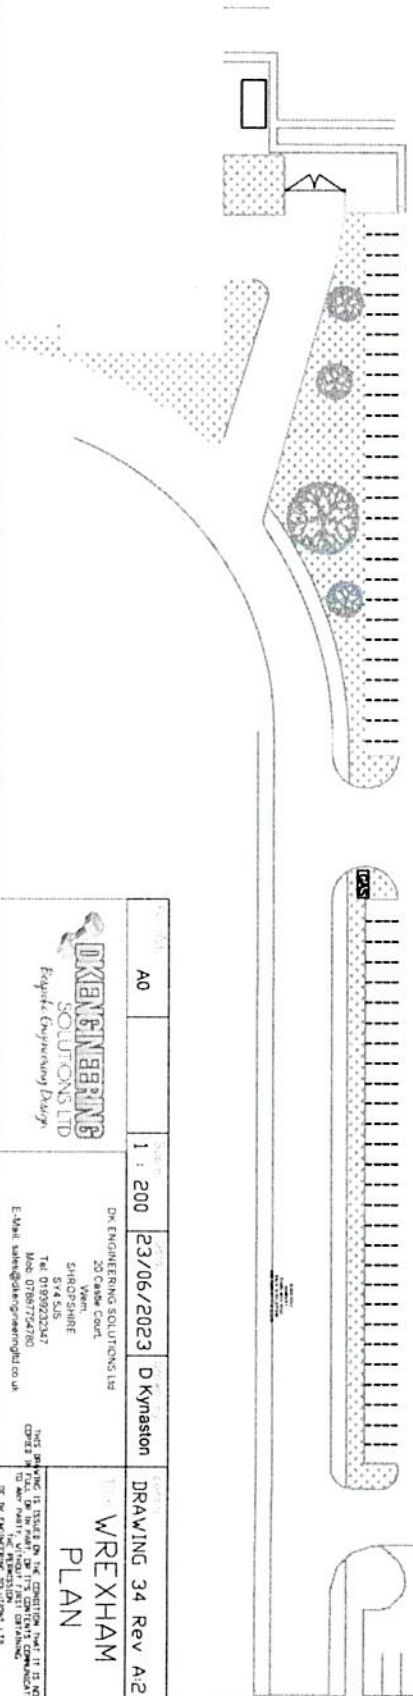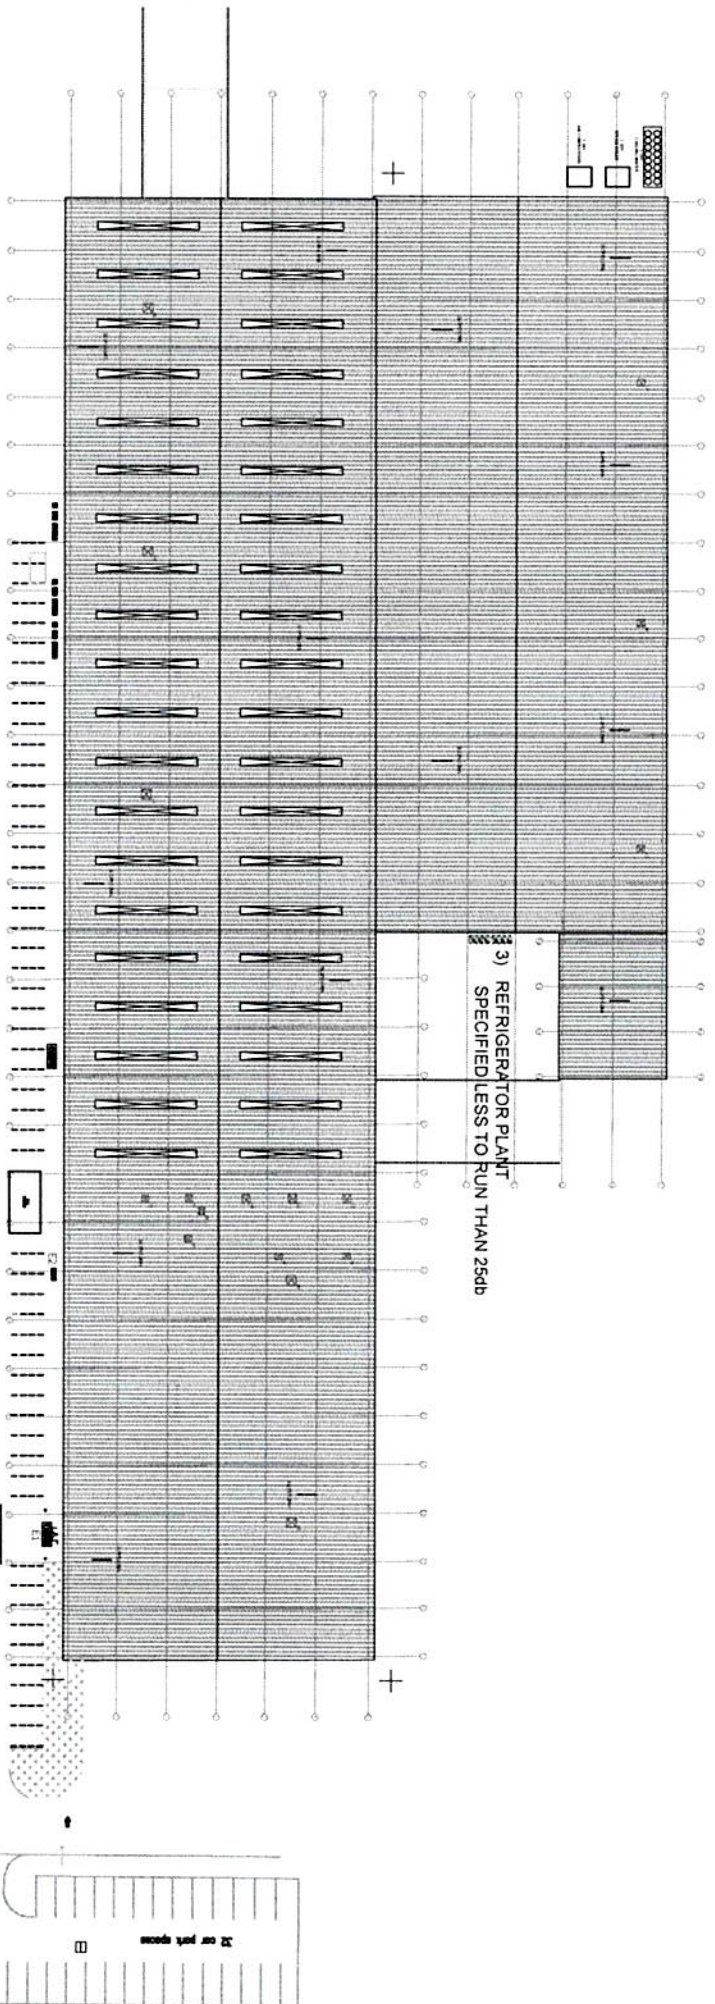

A0	1 : 200	23/06/2023 D Kynaston
	DK ENGINEERING SOLUTIONS LTD 20 CHAM COURT WIMBORNE DORSET DT99 2JZ TEL 01929 22347 FAX 01929 22347 E: info@dkengineering.co.uk	DRAWING 34 Rev A/2 WREXHAM PLAN THIS DRAWING IS ISSUED ON THE CONDITION THAT IT IS NOT TO BE USED FOR ANY OTHER PROJECT WITHOUT THE WRITTEN PERMISSION OF DK ENGINEERING SOLUTIONS LTD

PLEASE FIND AMENDMENTS, UPDATED ELEVATIONS


SIDE 1
ELEVATION

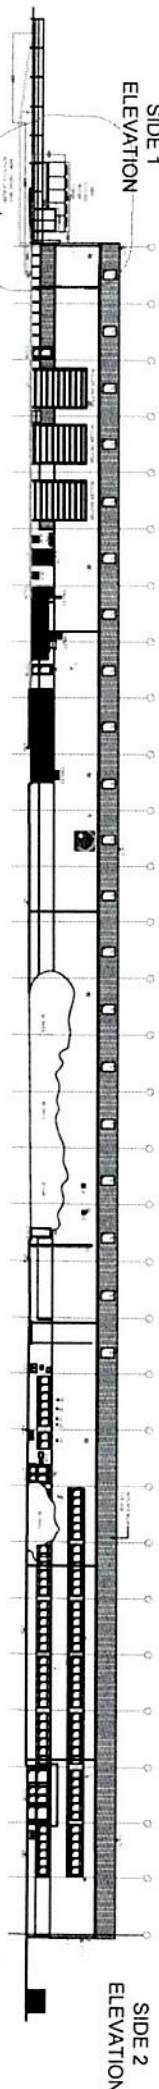


FRONT ELEVATION

- 1) COOLING WATER TOWER,
- 2) 2 X SHIPPING CONTAINERS,
a. STEAM BOILER,
b. AIR COMPRESSOR,
- 3) REFRIGERATOR PLANT

SIDE 1 ELEVATION

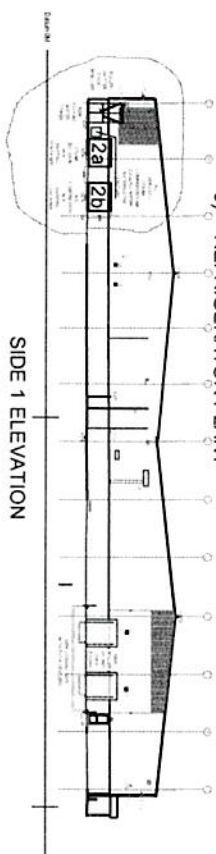


BACK ELEVATION

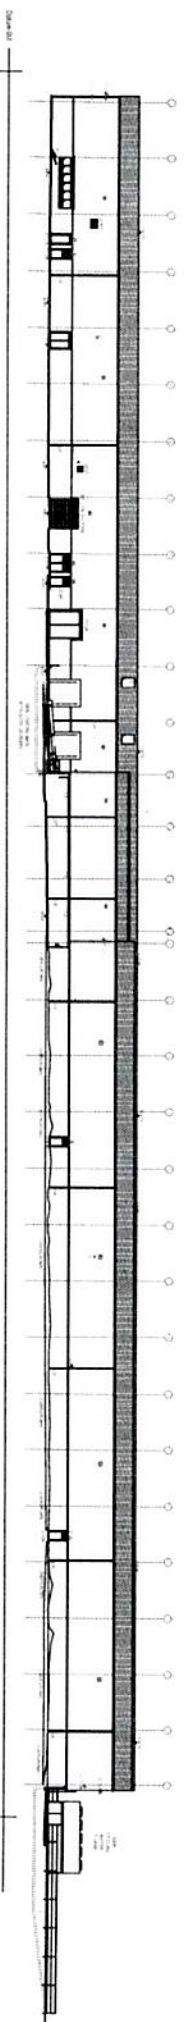

SIDE 2 ELEVATION

- 3) REFRIGERATOR PLANT
SPECIFIED LESS TO RUN THAN 25db

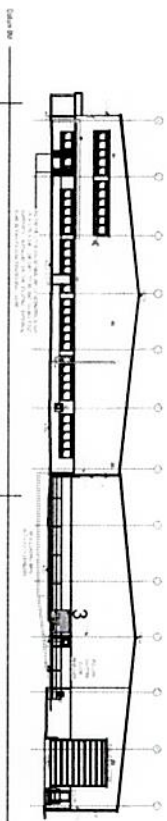

Scale: 1:200	1:200	DRG No 34 REV A.1
DK ENGINEERING SOLUTIONS LTD Exquisite Engineering Designs	DK ENGINEERING SOLUTIONS Ltd 20 Castle Court, Wem, SHROPSHIRE SY4 5LS Tel: 0193922247 Mob: 07887754780 E-Mail: sales@dkengineering.co.uk	WREXHAM ELEVATIONS

THIS DRAWING IS ISSUED ON THE CONDITION THAT IT IS NOT TO BE USED FOR ANY OTHER PROJECT WITHOUT THE WRITTEN PERMISSION OF DK ENGINEERING SOLUTIONS LTD