 


N.B. Please do not scale from these drawings.
All dimensions to be taken on-site. If in doubt - ask.



VISUAL SCALE 1:200 @ A3

outflow to
soakaway
in field

septic tank

existing manhole

mobile home

existing manhole

existing foul drain


new foul drain

new foul drain

new inspection chamber

existing foul drain

existing fence
and gates

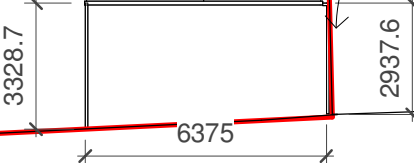

Rev.	Revision Description	Date
------	----------------------	------

Anne Netherwood Chartered Architect
11 Cottage Fields, St Martins, Oswestry, Shropshire SY11 3EJ
Tel 44(0)1691 778 495
44(0)7580 162 344
e-mail: anne@annenetherwood.co.uk
web: www.annenetherwood.co.uk

Project	Maes Lewis Mobile Home		
---------	------------------------	--	--

Title	Proposed Site Plan		
-------	--------------------	--	--

Scale @ A3	Drawn By	Checked By	Date
1 : 200	AN	-	20/10/21

Job No.	21-19	Sheet No.	A102	Rev.
---------	-------	-----------	------	------