

1. Contractor to provide fire dampers where ventilation ductwork passes through fire walls/barriers, all fire dampers shall be fusible link type as manufactured by Lindab Ltd.
2. WH25 - Circular
Circular fire damper for air duct system that penetrate fire resistance walls or floors. With 25 mm thick closing blade made from refractory material. Casing leakage performance class C according to Standard EN1751:2014 section C.3. The damper prevents fire and smoke from spreading through the air duct system. Tested and classified in accordance with EN 1366-2 and EN 13501-3 with 500 Pa negative pressure and CE marked in accordance with EN 15650.
3. WK25 - Rectangular
Rectangular fire damper for air duct system that penetrate fire resistance walls or floors. With 25 mm thick closing blade made from refractory material. Casing leakage performance class C according to Standard EN1751:2014 section C.3. The damper prevents fire and smoke from spreading through the air duct system. Tested and classified in accordance with EN 1366-2 and EN 13501-3 with 500 Pa negative pressure and CE marked in accordance with EN 15650.

CONDENSATE DRAINAGE NOTES

1. Contractor to provide all necessary bends, offsets, etc. to suit the installation and building construction and co-ordinate final routes with all other new & existing trades/services.
2. New, gravity condensate pipework shall be extended and connect to existing SVP's terminating via waterless trap or HepVO. Pipework routed within ceiling voids where possible.
3. Where gravity drainage is not possible then condensate drainage shall be pumped via local independent lift pumps.
4. Drainage pipework shall be run in durapipe abs tubes and fittings, suitably graded to falls and adequately supported throughout. Refer to landlord's specification. The contractor shall include for all necessary fittings, adaptors, etc. to connect to the above ground drainage systems.

Legend:

REFRIGERANT HEATING/COOLING NOTES

1. All indoor fan coil units shall be fed (electrically) from local distribution boards, all external condensing units shall be powered via local distribution boards. Local isolators will be provided by the contractor.
2. All grouped AC units shall incorporate a grouped condensate system. Wall mounted FCU's shall have individual condensate lift pump fitted.
3. Install, test and commission all plant, pipework & fittings that are necessary for a complete working system.
4. Branch control box and refrigeration pipework shall be designed and supplied by the refrigeration contractor.
5. All refrigerant to be R410A / R32.

VENTILATION NOTES

1. The mechanical contractor is responsible for final co-ordination and installation of all mechanical services with all other services and the building structure.
2. All ductwork shall be manufactured, installed, tested & commissioned in strict accordance WITH HTM03.01 DW144, DW143, DW151, DW171, DW/TM2, DW/TM3, TR/17 & CIBSE commissioning codes.
3. Access doors shall be provided adjacent all fire dampers, volume control dampers and heater batteries, either side of air turns & at least 4m intervals on duct routes.
4. All duct runs & diffuser positions must be checked & set out against fully detailed ceiling and floor layouts, structural engineering & electrical service drawings. All dimensions must be checked out on site prior to the installation being executed, the contractor will be expected to co-ordinate the ductwork & piped services with all other trades.
5. All ductwork to be identified in accordance with BS1710.
6. All supply air (and extract where on a heat recovery system) ductwork within risers and plant spaces and ceiling voids to be insulated. Intake and exhaust ductwork to be insulated and vapour sealed against condensation where located in heated / internal spaces.
7. All branch connections shall be provided with VCD's to facilitate balancing in accordance with all relevant CIBSE codes and good practices.
8. The contractor shall provide fire dampers, complete with built-in frames for fixing to the building structure as required, in accordance with the current architects fire strategy drawings.
9. The contractor shall agree ALL penetrations through slabs etc with the structural engineer.
10. The contractor shall provide all ventilation system attenuation as required in accordance with the acoustic recommendations.
11. All door transfer grilles and door undercuts to be provided as necessary for ventilation return air path. The contractor will need to take in consideration of acoustic and fire strategy report to satisfy all requirements. Door undercuts shall be a minimum of 10mm and shall not exceed a maximum of 15mm.
12. All ductwork to be of galvanised steel construction.
13. Flexible ventilation ductwork shall only be used for the final connections to the grilles. All excess flexible ductwork shall be cut back to a minimum of 500mm when making final connections.
14. All fans and ventilation units shall be installed within accessible locations with due regard to the manufacturer's maintenance space recommendations.
15. All ductwork with high aspect ratio in section shall be fitted with splitters.
16. The ventilation contractor is to validate and confirm all general extract / supply air volumes / flow rates throughout the floor.

GENERAL NOTES



1. The contractor is to familiarize himself with the site and all services prior to commencing work and carry out site measure prior to ordering plant/equipment.
2. All materials & workmanship must be carried out in accordance with the standard LBG specification.
3. All new/existing services shall be adequately protected from all demolition & construction works.
4. All relocated & redundant equipment shall be neatly removed.
5. The site team shall liaise with the main contractor on all BWIC works. Refer to separate BWIC drawings for collaboration with main contractor.

P02	25.11.22	UPDATED FOR CP SUBMISSION	AA	MC	
P01	18.11.22	FIRST ISSUE		PJ	MC
Rev	Date	Revision Notes		BY	CH

Client:	LLOYDS BANKING GROUP
Project:	HALIFAX WREXHAM HOPE STREET 55 HOPE STREET WREXHAM LL11 1AF
Status:	PRELIMINARY
All dimensions in mm except where otherwise stated. Dimensions up to 1 metre +/- 0.5mm. Dimensions 1 metre to 5 metres +/- 1mm. Except where otherwise stated © Copyright drawing.	



Drawing Title: BASEMENT FLOOR HVAC LAYOUT				
Drawing No. 50960570-79G-RD-BF-M2-ME-2601		Revision No. P02		
Drawn: PJ	Checked: MC	Scale @A1: 1:50	Originated Date: 18.11.22	

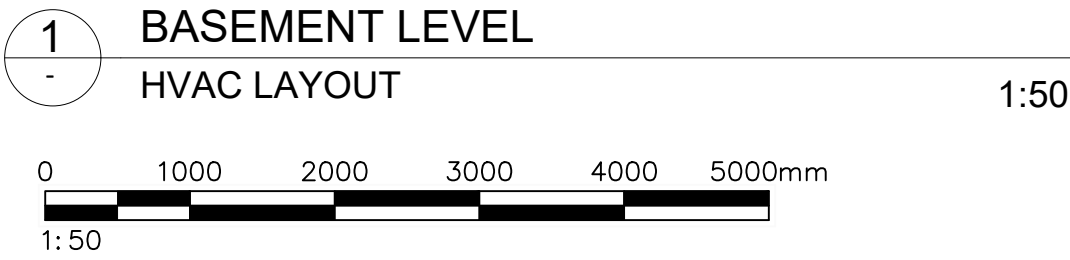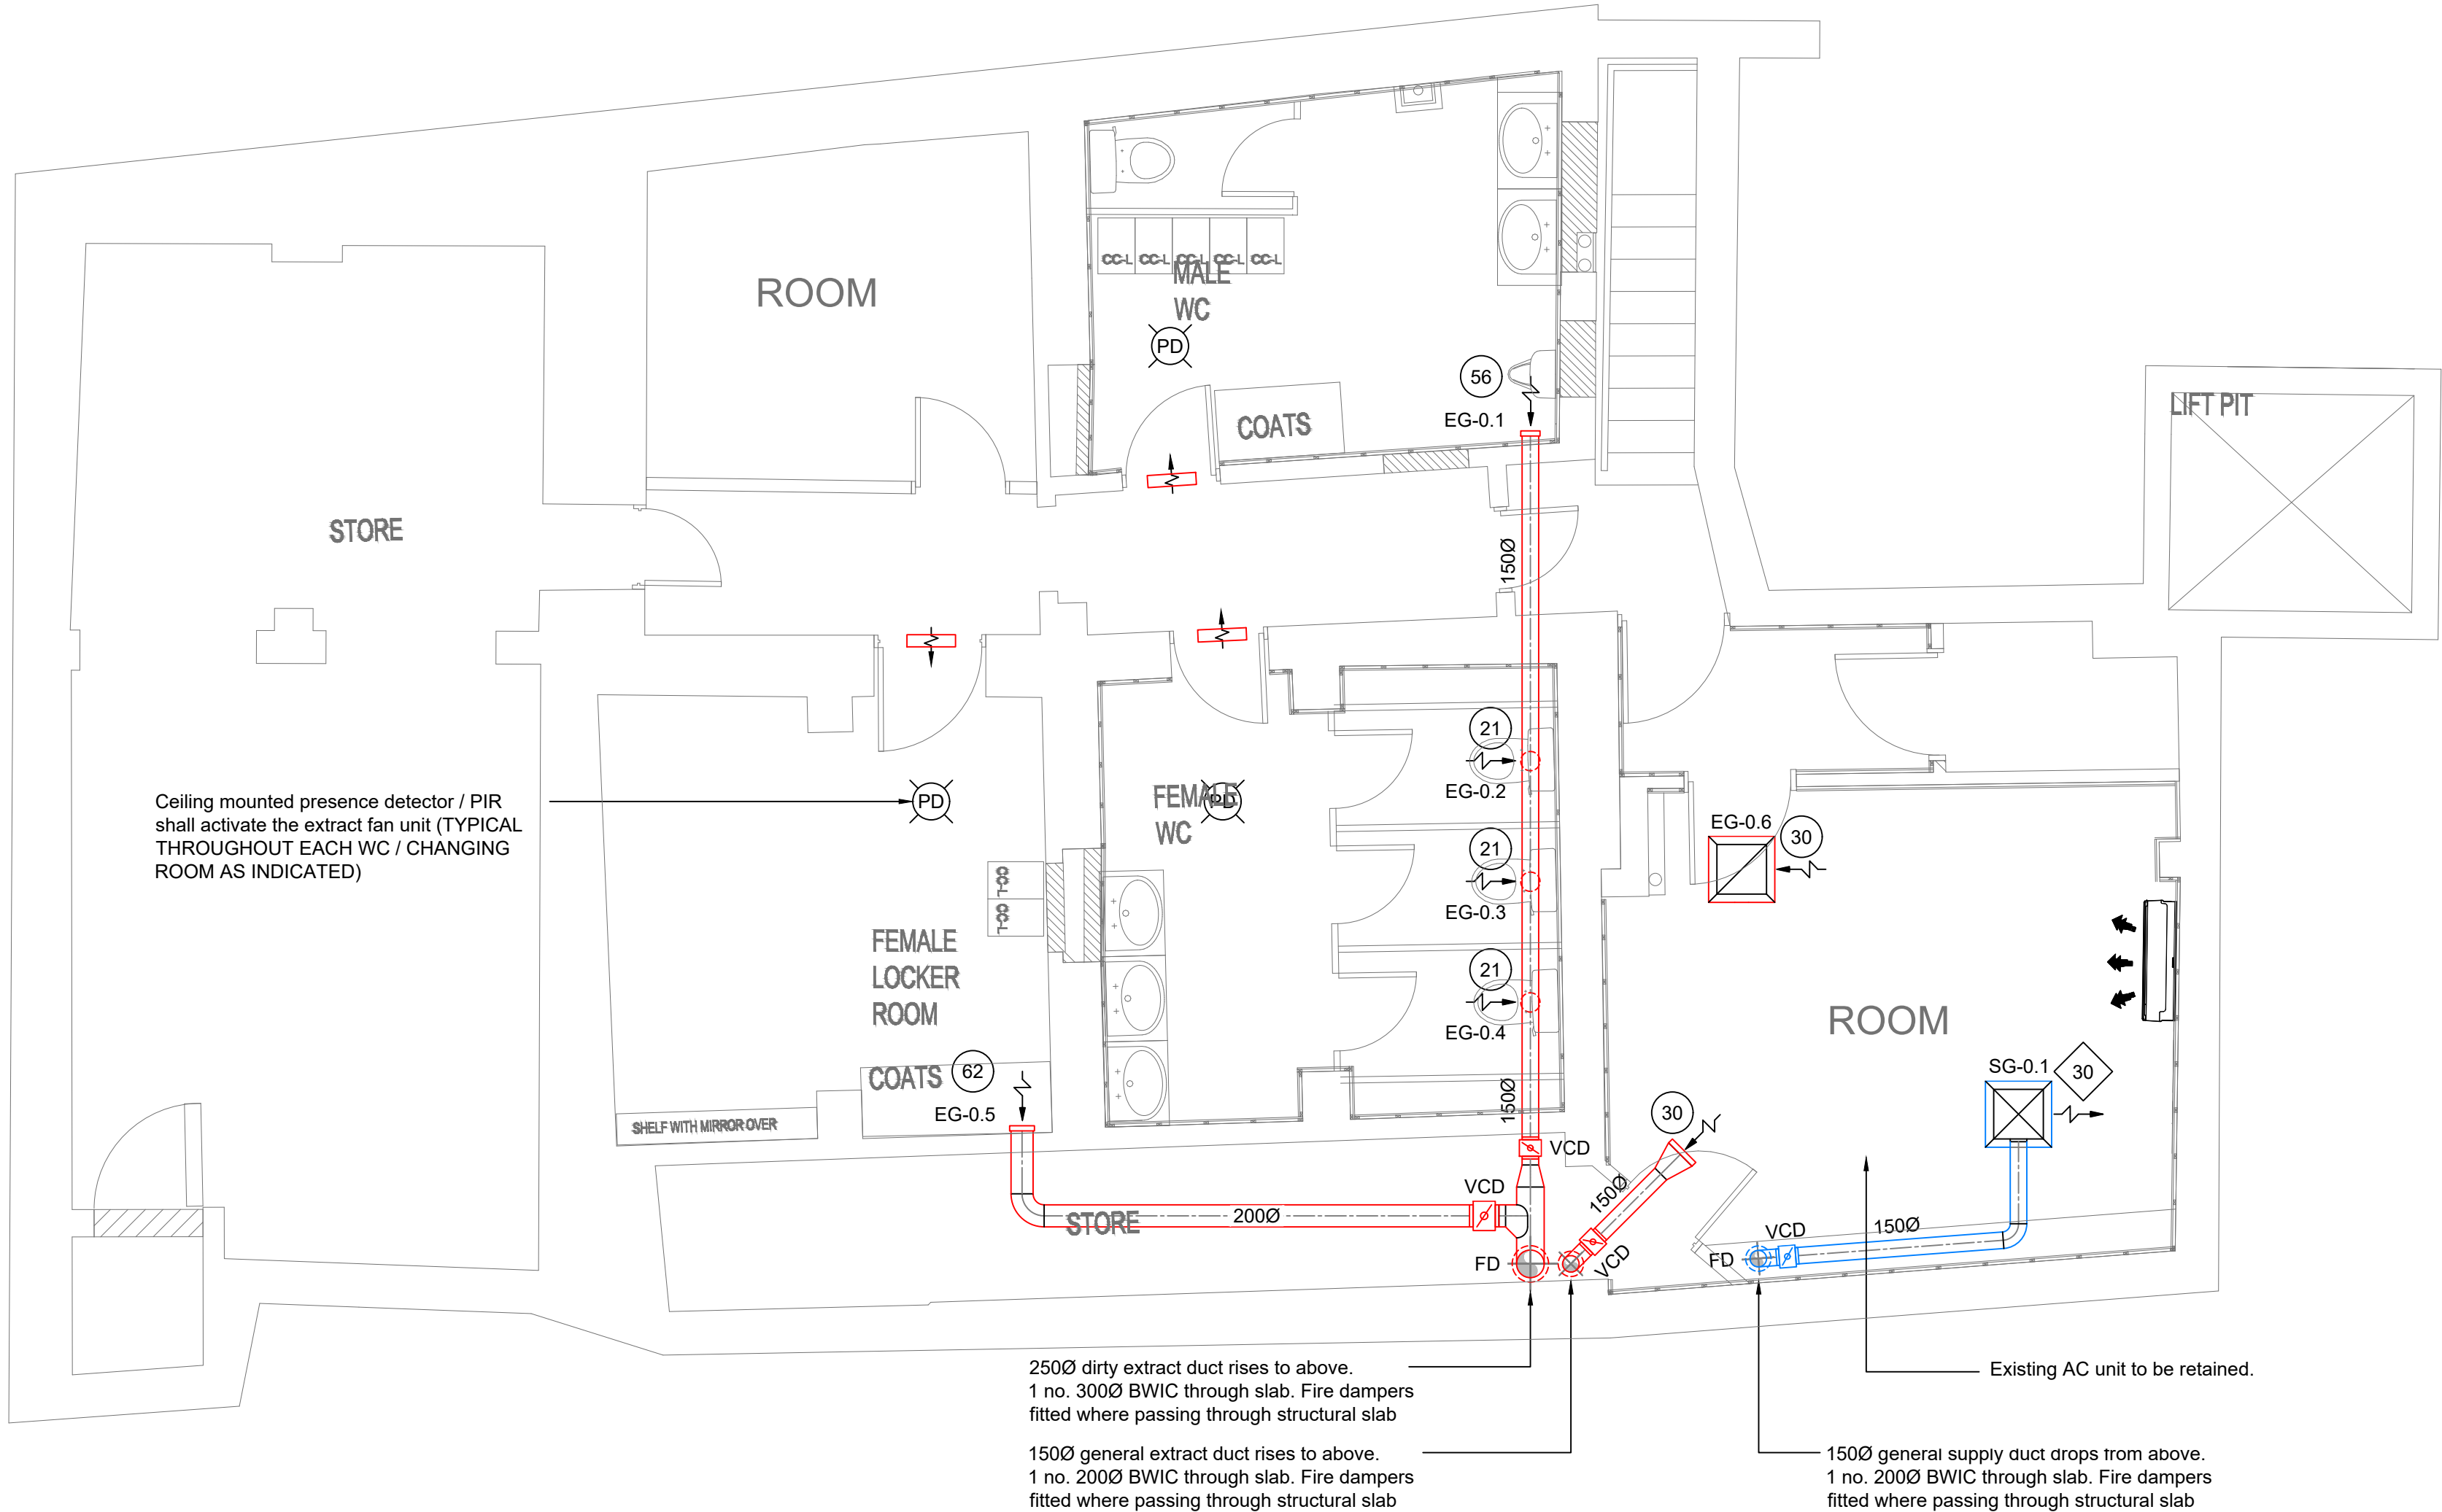

VENTILATION GRILLE SCHEDULE							
REF.	TYPE	VOLUME (l/s)	PD (Pa)	SIZE (mm)	NOISE dB(A)	CONNECTION DETAIL	FINISH
EG-0.1	LINDAB KU-150	52	34	150	26	1500 FLEXIBLE CONNECTION	RAL 9010
EG-0.2	LINDAB KU-150	21	11	125	<20	1250 FLEXIBLE CONNECTION	RAL 9010
EG-0.3	LINDAB KU-150	21	11	125	<20	1250 FLEXIBLE CONNECTION	RAL 9010
EG-0.4	LINDAB KU-150	21	11	125	<20	1250 FLEXIBLE CONNECTION	RAL 9010
EG-0.5	LINDAB KU-200	62	12	200	<20	2000 FLEXIBLE CONNECTION	RAL 9010
EG-0.6	LINDAB RS-14	30	6	595 x 595	<20	OPEN TOP c/w LIGHTING BAFFLE	RAL 9010
SG-0.1	LINDAB RS-14	30	5	595 x 595	<20	1500 FLEXIBLE CONNECTION	RAL 9010

CONTROLS	
SYMBOL	DESCRIPTION
RAS	REMOTE AIR SENSOR
MC	MAIN CONTROLLER
C	FAN COIL UNIT / HRU CONTROLLER
PD	PRESENCE DETECTOR / PIR

AIR STATUS	
SYMBOL	DESCRIPTION
N	SUPPLY VOLUME (l/s)
N	EXTRACT VOLUME (l/s)

DUCTWORK/VENTILATION	
SYMBOL	DESCRIPTION
FD	FIRE DAMPER
CTA	UNDERCUT DOOR (15mm to allow free air flow)
	CROSS TALK ATTENUATOR / RETURN AIR PATH
	SUPPLY DUCT
	EXTRACT DUCT
EHB	ELECTRIC HEATER BATTERY
VCD	VOLUME CONTROL DAMPER
SG	SUPPLY GRILLE
EG	EXTRACT GRILLE

DX/REFRIGERANT	
SYMBOL	DESCRIPTION
	VRV / VRF REFRIGERATION PIPE
	SPLIT SYSTEM REFRIGERATION PIPE