


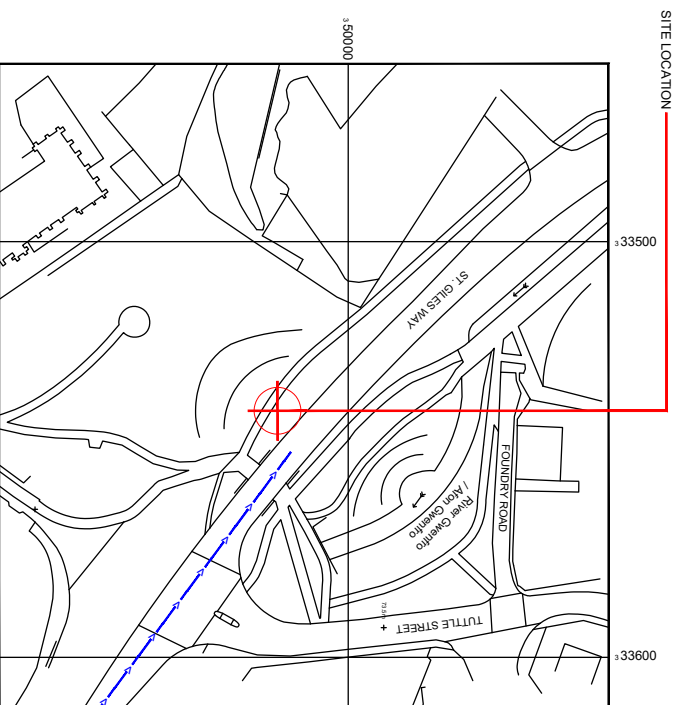

SITE PHOTOGRAPH



GOOGLE MAPS QR CODE


GOOGLE MAPS - <https://goo.gl/maps/kmNFWog7EZ1Twixt9>

GOOGLE STREETVIEW - <https://goo.gl/maps/F4Z2cbq1DZU2Ppr8>

Master	Project	Purpose of Issue	Master
M001	H3G	Planning	A
D001	02/03/2023	Revision 1: Update description	
Owner	D Warren	First Issue - Site nomination dated: TBC	
Created	D Fieldhouse		
Approved	G Thomas		

Access Route To Site

1. ALL DIMENSIONS IN MM UNLESS OTHERWISE NOTED.

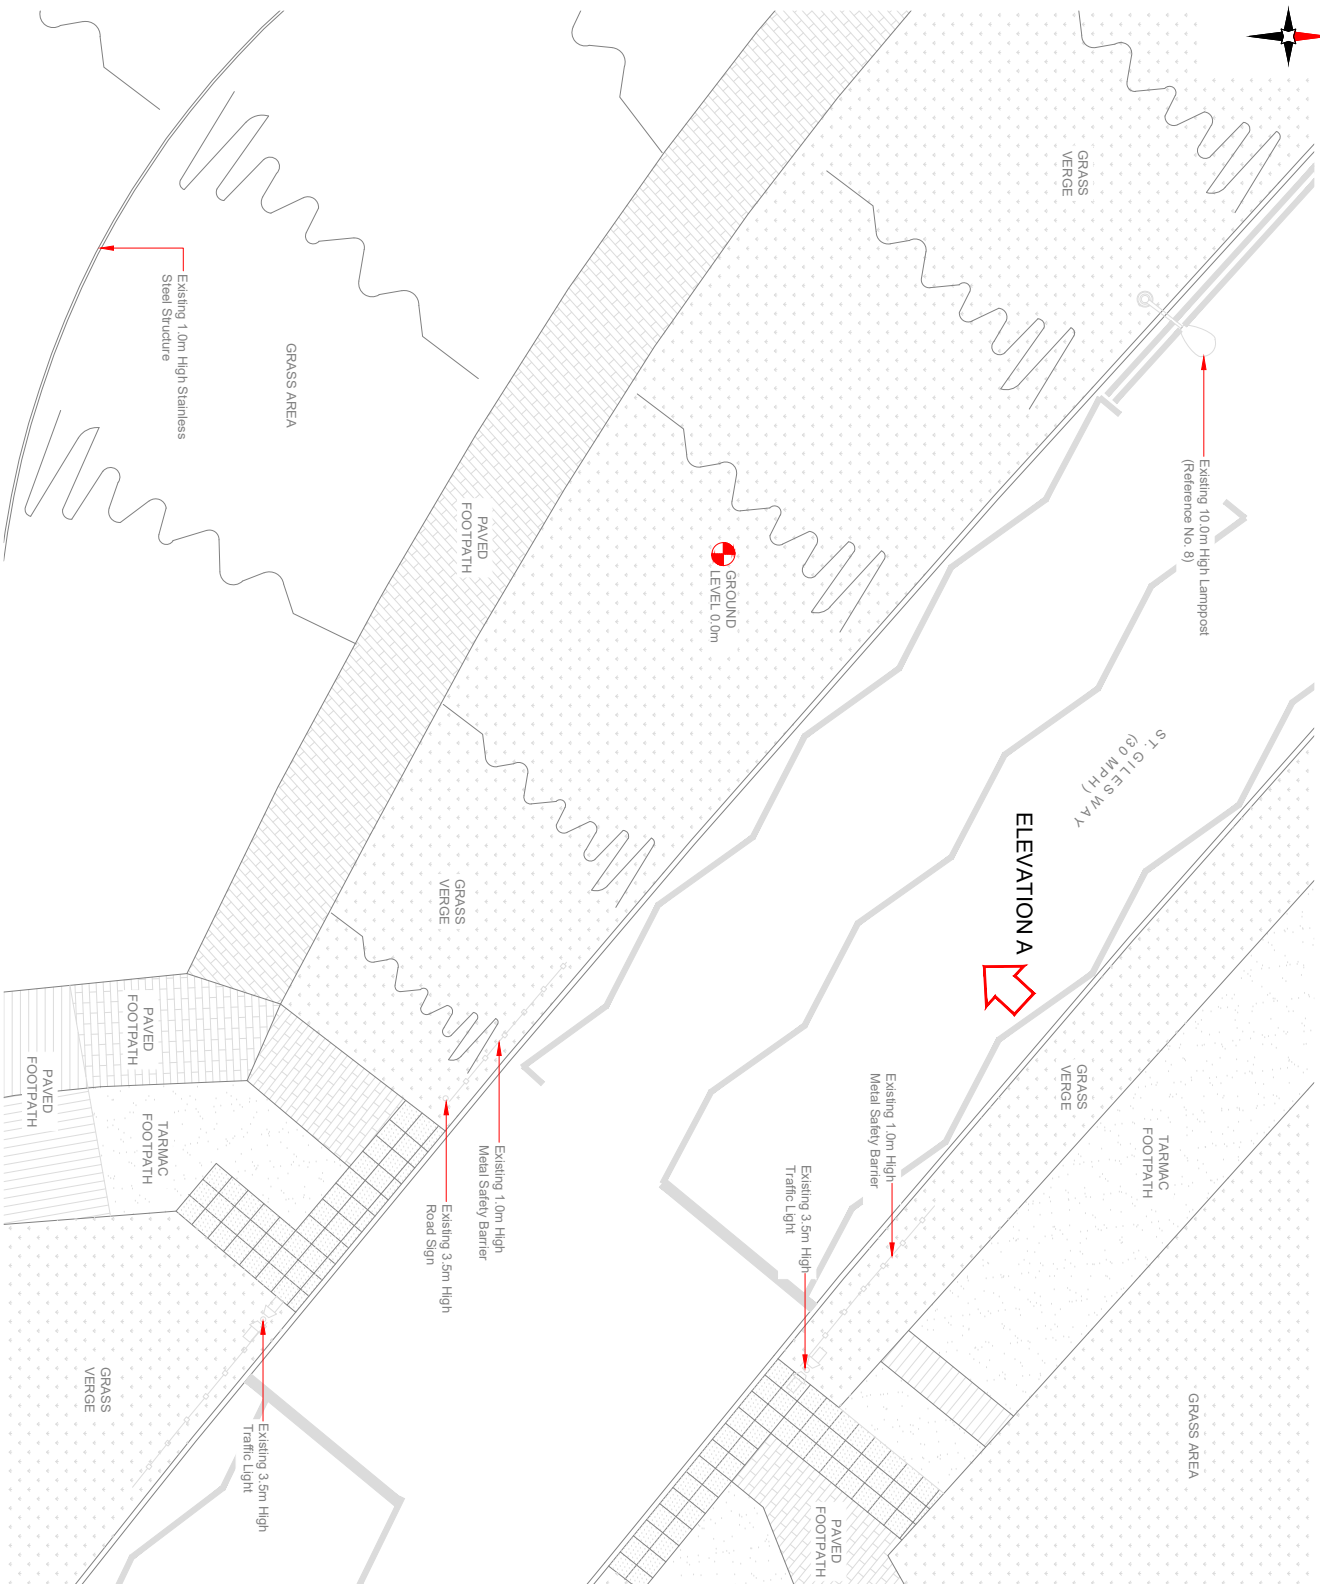

1. ALL DIMENSIONS IN MM UNLESS OTHERWISE NOTED.

WATER	WATER	WATER	WATER
HV ELECTRIC		HV ELECTRIC	
LV ELECTRIC		LV ELECTRIC	
GAS	GAS	GAS	GAS
GPR		GPA	
TELECOMS		TELECOMS	

Member	Project	Purpose of Issue	Status
M001	H3G	DENSIFICATION SW	Planning
D186	02/03/2023	Revision 1 (Stage 1) Description	A
D186	D Warren	First Issue - Site nomination dated: TBC	
D186	D Redhouse		
D186	G Thomas		
D186	Approved		

Hutchison 3G UK Limited
Green Park, 450 Longwater Avenue
Reading, RG30 3UR
Tel: 01628 765 000
Fax: 01628 765 001

H3G Base Station Information line:
0845 6043 000
Available 8am-8pm Monday to Friday

CLARKE
telecom
Unit E, Madison Place, Northampton Road,
Manchester, M40 5AG
Tel: 0161 785 4501 Fax: 0161 785 4501
Web: www.clarke-telecom.com

Unit E, Madison Place, Northampton Road,
Manchester, M40 5AG
Tel: 0161 785 4500 Fax: 0161 785 4501
Web: www.clarke-telecom.com

Site ID: WRX26710

Address:

S.I. GILES WAY

HIGHTOWN
OFFA

WREXHAM
LL13 7AD

Title: _____

Project: **H3G DENSIFICATION STREETWORKS**

Purpose of this SWG:

PLANNING

MIDLINE CALL ID: WRX067


SUN CELL ID: LL0691

WRX26710_M001_H3G_DNSW_GA

A

NOTES:

1. ALL DIMENSIONS IN MM UNLESS OTHERWISE NOTED.

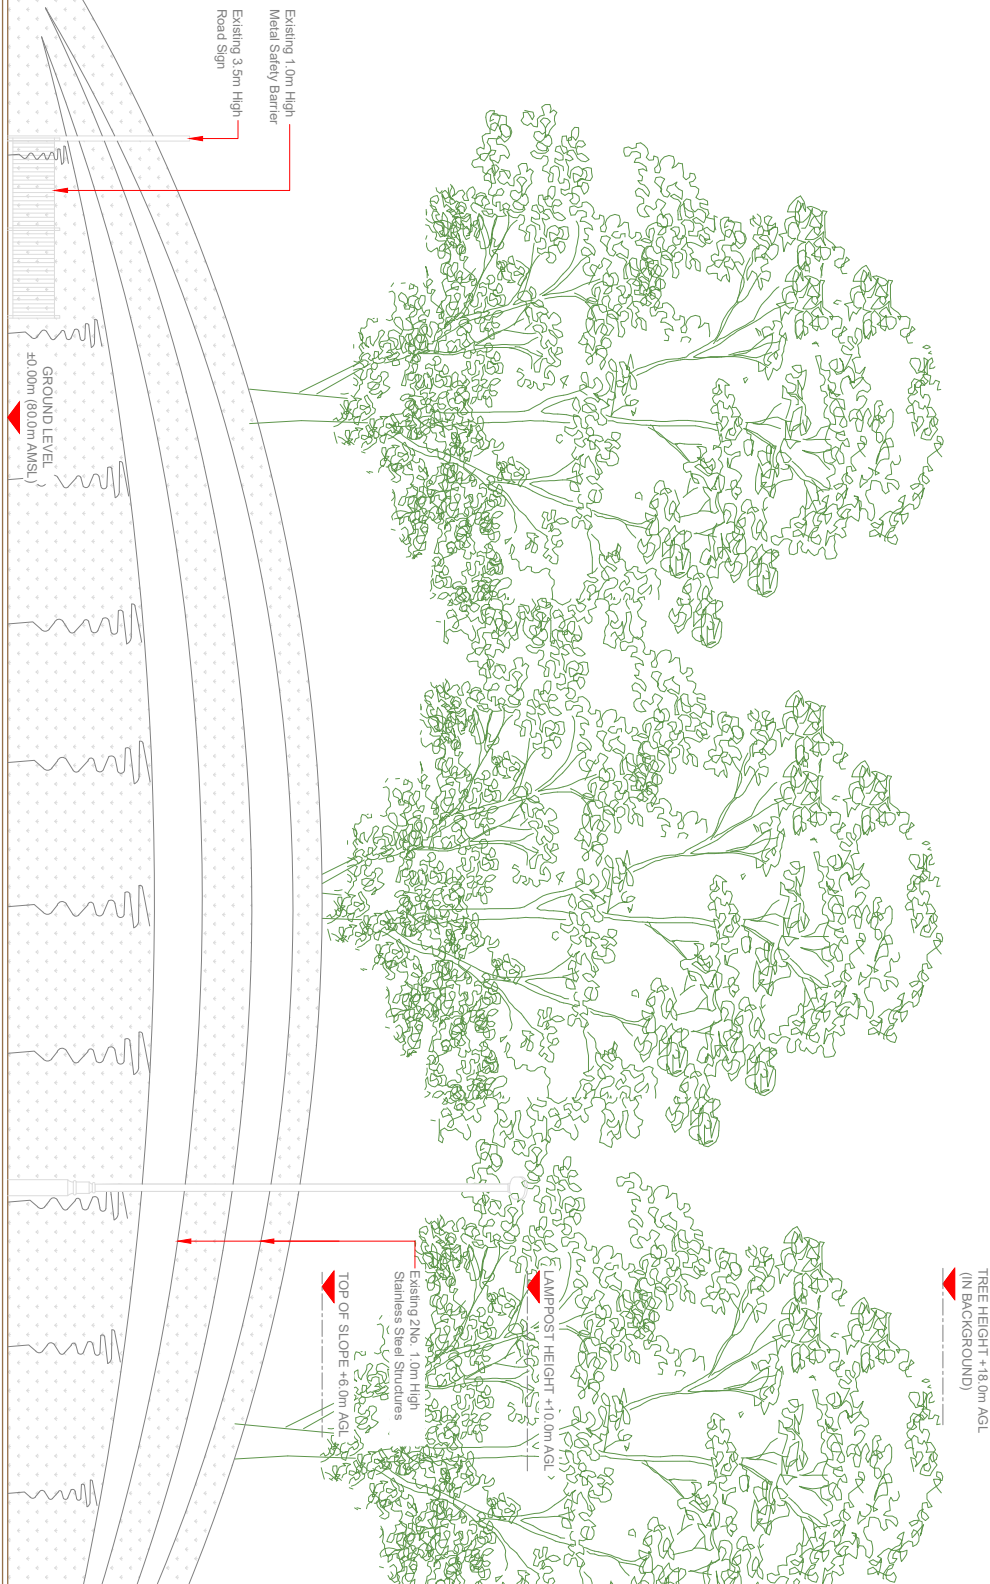

EXISTING SITE ELEVATION
0 1:100 2m 4

Revision	Description	Author	Check	Date
M001	H3G DENSIFICATION SW	Planning	A	
02/03/2023	Revision 1: Design to Construction	D. Warriner		
01/03/2023	First Issue - Site Information dated: 19/03/2023	D. Warriner		

Hutchison 3G UK Limited
Green Park, 450 Longwalk Avenue
Reading, RG30 3JR
Tel: 01628 785 500
Fax: 01628 785 501

3G Data Station Information line:
0045040000
Available 24x7x24 Monday to Friday

CLARKE telecom
Unit E, Madison Place Northampton Road,
Reading, RG30 3JR
Tel: 01628 785 4500 Fax: 01628 785 4501
Web: www.clarke-telecom.com

Design Consultant & Principal Contractor:

Site Name:	ST. GILES WAY
Site ID:	WRX26710

Address:	ST. GILES WAY HIGHTOWN OFFA WREXHAM LL13 7AD
----------	--

Title:	150 EXISTING H3G ELEVATION
Project:	H3G DENSIFICATION STREETWORKS

Project of Issue:	PLANNING
MARU Code ID:	3.0K Code ID
WRX067	LL0691

Master Drawing No:	WRX26710_M001_H3G_DNSW_GA	Issue:	A
--------------------	---------------------------	--------	---

[illegible]


Chairman	Member	Project	Purpose of Issue	Status
	M001	H3G	DENSIFICATION SW	Planning
	D001	02/03/2023	Openwork / Approval Date: open	A
	Chairman	D Warren	First Issue - Site nomination dated: TBC	
	Chairman	D Fildhouse		
	Approved	G Thomas		

Hutchison 3G UK Limited
Green Park, 450 Longwater Avenue
Reading, RG30 3UR
Tel: 01628 765 000
Fax: 01628 765 001

H3G Base Station Information line:
0845 6043000
Available 8am-8pm Monday to Friday

CLARKE
telecom
Unit E, Madison Place, Northampton Road,
Mancaster, MA0 5AG
Tel: 0161 785 4500 Fax: 0161 785 4501
Web: www.clarke-telecom.com

Site Name	ST. GILES WAY		
Site ID	WRX26710		
Address:	ST. GILES WAY HIGHTOWN OFFA WREXHAM LL13 7AD		
Title	210 PROPOSED H3G SITE PLAN		
Project	H3G DENSIFICATION STREETWORKS		
Purpose of Issue	PLANNING		
Drawn By	THB/CALB	TRG/CALB	
Drawn Drawing No.	WRX067	LL0691	
Issue			A

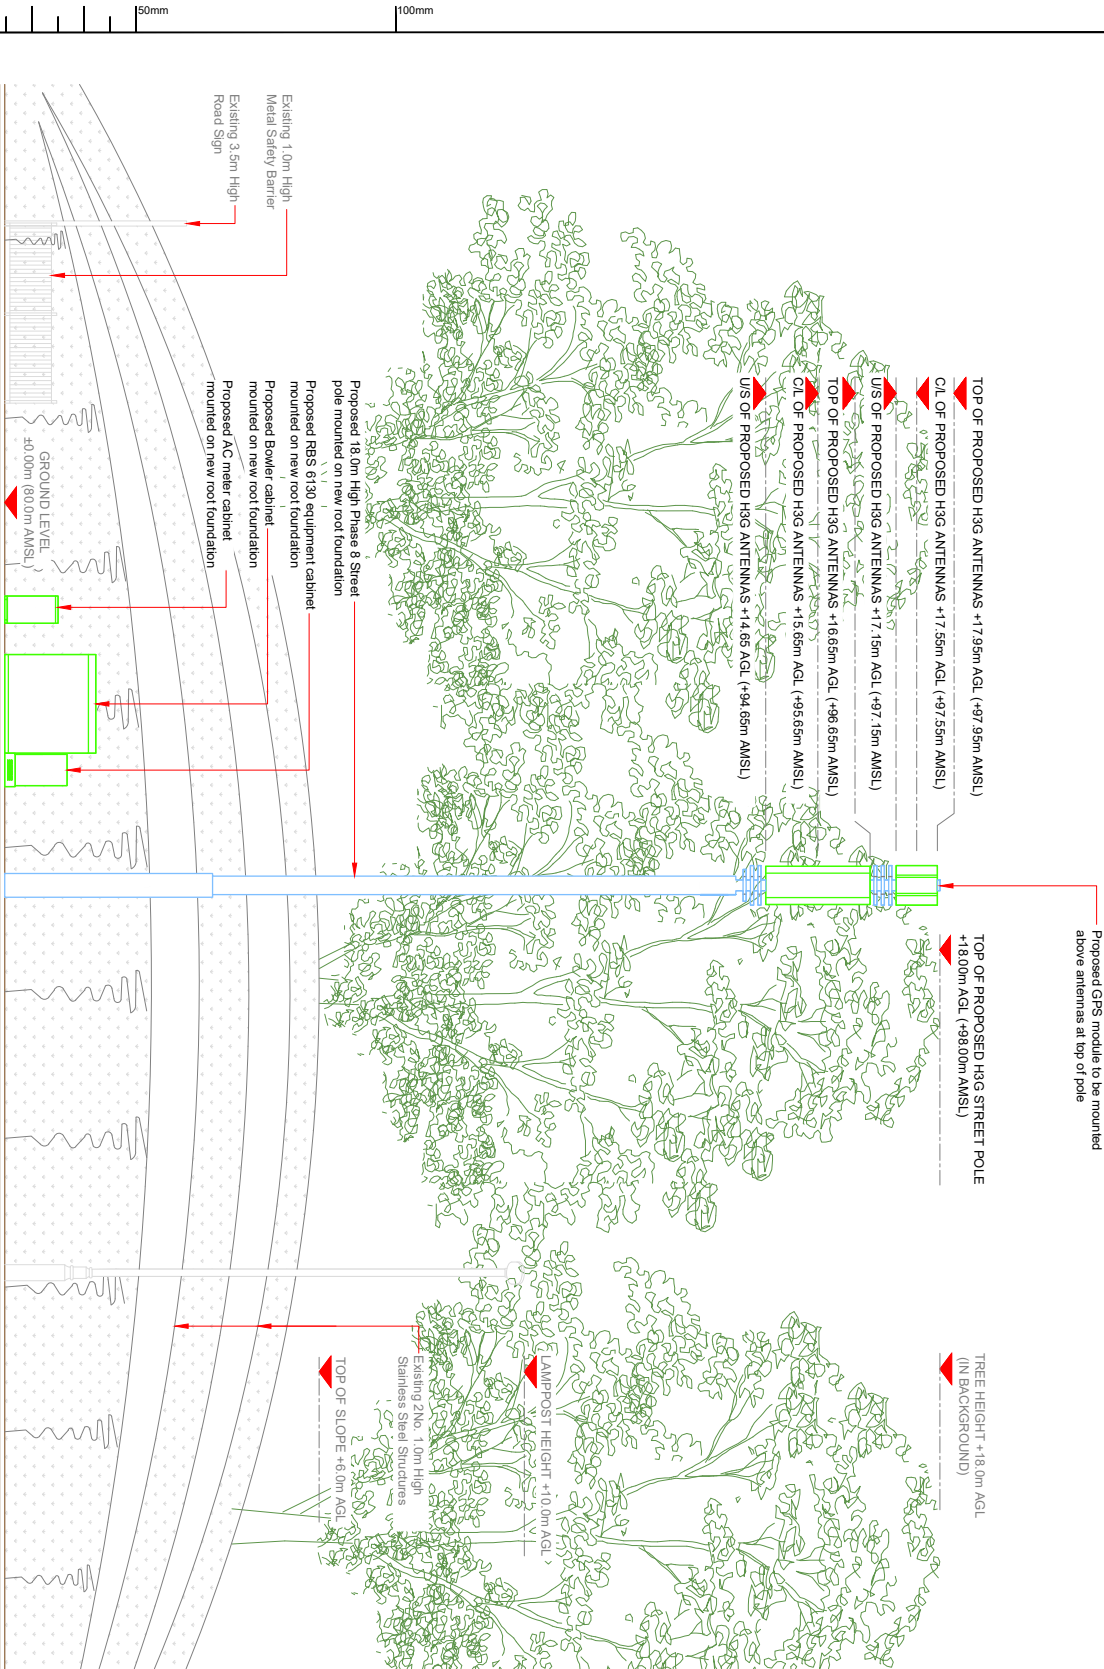

PROPOSED SITE ELEVATION

NOTES

1. ALL DIMENSIONS IN MM UNLESS OTHERWISE NOTED.

Item	Code	Project	Revision	Issue
M001	H3G	DENSIFICATION SW	Planning	A
02/03/2023	02/03/2023	Revision 1 (Design to Construction)		
02/03/2023	02/03/2023	First Issue - Site Information dated: 18/03/2023		
02/03/2023	02/03/2023			



Hutchison 3G UK Limited
Green Park, 450 Longway Avenue
Reading, RG2 3JR
Tel: 01628 785 500
Fax: 01628 785 501

H3G Base Station Information line:
0845 6040000
Available 24/7/365 Monday to Friday

Design Consultant & Principal Contractor:



Unit E, Madison Place, Northampton Road,
Tel: 0161 785 4500 Fax: 0161 785 4501
Web: www.clarke-telecom.com

Site Name: ST. GILES WAY

Site ID: WRX26710

Address:

ST. GILES WAY
HIGHTOWN
OFFA
WREXHAM
LL13 7AD

Title: 260 PROPOSED H3G ELEVATION

Project: H3G DENSIFICATION STREETWORKS

Proposed at Issue:

PLANNING

MARU CAD ID

WRX067

3/AK CAD ID

LL0691

Master Drawing No:

WRX26710_M001_H3G_DNSW_GA

Issue:

A