


SYMBOL/TAG REFERENCE NUMBER
M01 = MECHANICAL PENETRATION
E01 = ELECTRICAL PENETRATION
P01 = PLUMBING PENETRATION
C01 = COMBINED PENETRATION 01

SERVICES REFERENCE
C = COMBINED SERVICES
M = MECHANICAL
E = ELECTRICAL
D = DRAINAGE
W = WATER
CD= CONDENSATE DRAIN



LOCATION REFERENCE
B = BEAM
S = SLAB
W = WALL

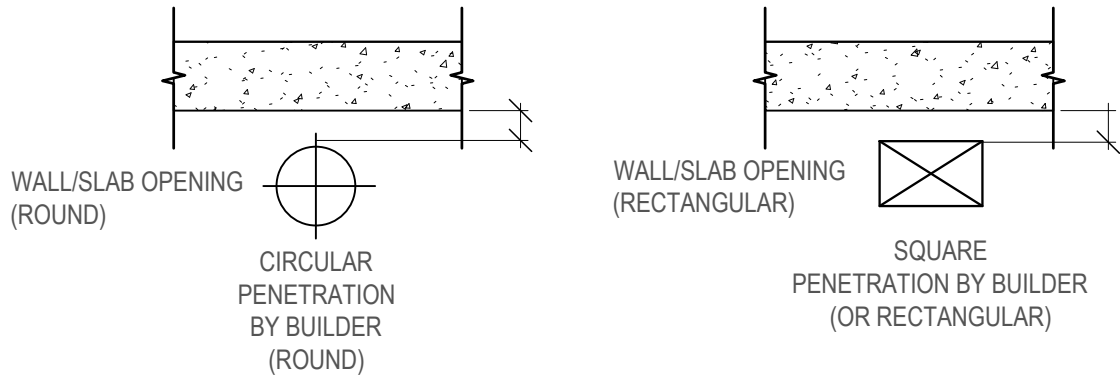

- BUILDERS WORK NOTES**
- 1.THIS MEP BUILDERS WORK DRAWING DEMONSTRATES THE DESIGN INTENT OF BUILDING SERVICES THAT PASS THROUGH THE SLABS / WALLS. THIS DRAWING SHALL BE USED FOR INFORMATION PURPOSES ONLY AND HAS BEEN DEVELOPED TO ASSIST THE MAIN CONTRACTOR IN SETTING-OUT OF EACH PENETRATION.
 - 2.THE STRUCTURAL ENGINEER IS RESPONSIBLE FOR ENSURING THE MEP PENETRATIONS DO NOT ADVERSELY AFFECT THE STRUCTURAL INTEGRITY OF THE BUILDING.
 - 3.SHOULD A CHANGE IN OPENING POSITION BE REQUIRED, IT SHALL BE BROUGHT TO IMMEDIATE ATTENTION TO 79GROUP FOR REVIEW, COMMENTS AND CO-ORDINATION.
 - 4.IT SHALL BE THE RESPONSIBILITY OF THE MAIN CONTRACTOR TO PROVIDE ALL THE REQUIRED OPENINGS AS INDICATED ON THIS DRAWING AND ENSURE ALL PENETRATIONS ARE CORRECTLY POSITIONED AS SCHEDULED.
 - 5.IF THE MAIN CONTRACTOR IS UNSURE OF ANY PENETRATION SIZE OR POSITION SHOWN, THEY SHOULD SEEK THE ASSISTANCE FROM THE MEP CONTRACTOR (79GROUP) FOR CLARIFICATION.
 - 6.ALL DIMENSIONS SHOWN ARE IN MILLIMETERS. USE THE INDICATED DIMENSIONS WITHIN THE SCHEDULE ONLY FOR SETTING OUT OF ALL BUILDERS WORK PENETRATIONS. DO NOT SCALE FROM THIS DRAWING UNDER ANY CIRCUMSTANCES.
 - 7.THIS DRAWING SHALL BE READ IN CONJUNCTION WITH ALL SUPPORTING MEP BUILDERS WORK AND SERVICES DRAWINGS.
 - 8.FINAL LOCATION OF FLOOR DRAINS ARE SUBJECT TO RECEIPT OF FINAL TILING LAYOUT.
 - 9.ANY CIVIL WORK FOR CHAMBERS, SUMP PITS, MANHOLES, SAND TRAPS, TRENCHES, GULLY TRAPS, COVERS & ASSOCIATED BUILDERS WORK ARE BY CIVIL CONTRACTOR.

P02

BUILDERS WORK ELECTRICAL SCHEDULE SECOND FLOOR				
TAG REF.	DESCRIPTION	HEIGHT	WIDTH	DIAMETER
E20	25Ø CONDUIT			50Ø
E21	25Ø CONDUIT			50Ø
E22	25Ø CONDUIT			50Ø
E23	25Ø CONDUIT			50Ø
C01	x4 AC PIPE & TRUNKING	50	100	200Ø

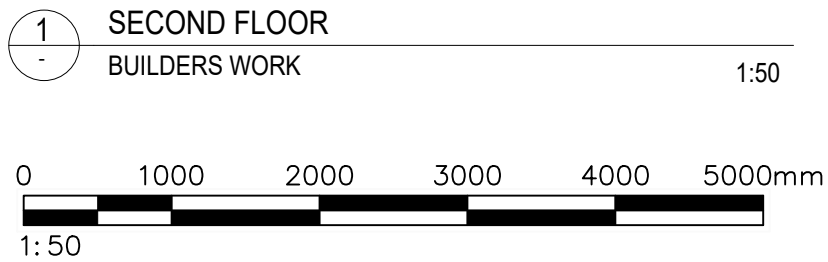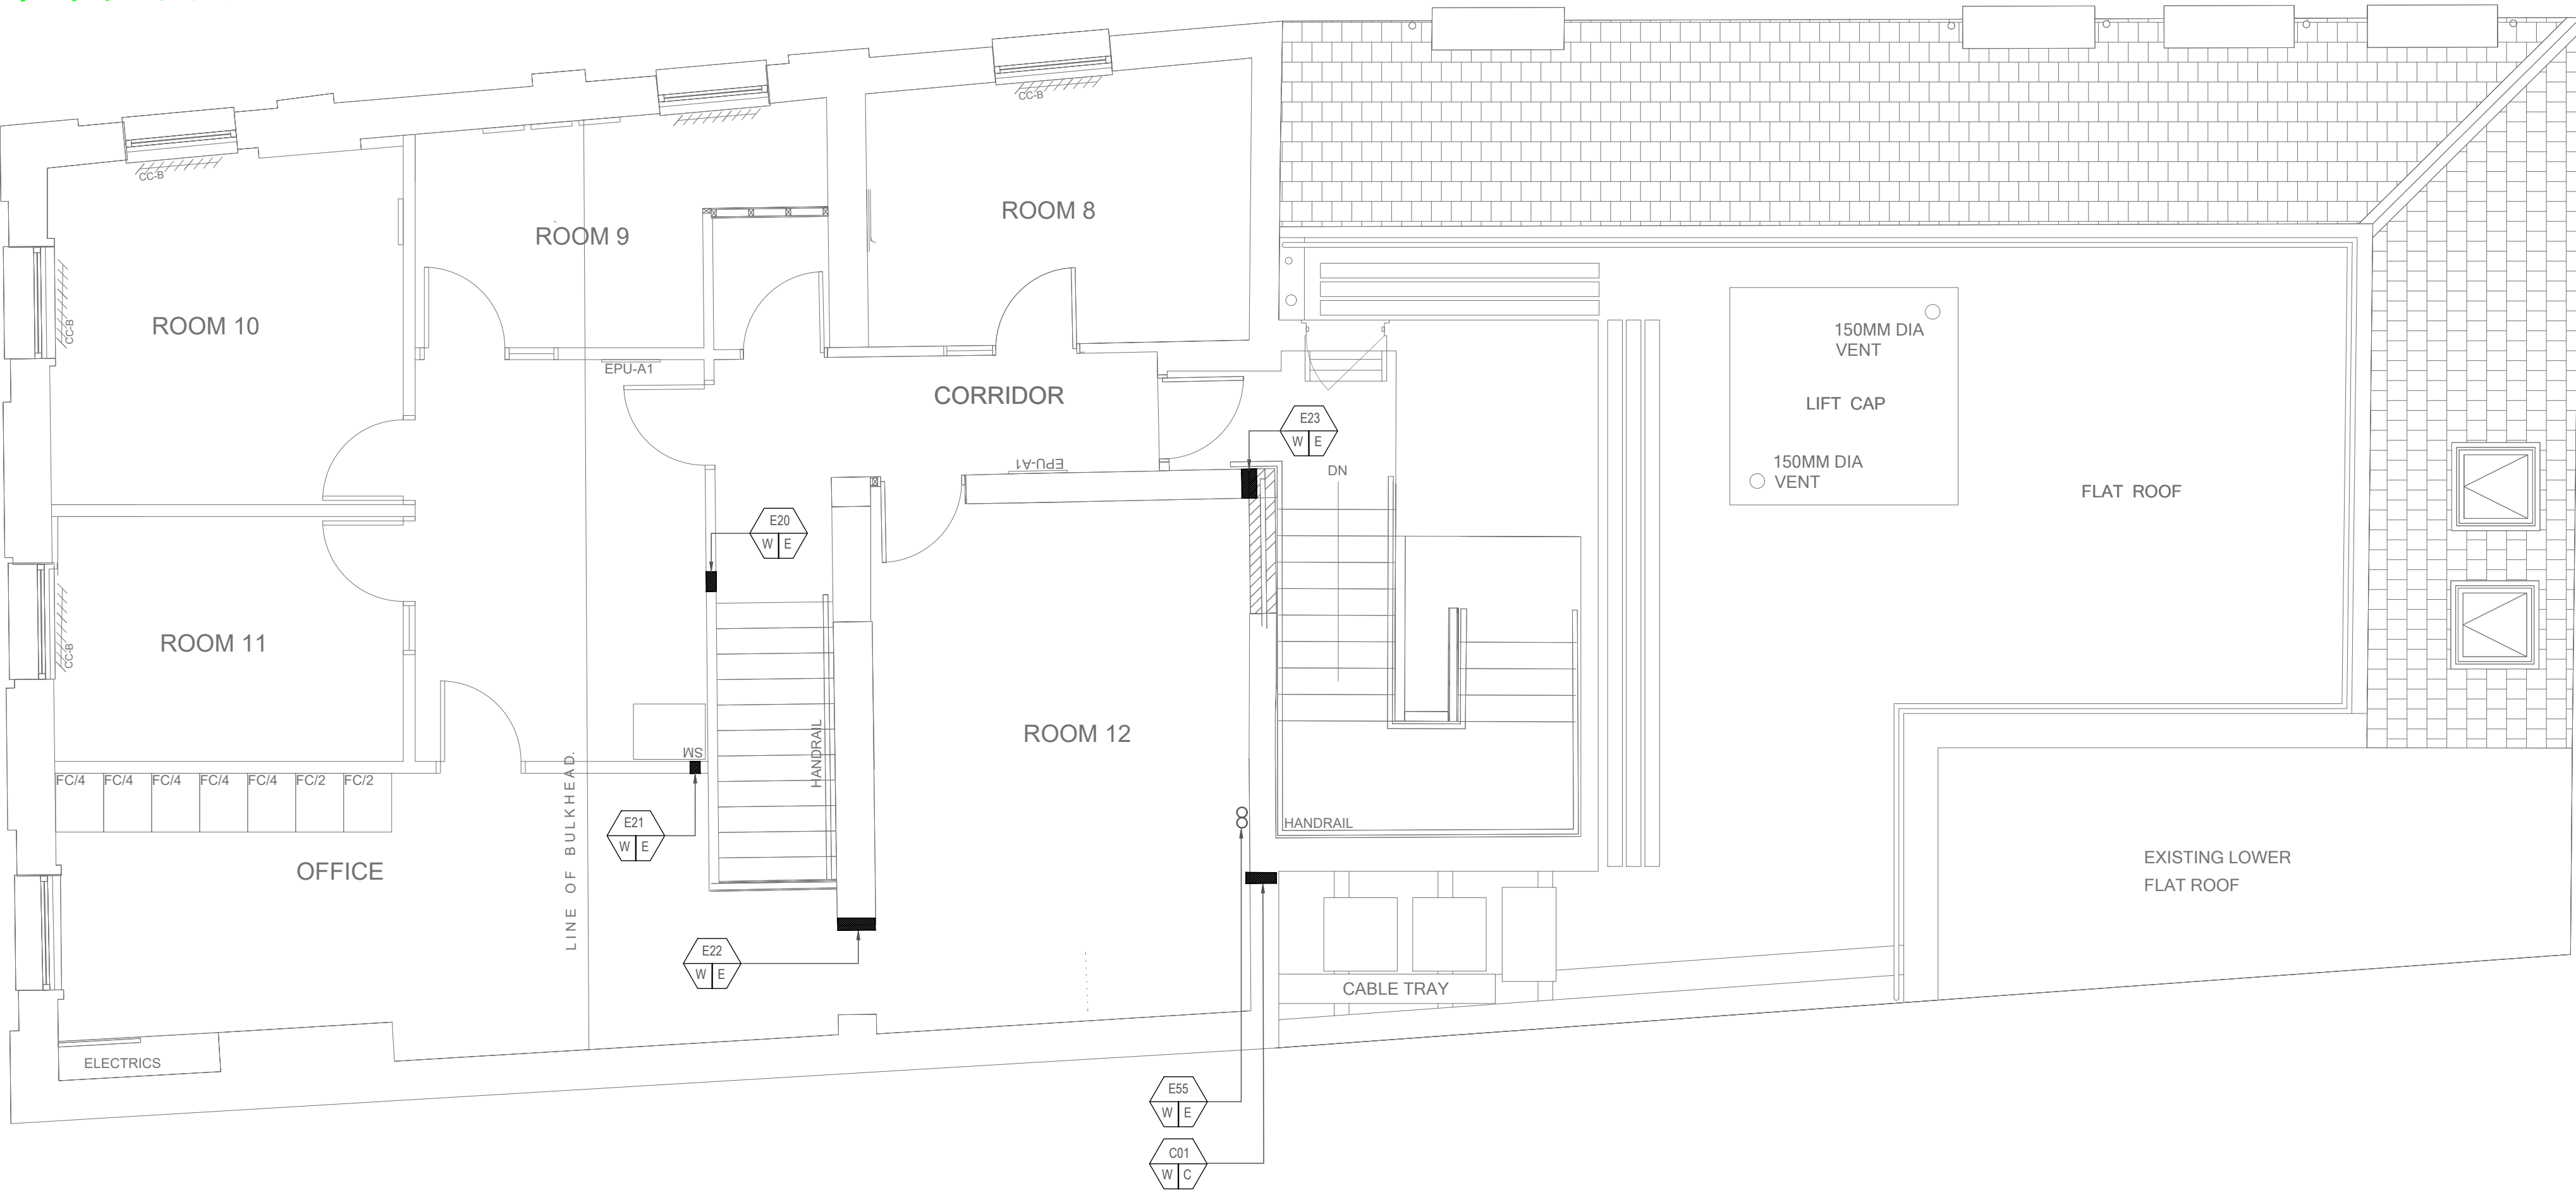

P02	24.03.23	REVISED CP	AA	MC
P01	25.11.22	FIRST ISSUE	AA	MC
Rev	Date	Revision Notes	BY	CH
Client: LLOYDS BANKING GROUP				
Project: HALIFAX WREXHAM HOPE STREET 55 HOPE STREET WREXHAM LL11 1AF				
Status: PRELIMINARY				
All dimensions in mm except where otherwise stated. Dimensions up to 1 metre +/- 0.5mm. Dimensions 1 metre to 5 metres +/- 1mm. Except where otherwise stated. © Copyright drawing.				



Drawing Title: SECOND FLOOR BUILDERS WORK			
Drawing No. 50960570-79G-RD-02-M2-ME-2602		Revision No. P02	
Drawn: AA	Checked: MC	Scale @A1: 1:50	Originated Date: 18.11.22