
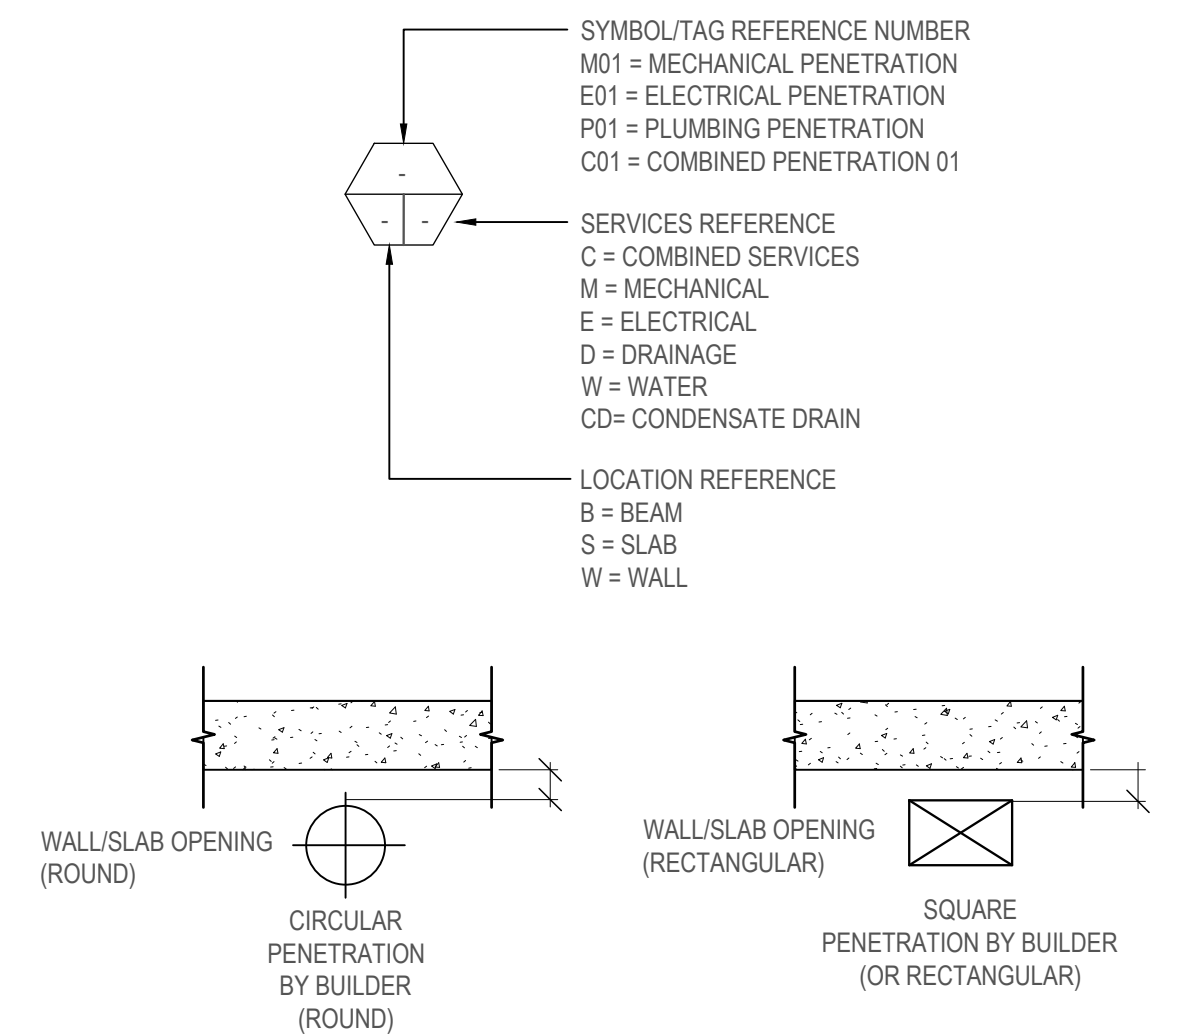
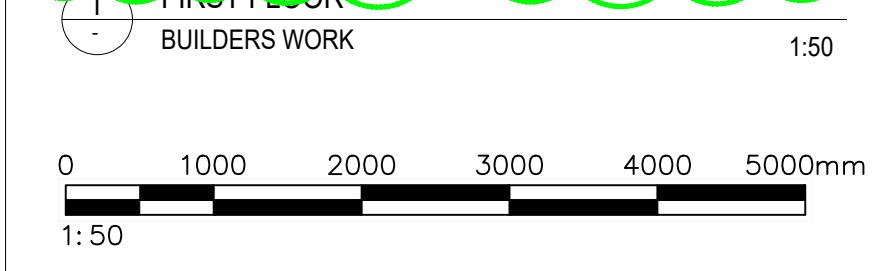


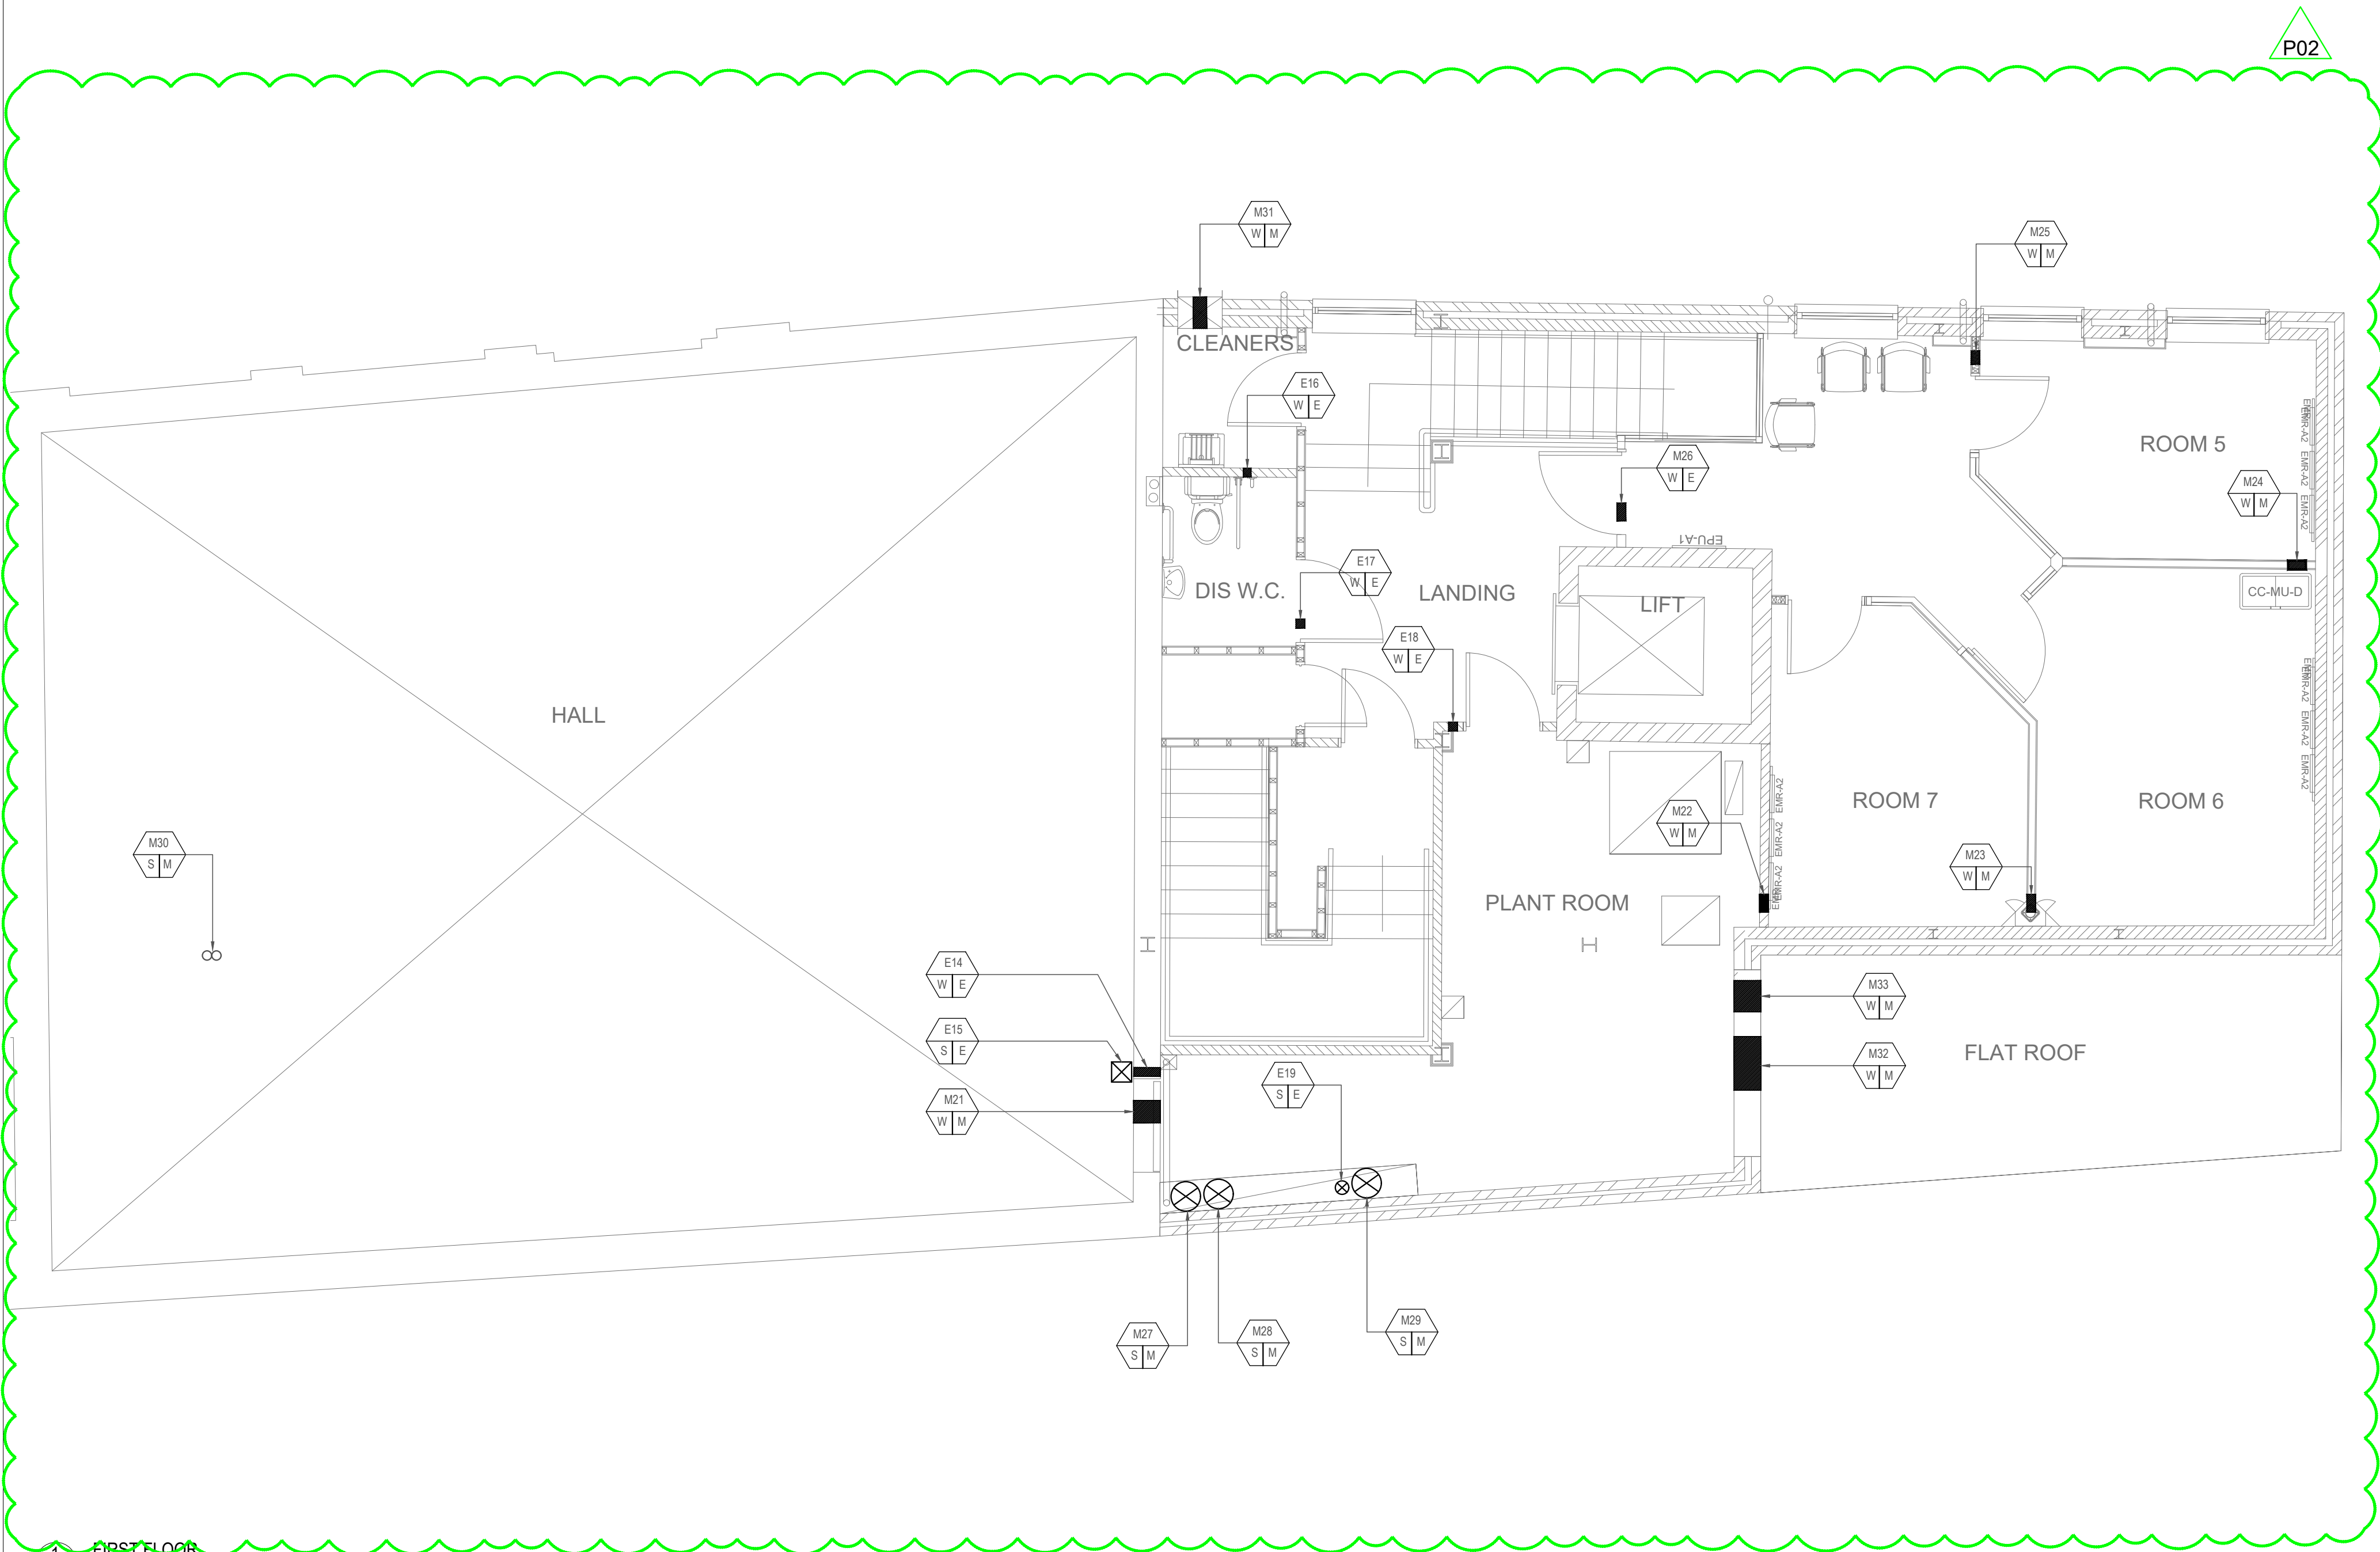

- BUILDERS WORK NOTES**
- 1.THIS MEP BUILDERS WORK DRAWING DEMONSTRATES THE DESIGN INTENT OF BUILDING SERVICES THAT PASS THROUGH THE SLABS / WALLS. THIS DRAWING SHALL BE USED FOR INFORMATION PURPOSES ONLY AND HAS BEEN DEVELOPED TO ASSIST THE MAIN CONTRACTOR IN SETTING-OUT OF EACH PENETRATION.
 - 2.THE STRUCTURAL ENGINEER IS RESPONSIBLE FOR ENSURING THE MEP PENETRATIONS DO NOT ADVERSELY AFFECT THE STRUCTURAL INTEGRITY OF THE BUILDING.
 - 3.SHOULD A CHANGE IN OPENING POSITION BE REQUIRED, IT SHALL BE BROUGHT TO IMMEDIATE ATTENTION TO 79GROUP FOR REVIEW, COMMENTS AND CO-ORDINATION.
 - 4.IT SHALL BE THE RESPONSIBILITY OF THE MAIN CONTRACTOR TO PROVIDE ALL THE REQUIRED OPENINGS AS INDICATED ON THIS DRAWING AND ENSURE ALL PENETRATIONS ARE CORRECTLY POSITIONED AS SCHEDULED.
 - 5.IF THE MAIN CONTRACTOR IS UNSURE OF ANY PENETRATION SIZE OR POSITION SHOWN, THEY SHOULD SEEK THE ASSISTANCE FROM THE MEP CONTRACTOR (79GROUP) FOR CLARIFICATION.
 - 6.ALL DIMENSIONS SHOWN ARE IN MILLIMETERS. USE THE INDICATED DIMENSIONS WITHIN THE SCHEDULE ONLY FOR SETTING OUT OF ALL BUILDERS WORK PENETRATIONS. DO NOT SCALE FROM THIS DRAWING UNDER ANY CIRCUMSTANCES.
 - 7.THIS DRAWING SHALL BE READ IN CONJUNCTION WITH ALL SUPPORTING MEP BUILDERS WORK AND SERVICES DRAWINGS.
 - 8.FINAL LOCATION OF FLOOR DRAINS ARE SUBJECT TO RECEIPT OF FINAL TILING LAYOUT.
 - 9.ANY CIVIL WORK FOR CHAMBERS, SUMP PITS, MANHOLES, SAND TRAPS, TRENCHES, GULLY TRAPS, COVERS & ASSOCIATED BUILDERS WORK ARE BY CIVIL CONTRACTOR.

BUILDERS WORK ELECTRICAL SCHEDULE FIRST FLOOR				
TAG REF.	DESCRIPTION	HEIGHT	WIDTH	DIAMETER
E14	CABLE TRUNKING	50		
E15	RISER	50		
E16	25Ø CONDUIT			50Ø
E17	CABLE TRUNKING	50	100	
E18	CABLE TRUNKING	50	100	
E19	CABLE TRUNKING	50	100	

BUILDERS WORK MECHANICAL SCHEDULE FIRST FLOOR				
TAG REF.	DESCRIPTION	HEIGHT	WIDTH	DIAMETER
M21	DUCTWORK			300Ø
M22	DUCTWORK			250Ø
M23	DUCTWORK			250Ø
M24	DUCTWORK			250Ø
M25	DUCTWORK			250Ø
M26	DUCTWORK	50	100	200Ø
M27	RISER			350Ø
M28	RISER			350Ø
M29	RISER			350Ø
M30	x2 AC PIPE			100Ø
M31	EXTRACT FAN	315	630	
M32	EXTERNAL LOUVER	250	500	
M33	EXTERNAL LOUVER	200	200	

P02	24.03.22	REVISED CP	AA	MC	
P01	25.11.22	FIRST ISSUE	AA	MC	
Rev	Date	Revision Notes	BY	CH	
Client: LLOYDS BANKING GROUP					
Project: HALIFAX WREXHAM HOPE STREET 55 HOPE STREET WREXHAM LL11 1AF					
Status: PRELIMINARY					
All dimensions in mm except where otherwise stated. Dimensions up to 1 metre +/- 0.5mm. Dimensions 1 metre to 5 metres +/- 1mm. Except where otherwise stated. © Copyright drawing.					



79group
enlightened environments
MEP and Building Services Division

Drawing Title: FIRST FLOOR BUILDERS WORK			
Drawing No. 50960570-79G-RD-01-M2-ME-2602		Revision No. P02	
Drawn: AA	Checked: MC	Scale @A1: 1:50	Originated Date: 18.11.22