


ELECTRICAL LEGEND.

- LOW VOLTAGE DOWNLIGHTER FITTING,
- DOUBLE S/W SOCKET OUTLET (LOW LEVEL)
- ONE WAY S/W

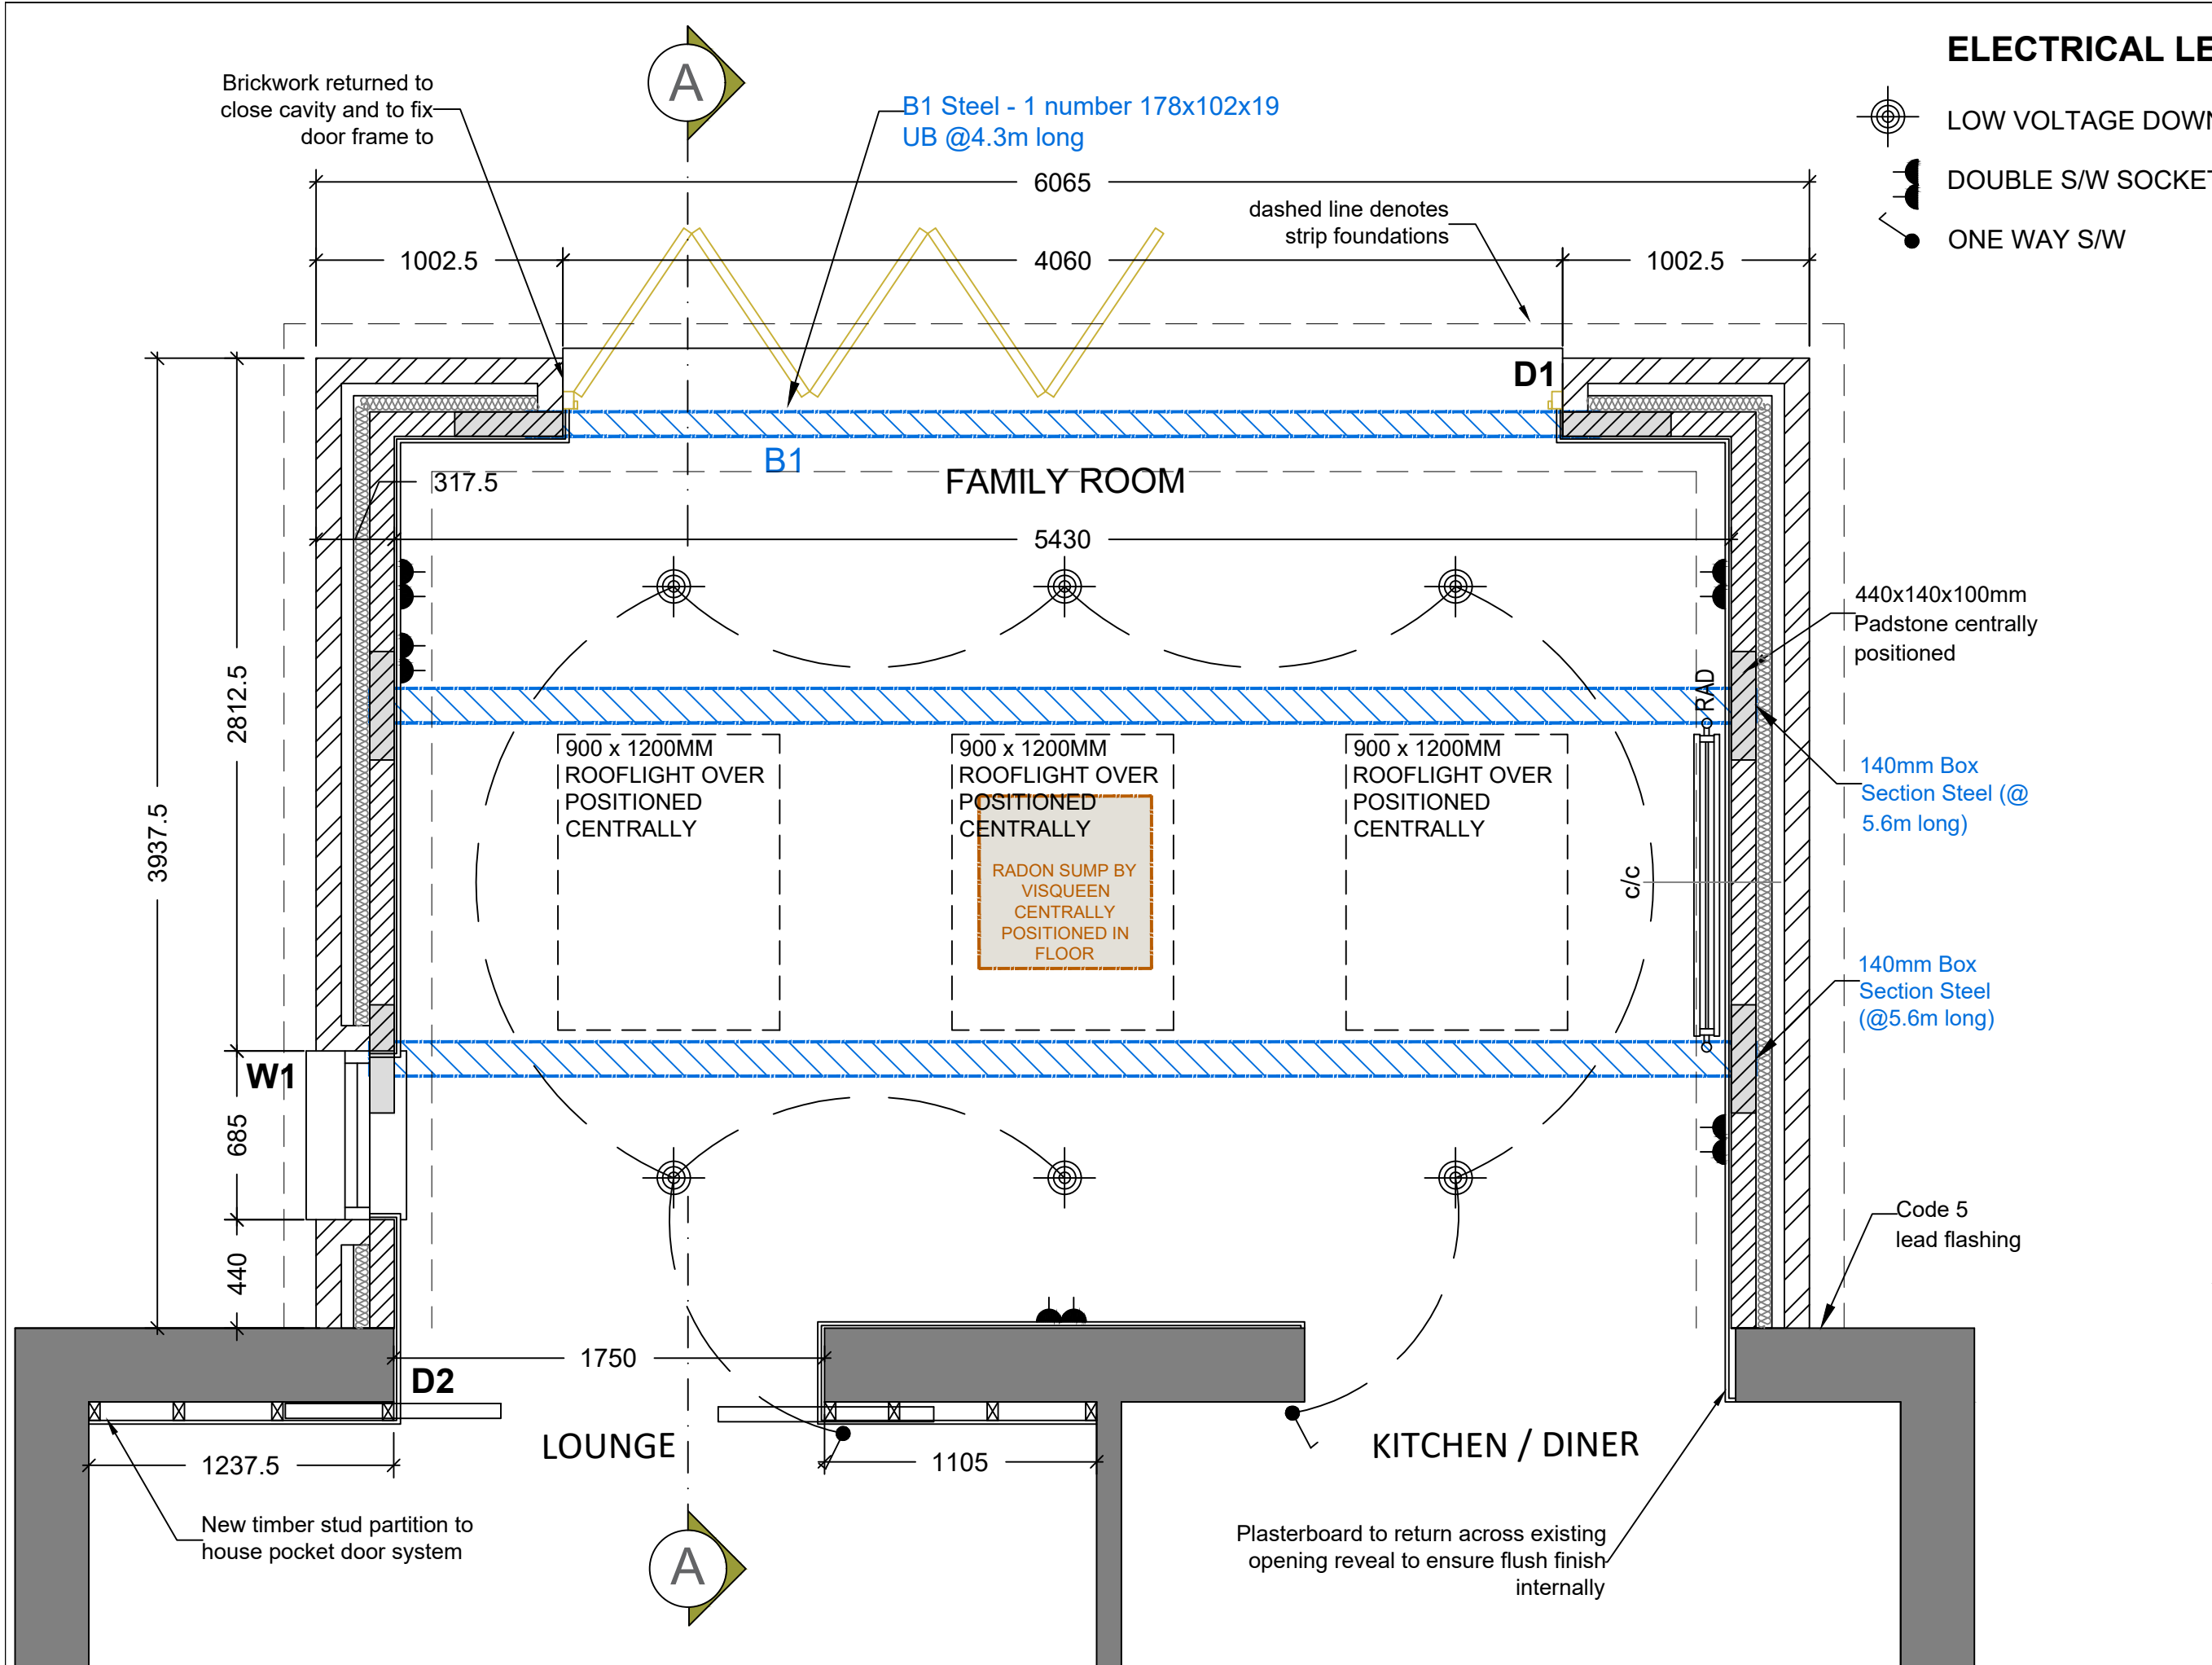

Revision A:
Radiator repositioned to clients request. 03.05.22

CLIENT			
Mr & Mrs Thompson			
PROJECT		PACK VERSION:	
21 Coleman Road		-	
DRAWING TITLE			
Proposed Ground Floor Plan			
FOR CONSTRUCTION			
DRAWN	SP	CHECKED	AP
SCALE	1:25	DRAWING No:	REVISION:
DATE	OCT 21	L(2)04	A

modusdesigns