



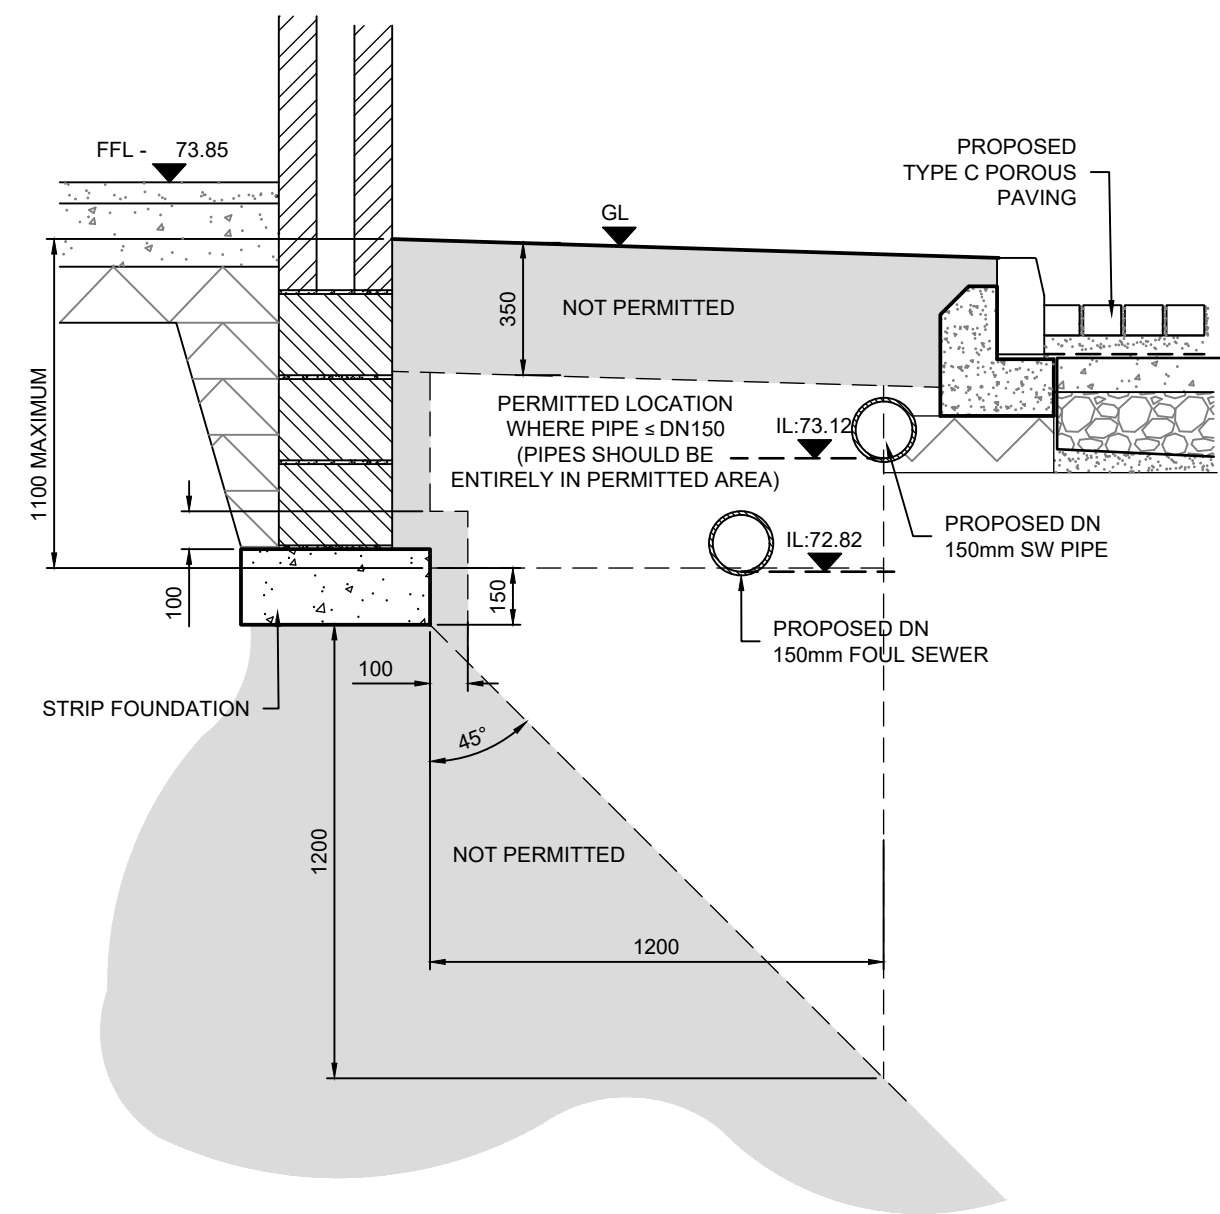


SECTION B-B
NTS

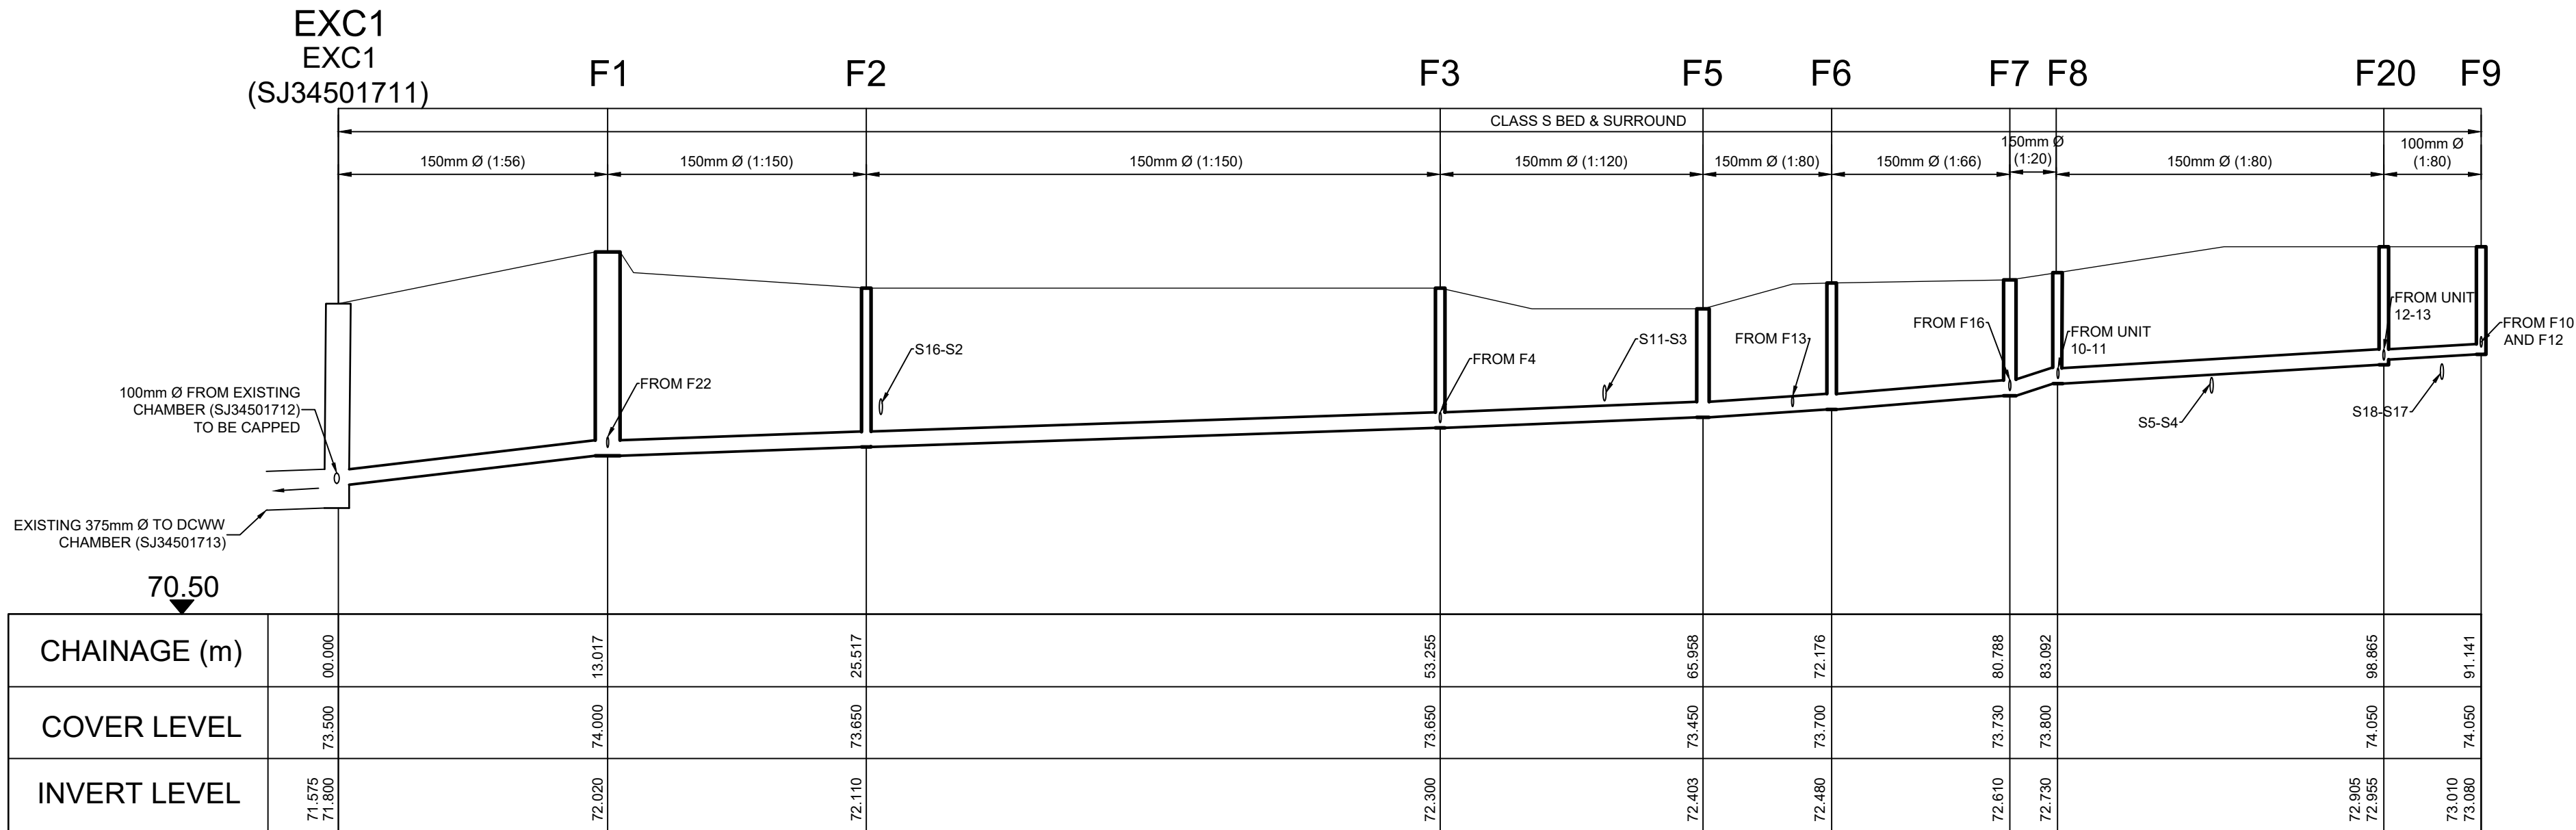


EXC1 COVER AND INVERT LEVELS TO BE CONFIRMED IN ADVANCE OF ANY OTHER WORK

ADOPTABLE FOUL
LONGSECTION FROM F9 TO EXC1
H 1:250 V 1:50

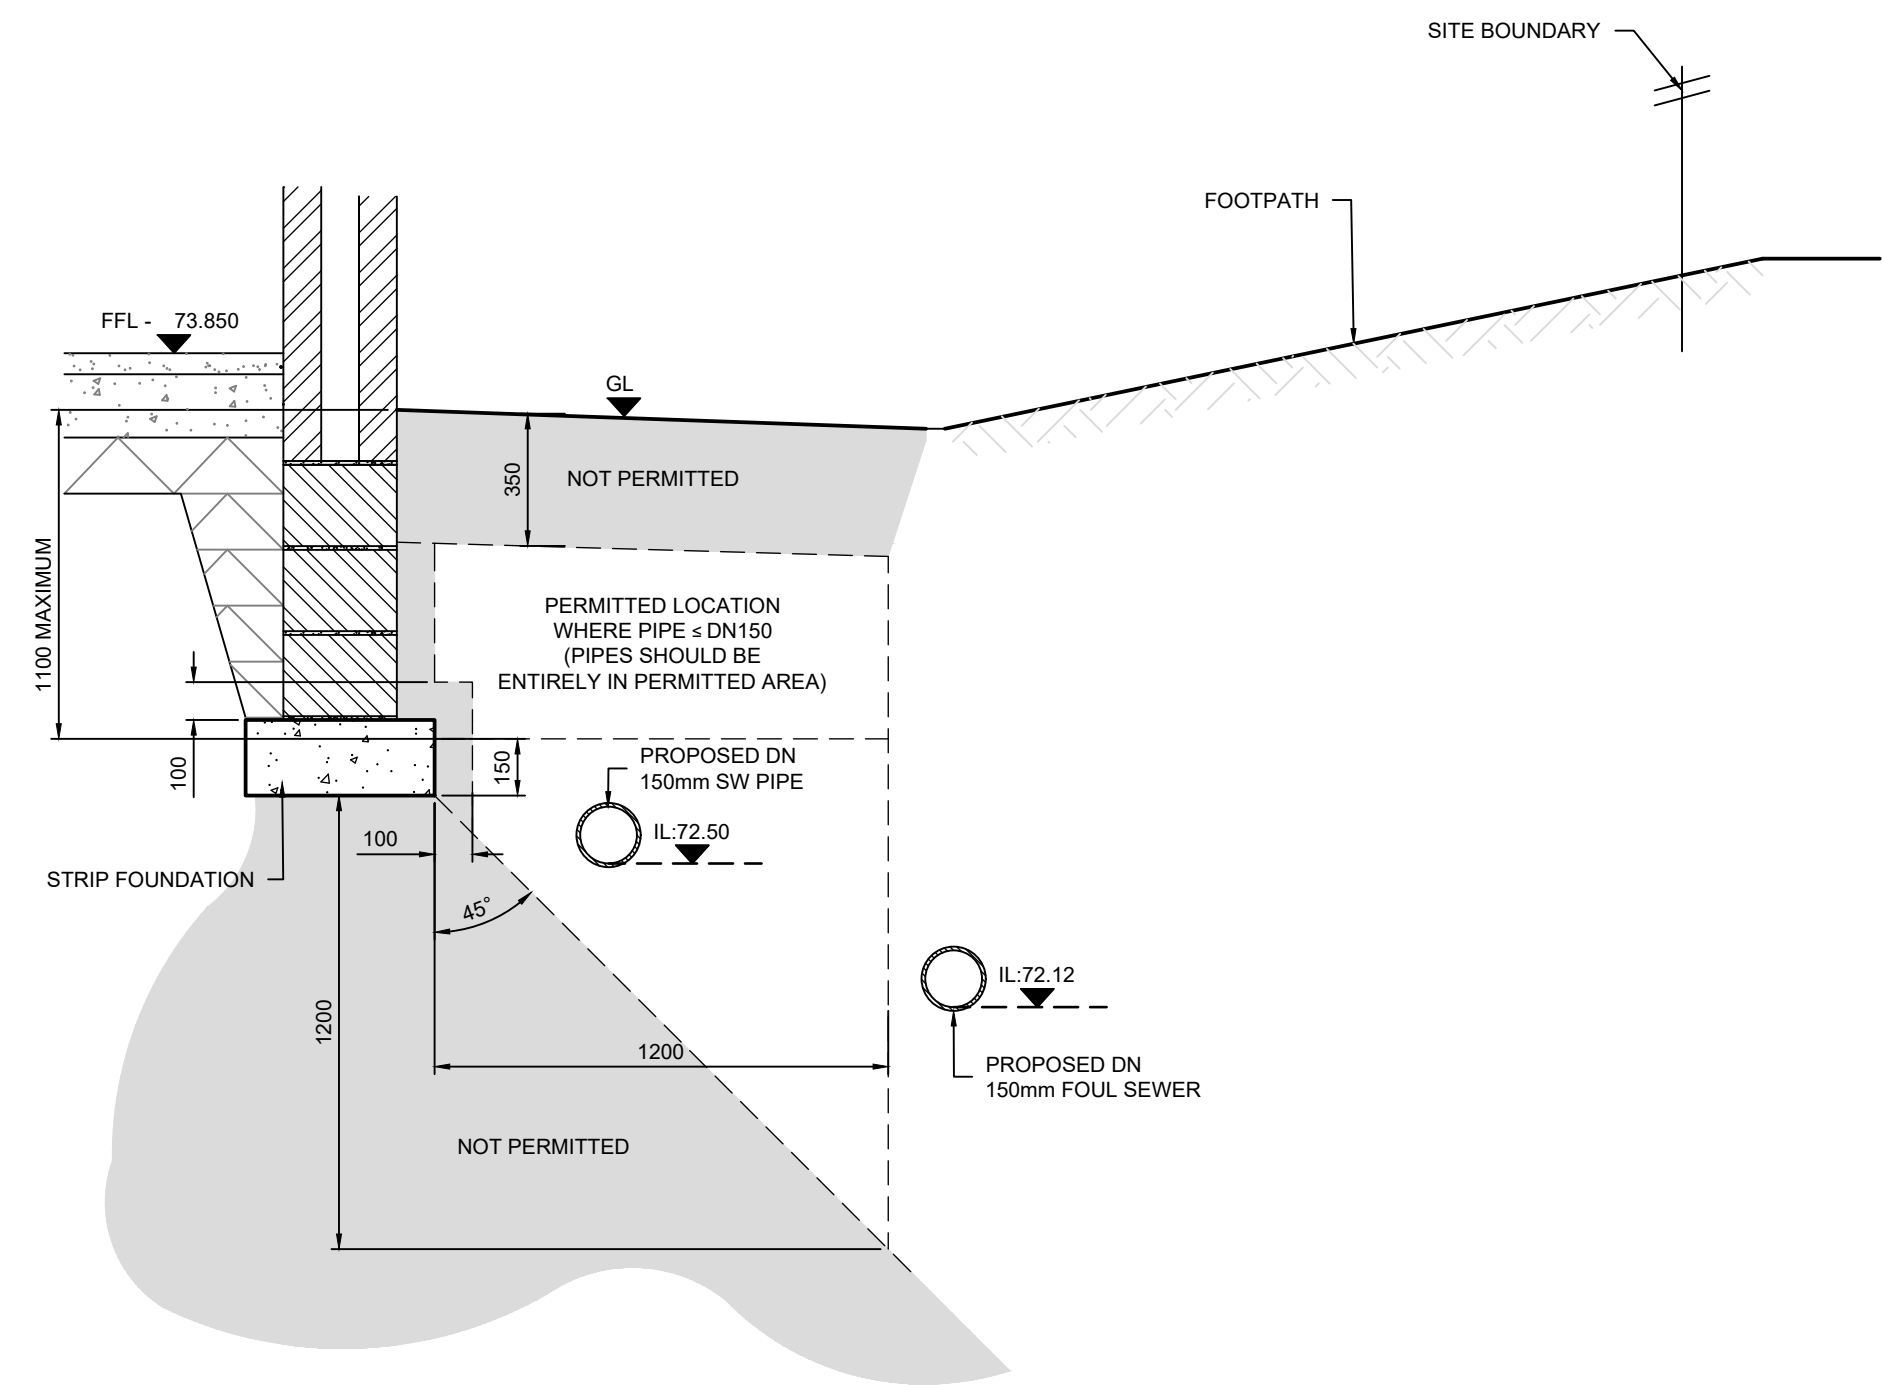

SECTION C-C
NTS

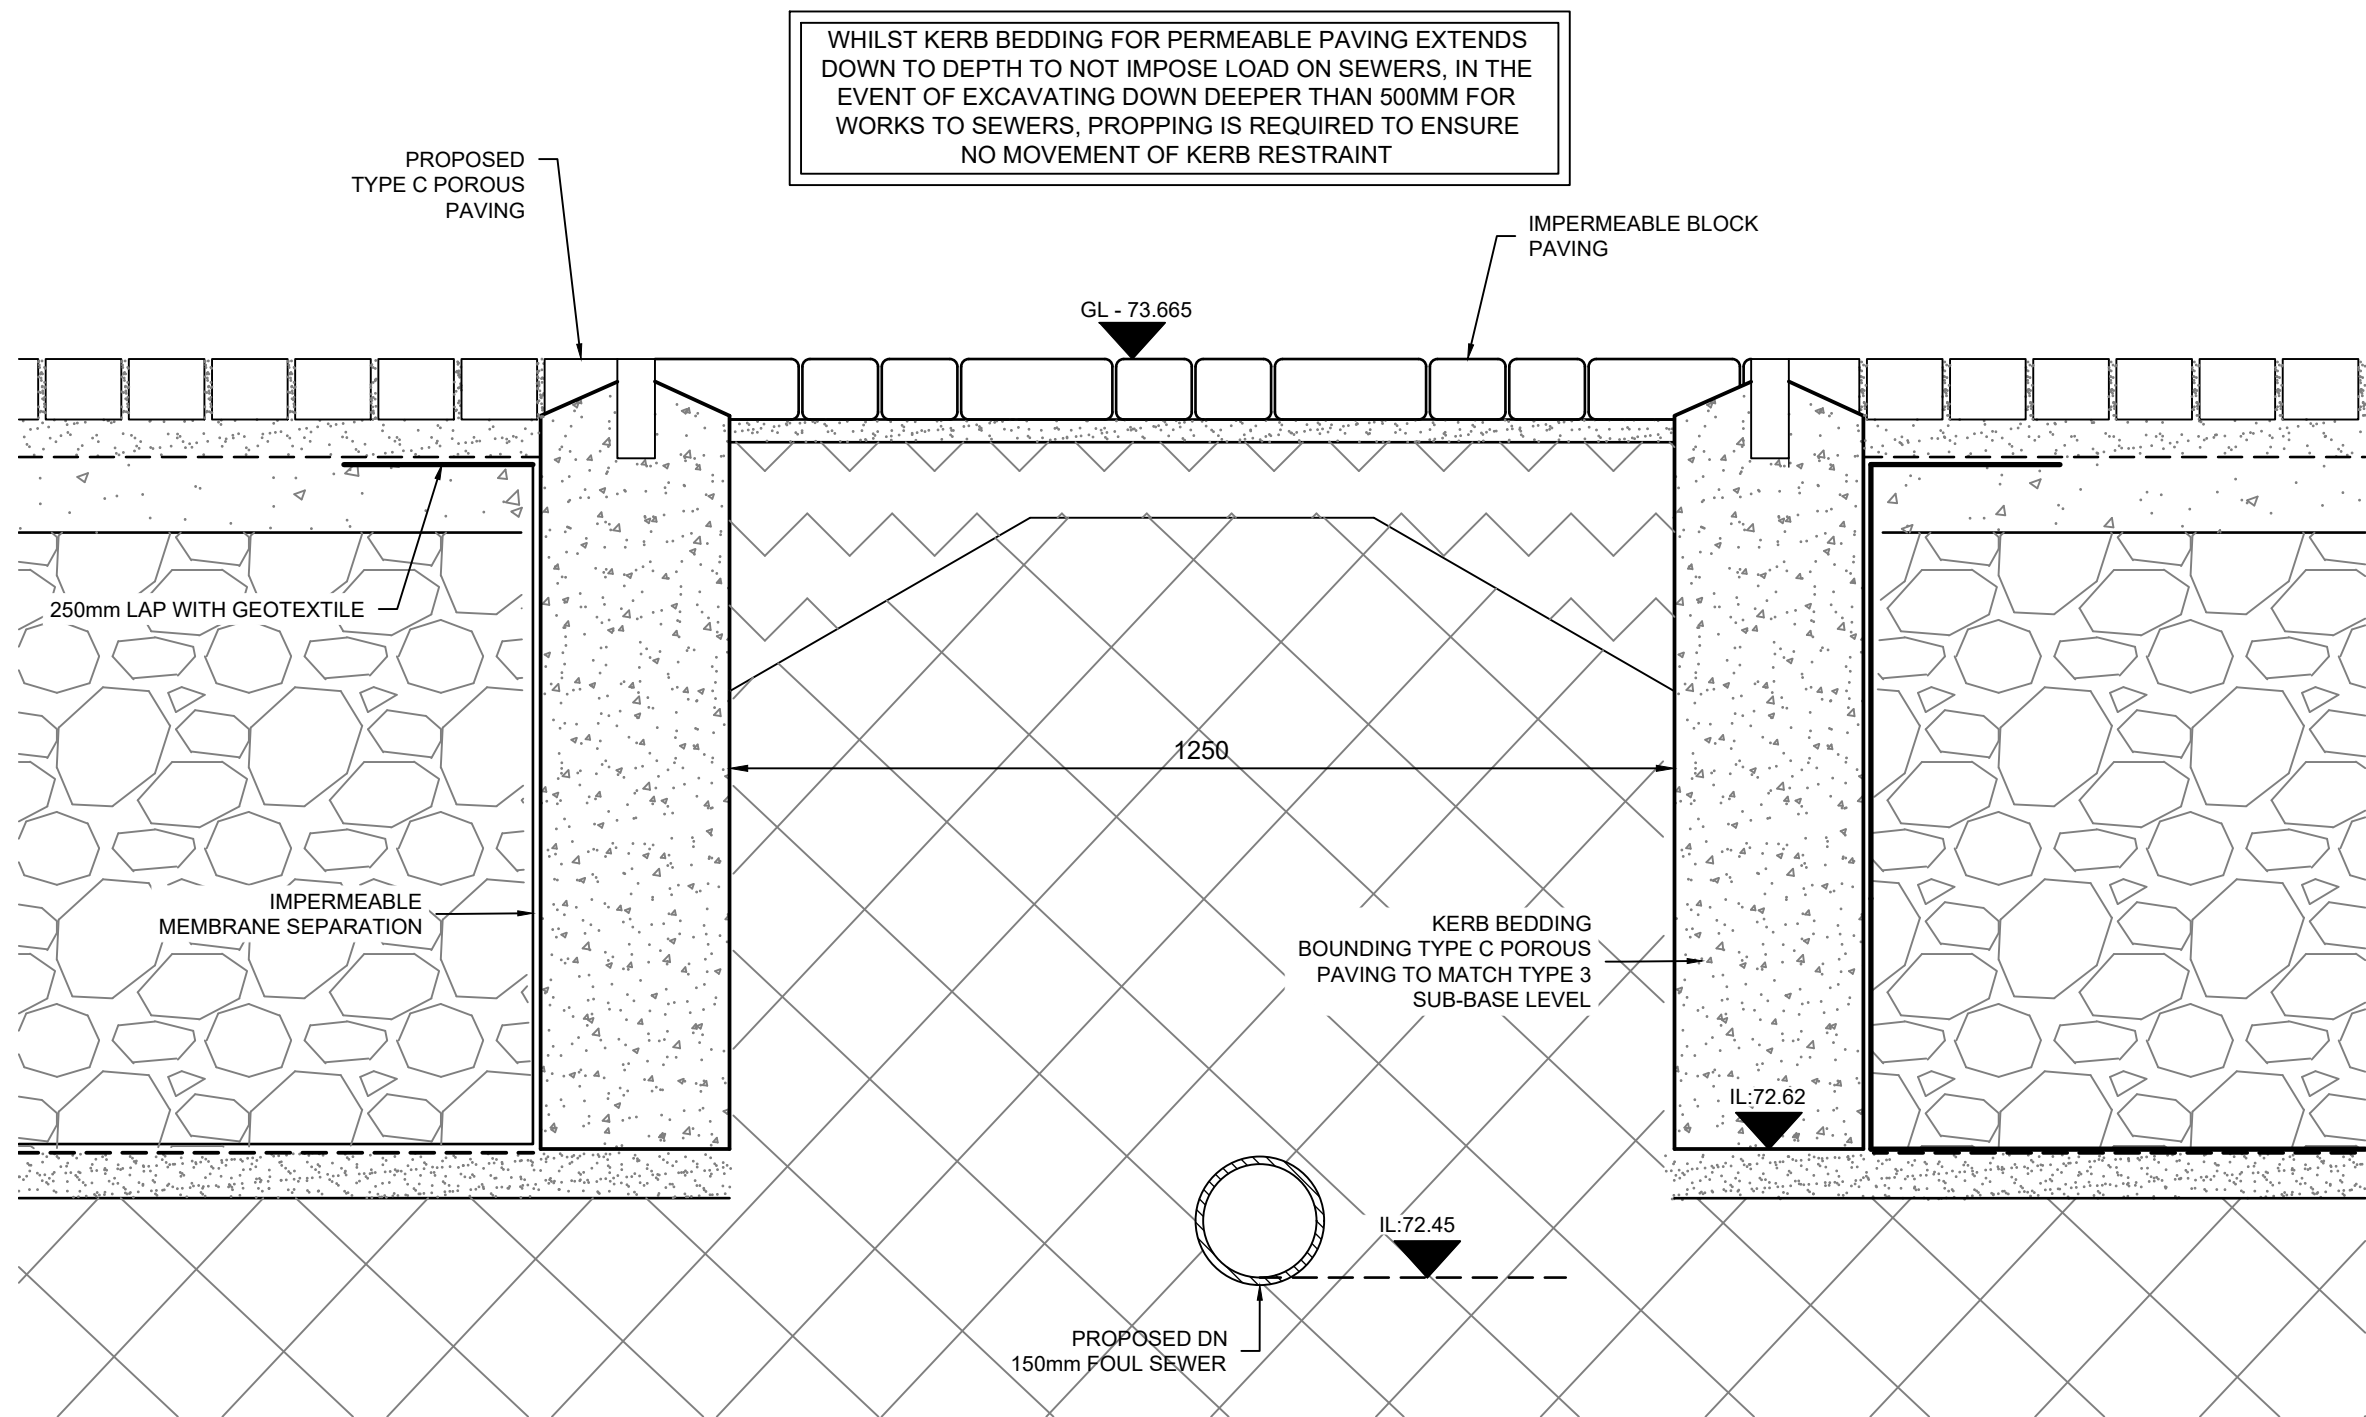

SECTION D-D
1:10

- NOTES
- THIS DRAWING IS TO BE READ IN CONJUNCTION WITH ALL RELEVANT ARCHITECT'S, ENGINEER'S AND OTHER SPECIALISTS' DRAWINGS.
 - PLEASE REFER TO DATRYS DRAWING 20269/S104-1 FOR ADOPTABLE DRAINAGE LAYOUT.
 - AT ALL OUTFALL POINTS TO AN EXISTING NETWORK, THE POSITION AND INVERT LEVEL OF EXISTING DRAINS MUST BE CONFIRMED WELL IN ADVANCE OF THE PROGRAMMED DATE FOR INSTALLING ANY OF THE UPSTREAM DRAINAGE, OR ORDERING ANY MATERIALS IN ORDER TO ALLOW TIME FOR ANY NECESSARY REVISIONS TO THE HYDRAULIC DESIGN.
 - THE DEVELOPER MUST SELF-VET AND CERTIFY THAT THE DESIGN CRITERIA, MATERIAL STANDARDS AND WORKMANSHIP SPECIFICATION FOR THE PROPOSED ADOPTABLE SEWERS ARE IN ACCORDANCE WITH THOSE SET OUT IN SEWERS FOR ADOPTION 7th EDITION AND THE REQUIREMENTS OF DCWW AS THE STATUTORY SEWERAGE UNDERTAKER, AND THE WELSH MINISTERS BUILD STANDARDS

D	20.12.21	LONGSECTION AMENDED	LI	AC	AC
C	15.12.21	AMENDED PER DCWW COMMENTS 03.11.21	LI	AC	AC
B	15.11.21	AMENDED PER DCWW COMMENTS 03.11.21	JP	LI	
A	24.09.21	LONGSECTION AMENDED ACCORDING LAYOUT SECTION B-B AND C-C ADDED	LI	AC	AC
REV	DATE	DESCRIPTION	BY	CHK	APR

REVISIONS

CLIENT

PROJECT

Ty Nos, Holt Road
Wrexham

TITLE

Section104 Adoptable
Foul Longsections

Caernarfon:
Unit 6 Block A, Doc Ffioria
Caernarfon, LL55 1TH
Tel: 01286 671027
Mold:
Unit 4a, Broncoed House
Ffordd Brynwr Gwlad, Mold,
CH7 1HP. Tel: 01352 706205
info@datrys.coop | www.datrys.net

DRAWN JP	CHECKED LI	PASSED AC
DATE 20.07.21	CLIENT'S REF.	
SCALE AT A1 1:250	AUTOCAD REF. 20269/S104-1	
DRAWING No.	20269/S104-2	
	REVISION	D