
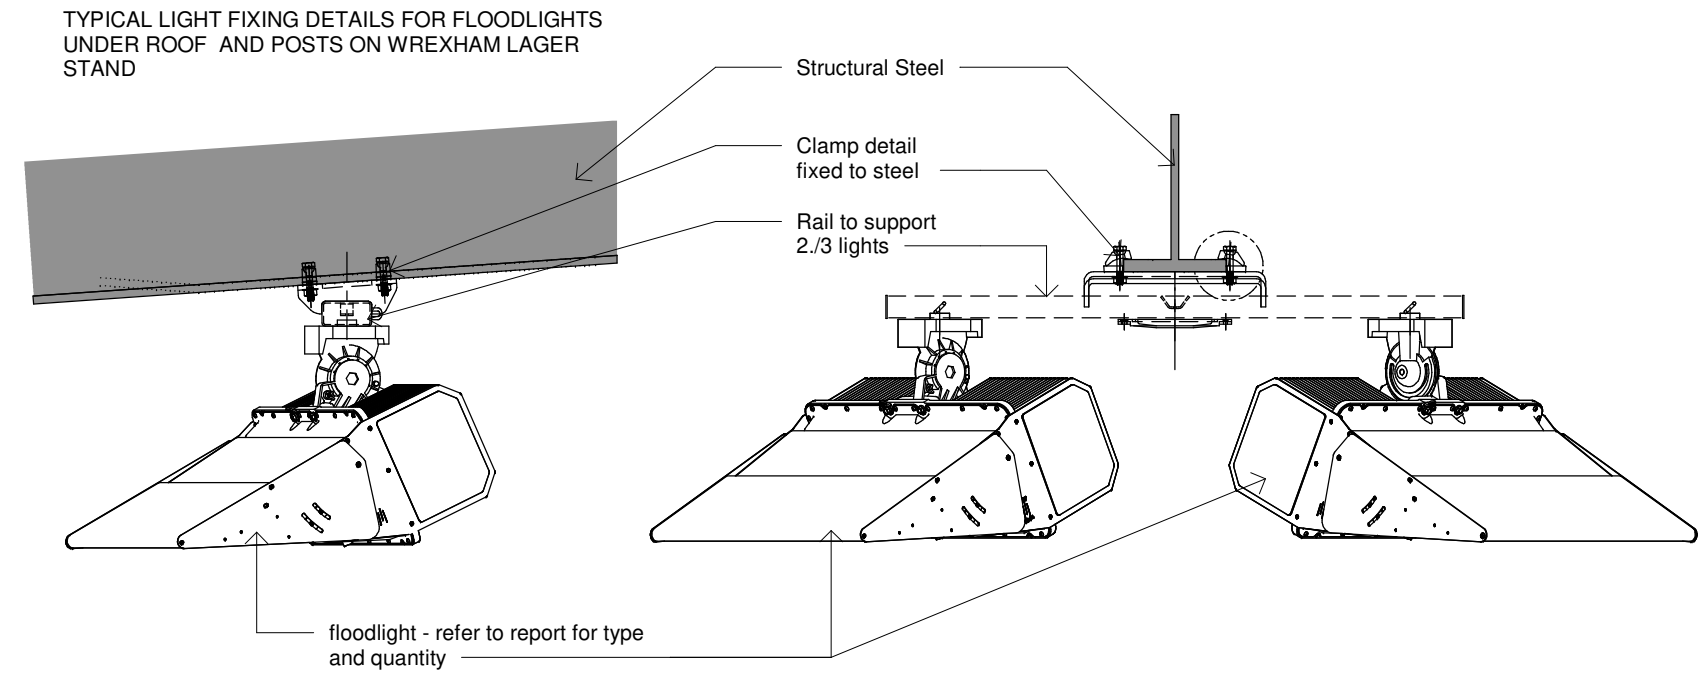
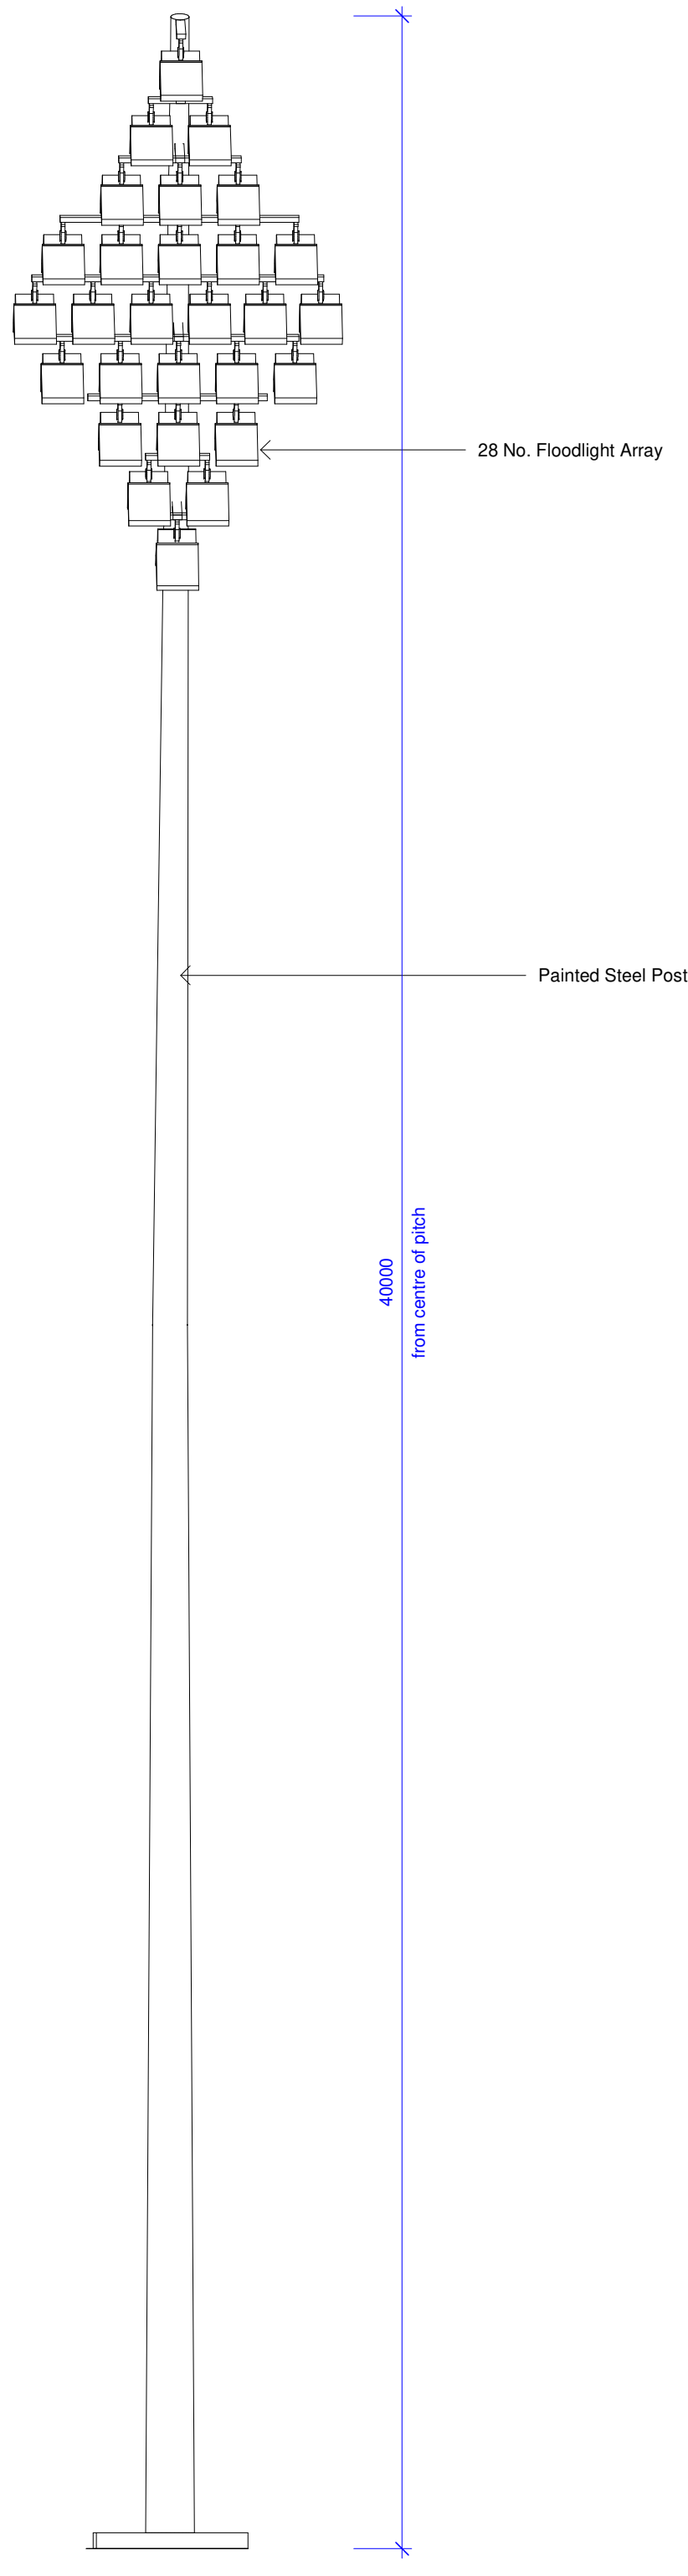
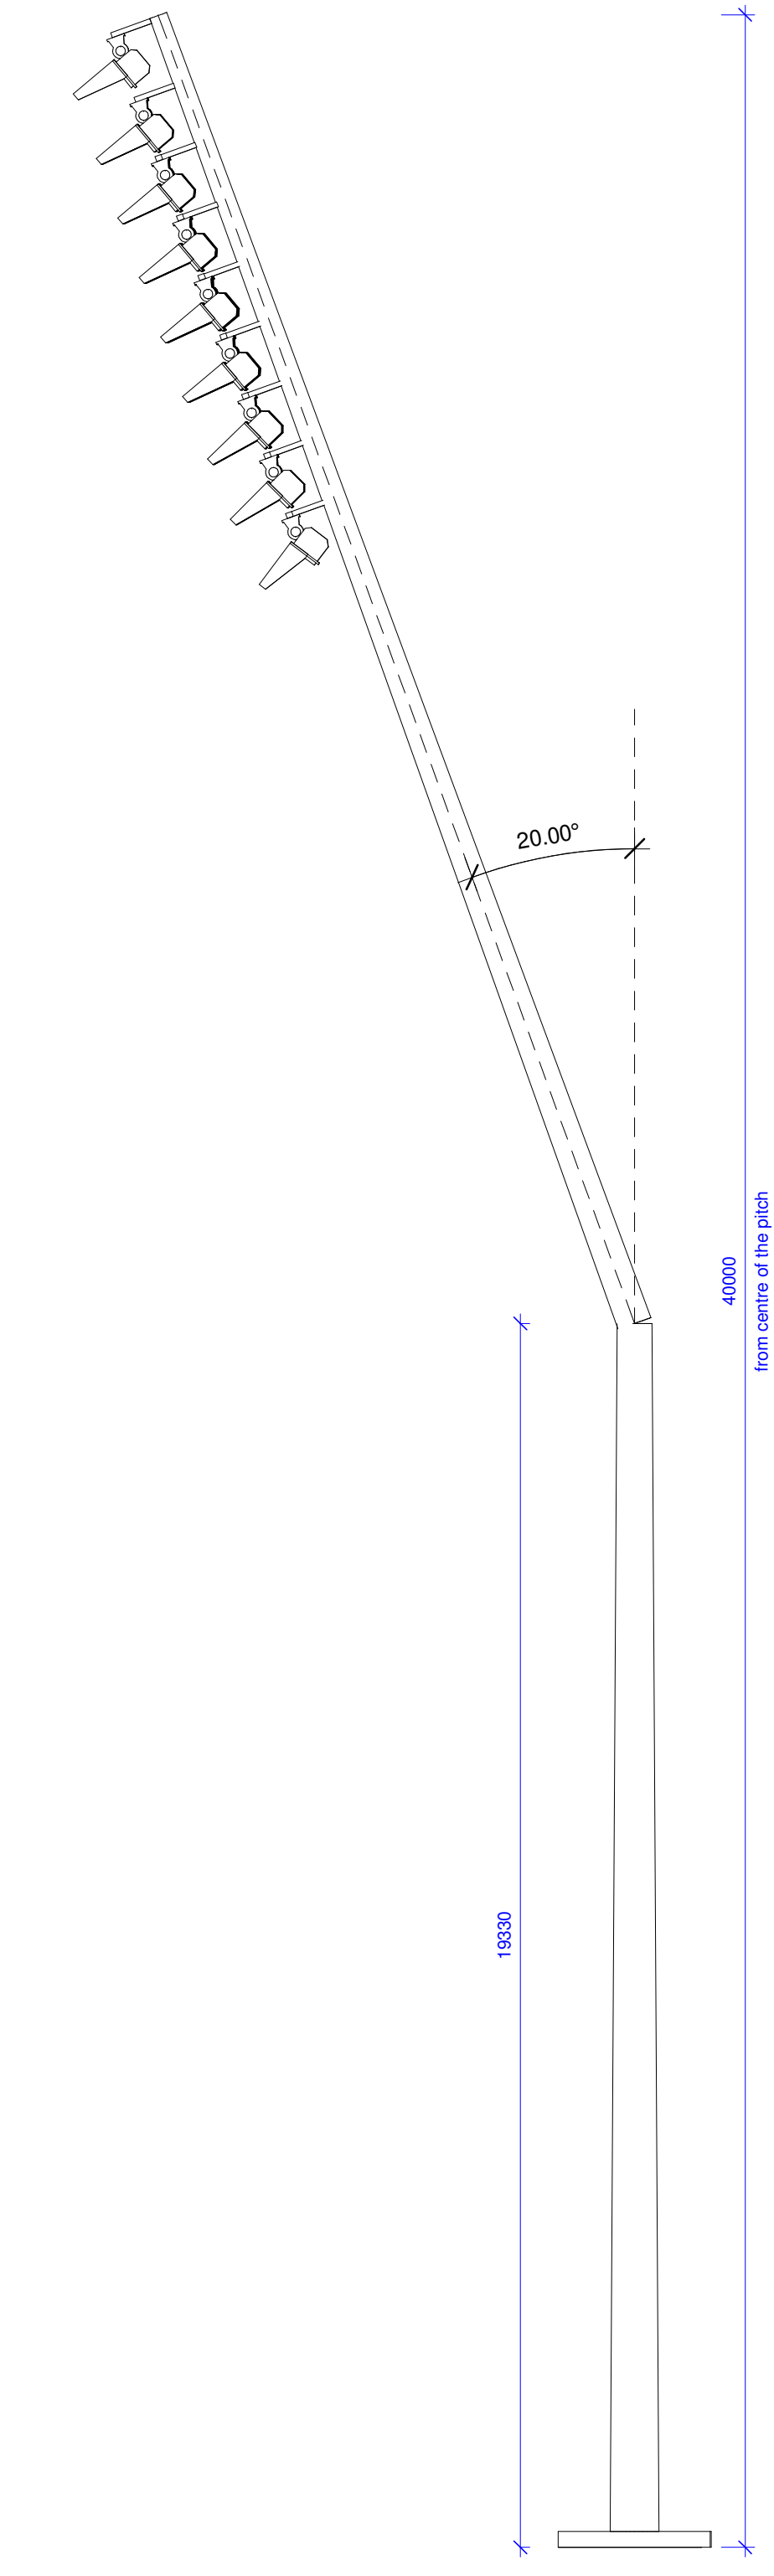


NOTES
All dimensions and levels to be checked on site
Any discrepancies are to be reported to the Architect before any work commences
This drawing shall not be scaled to ascertain any dimensions, work to figured dimensions only
This drawing shall not be reproduced without express written permission from AFL Architects Ltd.

DISCLAIMER
When this drawing is issued in CAD, it is an uncontrolled version issued for information only, to enable the recipient to prepare their own documents/drawings for which they are solely responsible.

SOFTWARE INTEROPERABILITY
AFL prepared this drawing using Autodesk REVIT Architecture.
AFL does not accept liability for any loss or degradation of any information held in the drawing resulting from the translation from the original file format to any other file format or from the recipients reading of it in any other programme.

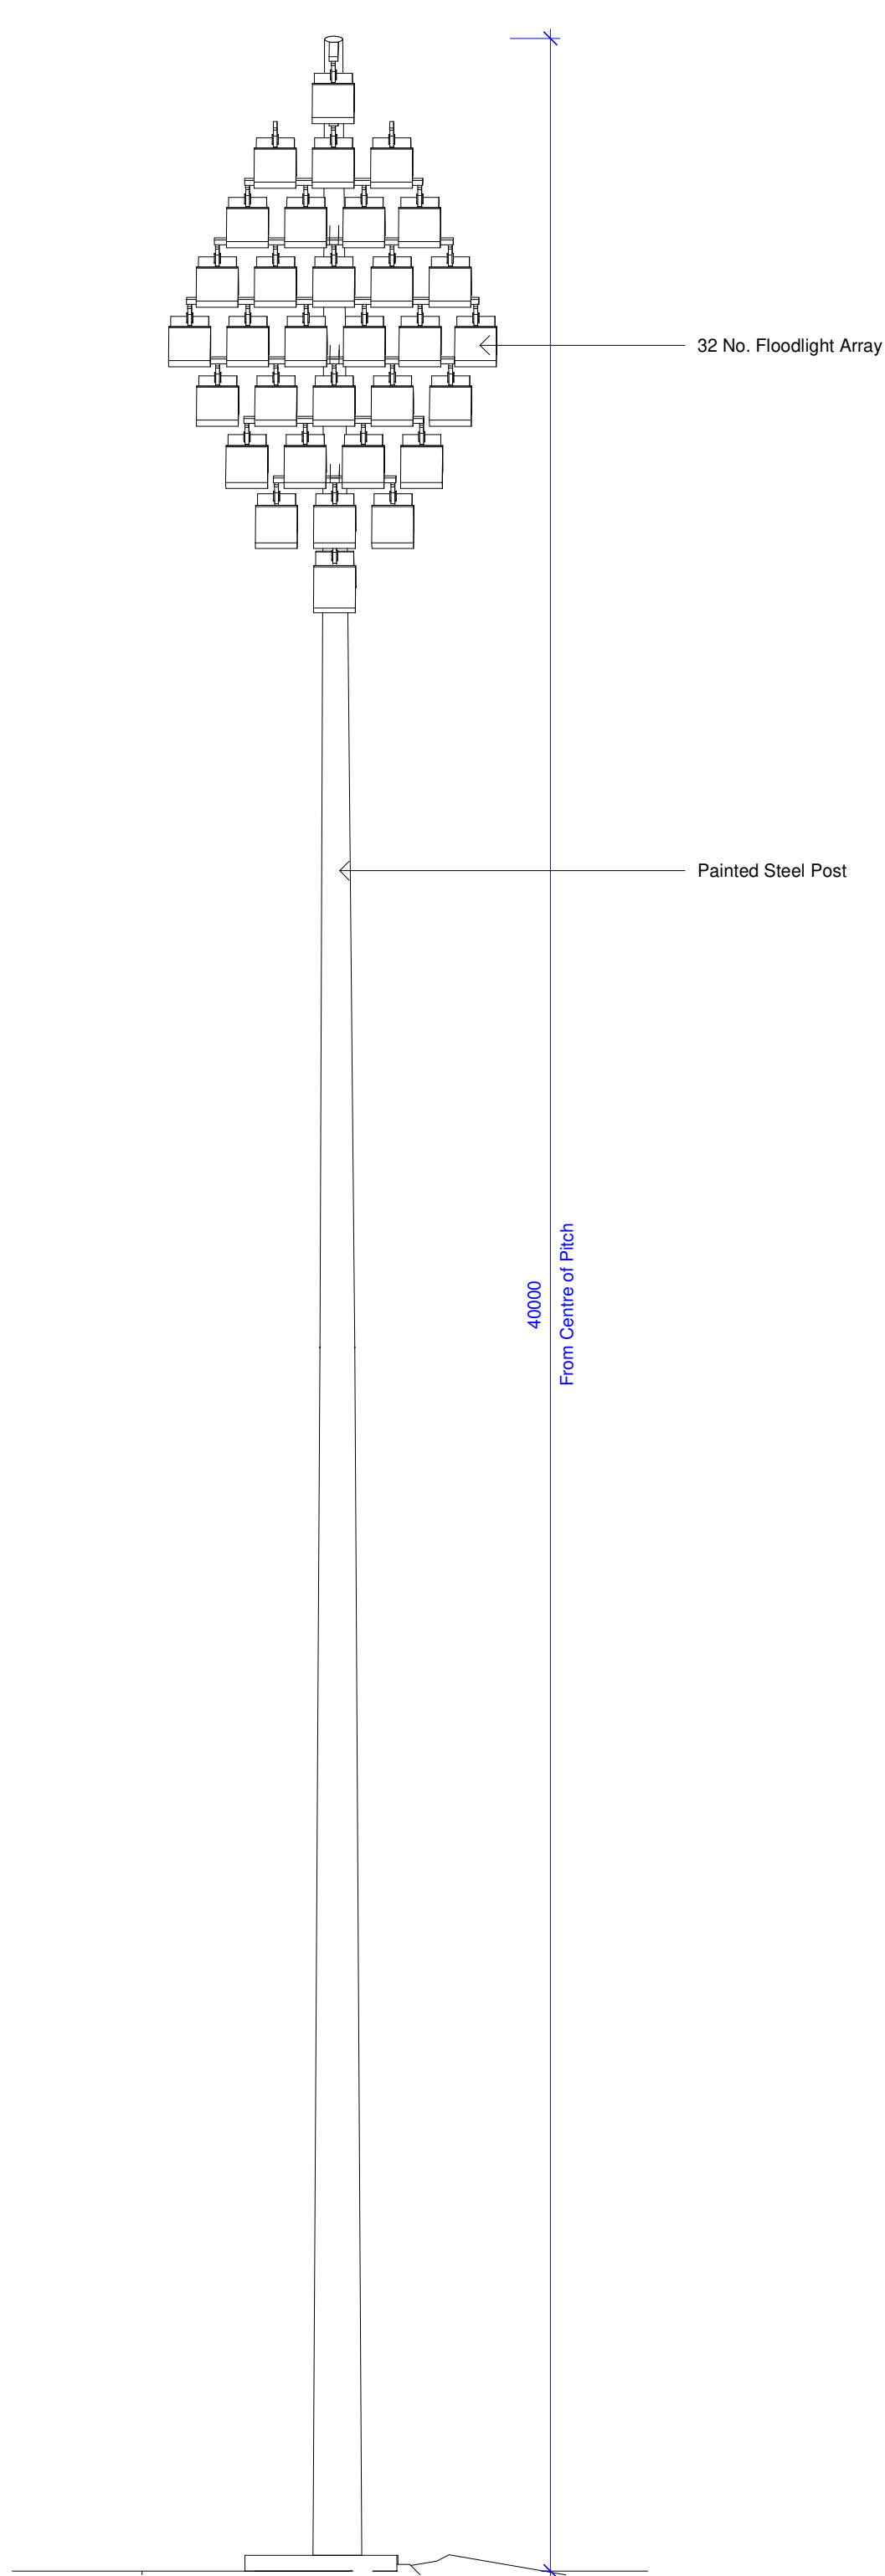

P1 08.06.22		WR PLANNING ISSUE	
rev no.	rev date	rev by	description
project			
KOP Redevelopment			
location			
Racecourse Stadium			
Employer			

client



AFL Architects
1st Floor
St Georges House
56 Peter Street
Manchester M2 3NQ
t: +44(0)161 236 6263
f: +44(0)161 236 6484
w: www.afl-architects.com
e: mail@afl-uk.com
twitter.com/AFLArchitects



key plan

drawing title
Floodlight Tower Details

1 P01 & P02 Floodlight towers
1 : 100

2 Floodlight Tower P01-04 Side Elevation
1 : 100

3 Tower Floodlight P03 & 04 Front Elevation
1 : 100

AFL job number	scale @ A1	drawn	WR	checked	JR
211509	As indicated	rev date	08.06.22		
dwg purpose		status		rev	
PLANNING		S2		P1	
bim project	origin	zone	level	type	role
5-digit no.					
211509-AFL-ZZ-ZZ-DR-A-00203					