


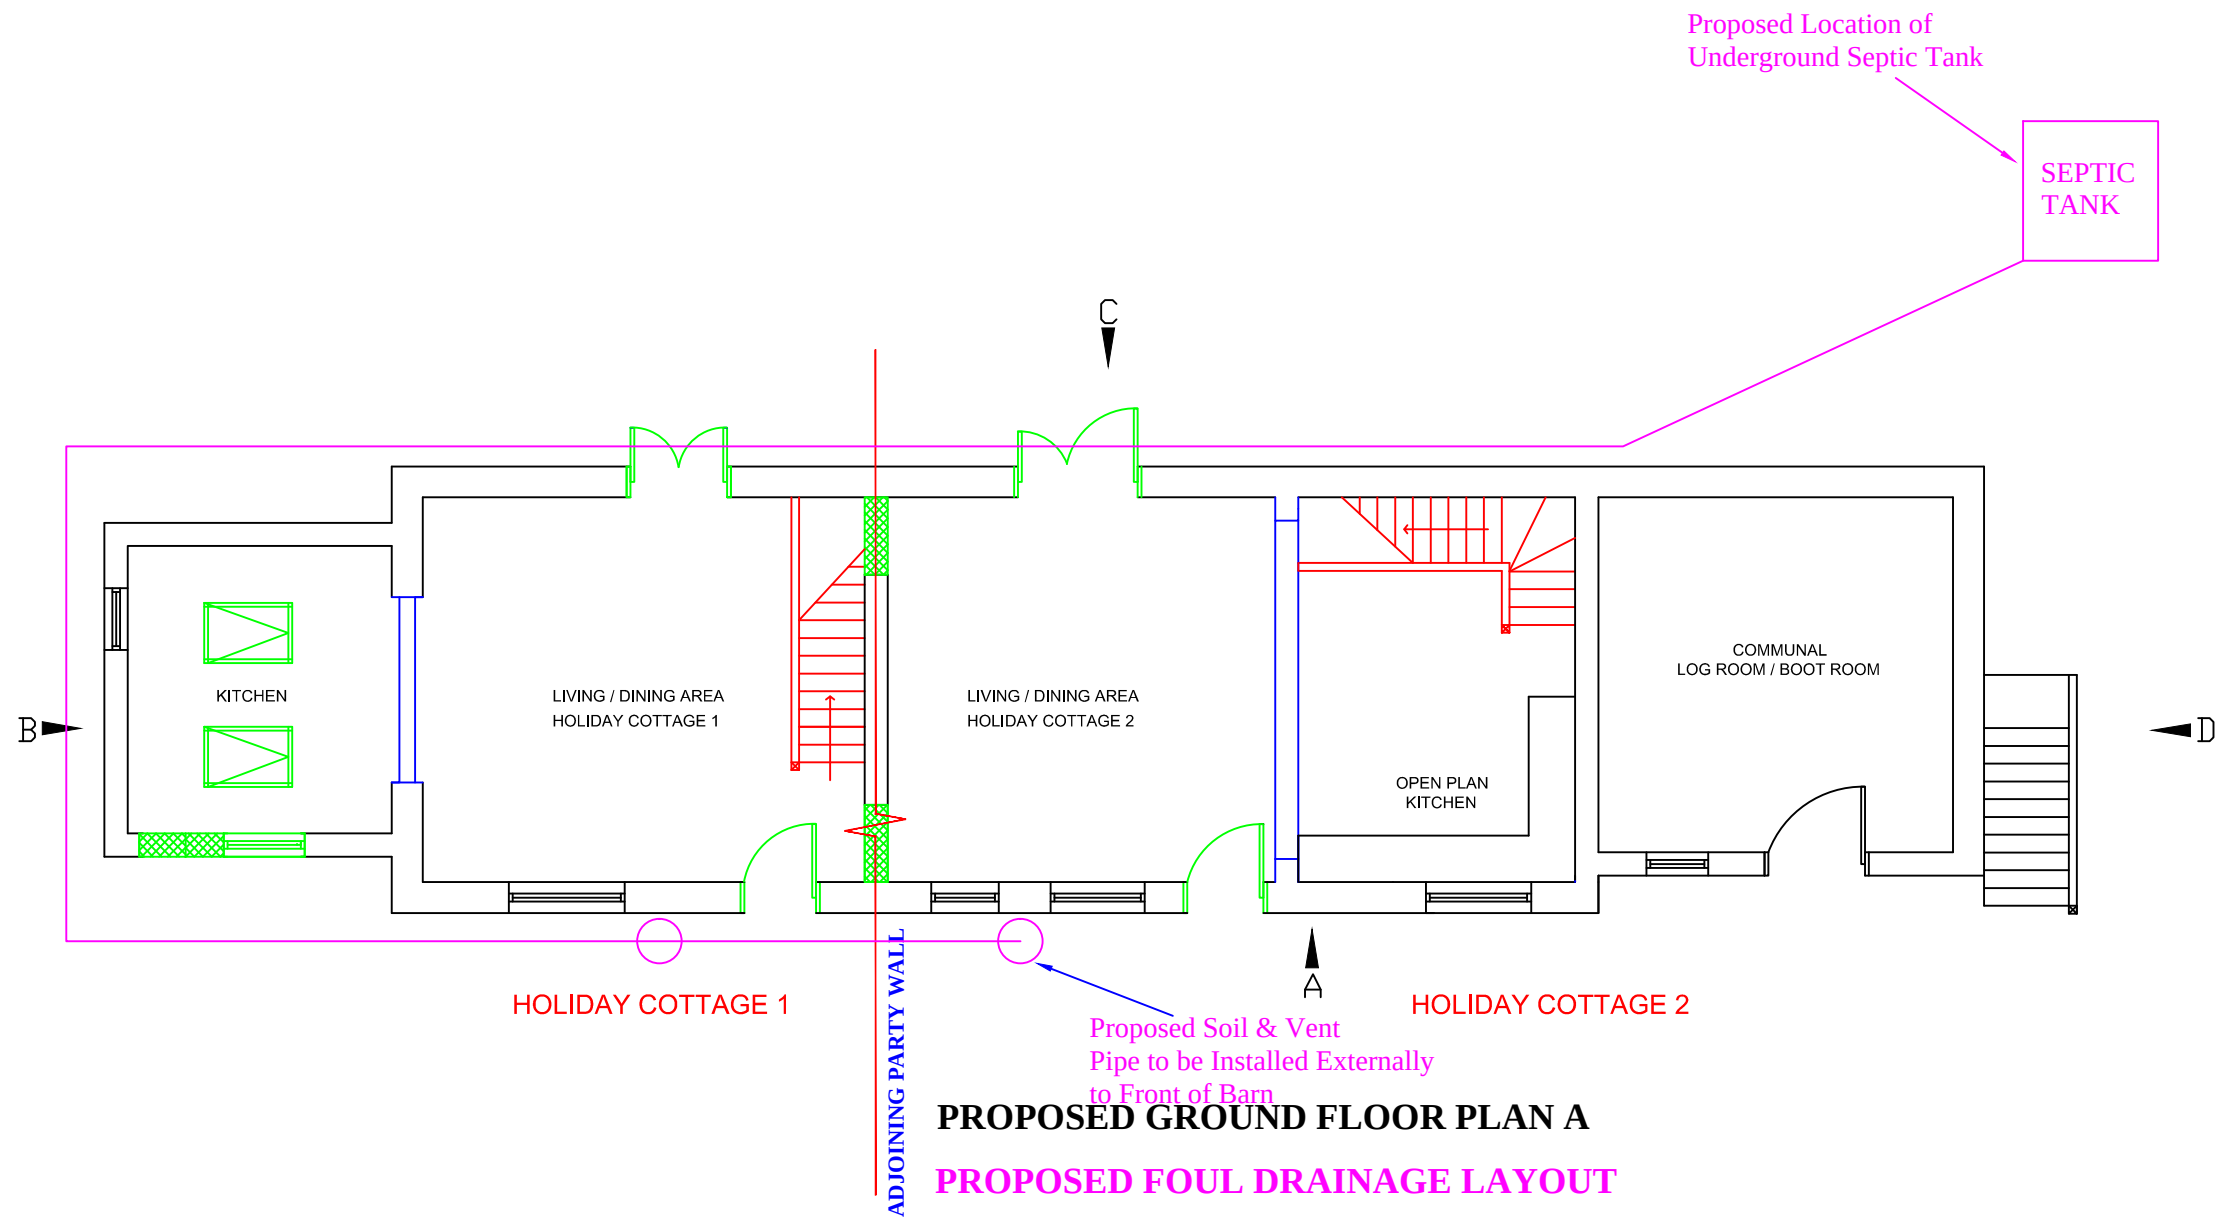

PROPOSED GROUND FLOOR PLAN A

PROPOSED FOUL DRAINAGE LAYOUT

FOXALL SURVEYING Ltd

ARCHITECTURAL DESIGN - BUILDING SURVEYORS -
CHARTERED BUILDING ENGINEERS

Mr. IAN E FOXALL BSc. (Hons) MCIOB, C.BuildE MCABE - Building Surveyor

Tel: 01244 292421 Mobile: 07736286663

E-Mail: ian@foxallsurveying.co.uk Web: www.foxallsurveying.co.uk

9 CAMPBELL CLOSE, ROSSTT, WREXHAM LL12 0HZ

DRAWING STATUS
PROPOSED BARN CONVERSION - HOLIDAY LETS

SCALE 1:100 @A3

CLIENT
Mr & Mrs GO & ML JONES

PROJECT
TY MAWR (FARMHOUSE) PONTFADOG, WREXHAM LL20 7AS

DRAWING TITLE
PROPOSED DRAINAGE LAYOUT - SEWERAGE

DRAWING NUMBER
FSDS I.F 11.01.2022 (003)19 - 005

REV
A

DO NOT SCALE FROM THIS DRAWING - USE FIGURED DIMENSIONS ONLY. READ IN CONJUNCTION WITH ALL OTHER SPECIALISTS/CONSULTANTS DRAWINGS.REPORT ANY DISCREPANCIES BEFORE AFFECTED WORK COMMENCES. ALL SETTING OUT DIMENSIONS TO BE CHECKED ON SITE BY CONTRACTOR BEFORE WORK COMMENCES. THIS DRAWING REMAINS COPYRIGHT OF - [FSDS FOXALL SURVEYING & DESIGN SERVICES LTD.](http://www.foxallsurveying.co.uk) COPY / DISTRIBUTION ONLY CONSENT OF THE AUTHOR.