


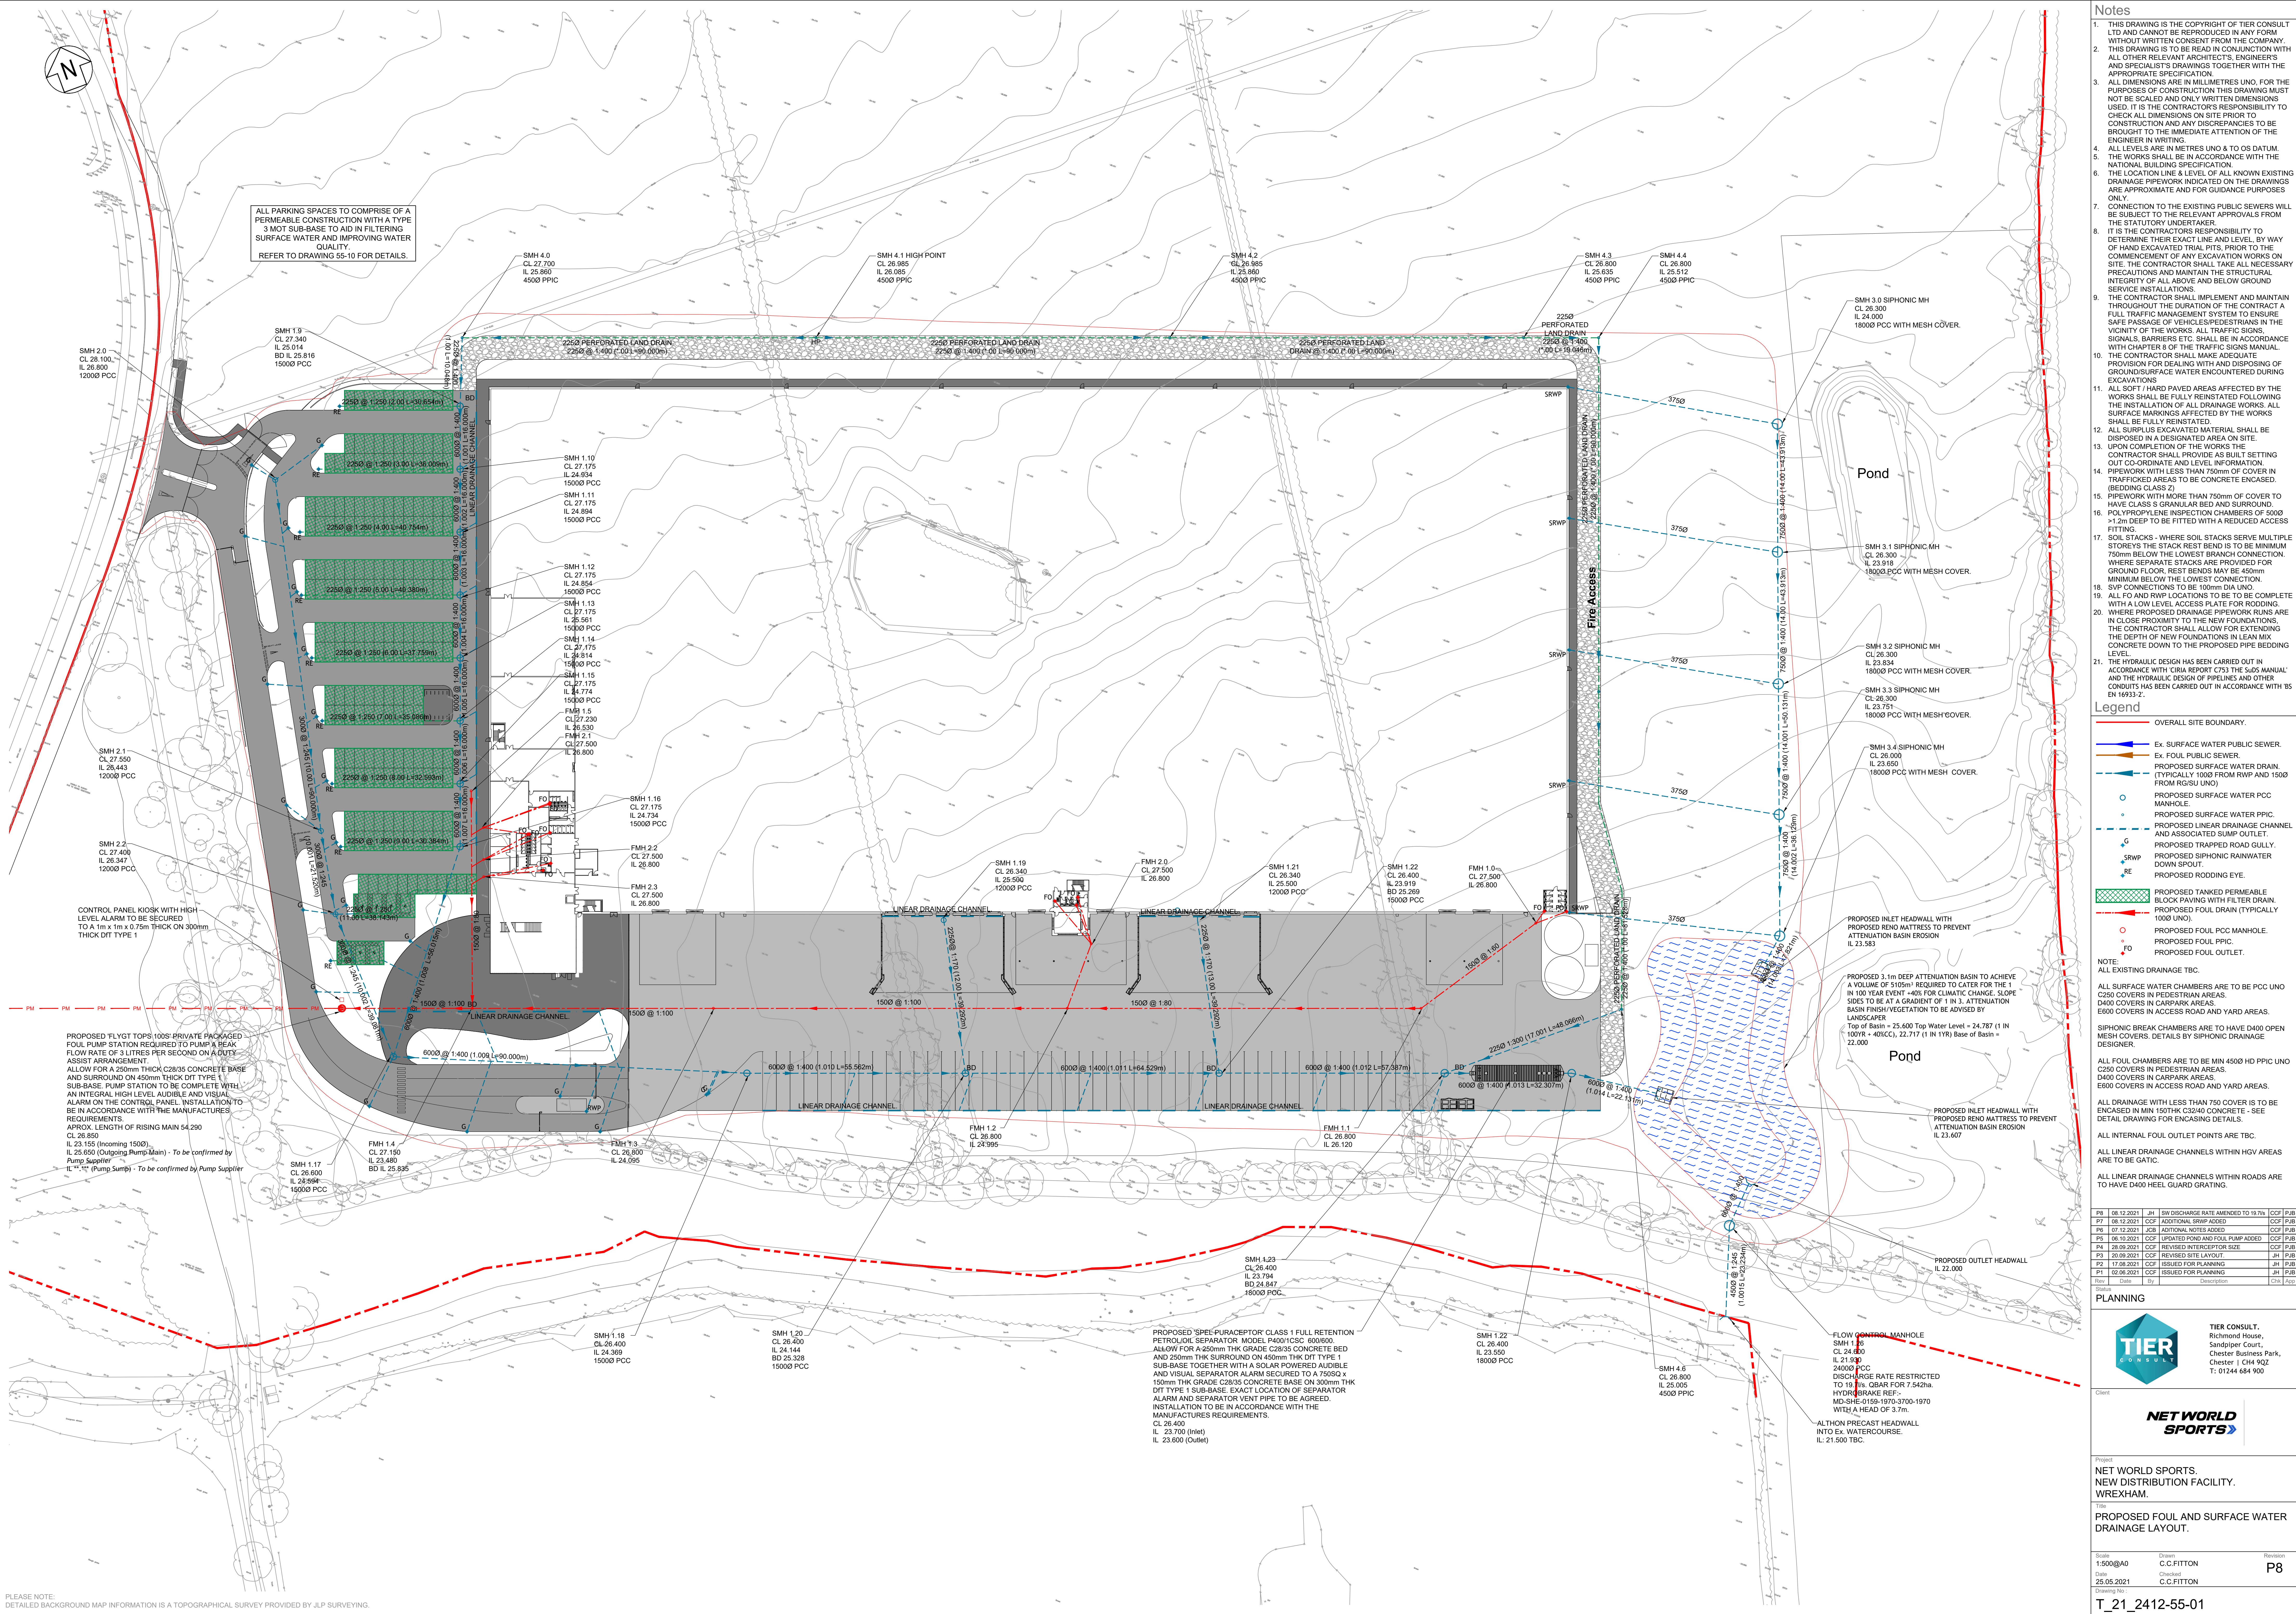

PLEASE NOTE:
DETAILED BACKGROUND MAP INFORMATION IS A TOPOGRAPHICAL SURVEY PROVIDED BY JLP SURVEYING.

- THIS DRAWING IS THE COPYRIGHT OF TIER CONSULT LTD AND CANNOT BE REPRODUCED IN ANY FORM WITHOUT WRITTEN CONSENT FROM THE COMPANY.
- THIS DRAWING IS TO BE READ IN CONJUNCTION WITH ALL OTHER RELEVANT ARCHITECTS, ENGINEERS AND SPECIALISTS DRAWINGS TOGETHER WITH THE APPROPRIATE SPECIFICATION.
- ALL DIMENSIONS ARE IN MILLIMETRES UNO. FOR THE PURPOSES OF CONSTRUCTION THIS DRAWING MUST NOT BE SCALED AND ONLY WRITTEN DIMENSIONS USED. IT IS THE CONTRACTOR'S RESPONSIBILITY TO CHECK ALL DIMENSIONS ON SITE PRIOR TO CONSTRUCTION AND ANY DISCREPANCIES TO BE BROUGHT TO THE IMMEDIATE ATTENTION OF THE ENGINEER IN WRITING.
- ALL LEVELS ARE IN METRES UNO & TO OS DATUM.
- THE WORKS SHALL BE IN ACCORDANCE WITH THE NATIONAL BUILDING SPECIFICATION.
- THE LOCATION LINE & LEVEL OF ALL KNOWN EXISTING DRAINAGE PIPEWORK INDICATED ON THE DRAWINGS ARE APPROXIMATE AND FOR GUIDANCE PURPOSES ONLY.
- CONNECTION TO THE EXISTING PUBLIC SEWERS WILL BE SUBJECT TO THE RELEVANT APPROVALS FROM THE STATUTORY UNDERTAKER.
- IT IS THE CONTRACTOR'S RESPONSIBILITY TO DETERMINE THEIR EXACT LINE AND LEVEL BY WAY OF HAND EXCAVATED TRIAL PITS, PRIOR TO THE COMMENCEMENT OF ANY EXCAVATION WORKS ON SITE. THE CONTRACTOR SHALL TAKE ALL NECESSARY PRECAUTIONS AND MAINTAIN THE STRUCTURAL INTEGRITY OF ALL ABOVE AND BELOW GROUND SERVICE INSTALLATIONS.
- THE CONTRACTOR SHALL IMPLEMENT AND MAINTAIN THROUGHOUT THE DURATION OF THE CONTRACT A FULL TRAFFIC MANAGEMENT SYSTEM TO ENSURE SAFE PASSAGE OF VEHICLES/PEDESTRIANS IN THE VICINITY OF THE WORKS. ALL TRAFFIC SIGNS, SIGNALS, BARRIERS ETC. SHALL BE IN ACCORDANCE WITH CHAPTER 8 OF THE TRAFFIC SIGNS MANUAL.
- THE CONTRACTOR SHALL MAKE ADEQUATE PROVISION FOR DEALING WITH AND DISPOSING OF GROUND/SURFACE WATER ENCOUNTERED DURING EXCAVATIONS.
- ALL SOFT / HARD PAVED AREAS AFFECTED BY THE WORKS SHALL BE FULLY REINSTATED FOLLOWING THE INSTALLATION OF ALL DRAINAGE WORKS. ALL SURPLUS EXCAVATED MATERIAL SHALL BE DISPOSED IN A DESIGNATED AREA ON SITE.
- UPON COMPLETION OF THE WORKS THE CONTRACTOR SHALL PROVIDE AS BUILT SETTING OUT CO-ORDINATE AND LEVEL INFORMATION.
- PIPEWORK WITH LESS THAN 750mm OF COVER IN TRAFFICKED AREAS TO BE CONCRETE ENCASED (BEDDING CLASS Z)
- PIPEWORK WITH MORE THAN 750mm OF COVER TO HAVE CLASS 5 GRANULAR BED AND SURROUND.
- POLYPROPYLENE INSPECTION CHAMBERS OF 5000 x 1200 DEEP TO BE FITTED WITH A REDUCED ACCESS FITTING.
- SOIL STACKS - WHERE SOIL STACKS SERVE MULTIPLE STOREYS THE STACK REST BEND IS TO BE MINIMUM 750mm BELOW THE LOWEST BRANCH CONNECTION, WHERE SEPARATE STACKS ARE PROVIDED FOR GROUND FLOOR, REST BENDS MAY BE 450mm MINIMUM BELOW THE LOWEST CONNECTION.
- SVP CONNECTIONS TO BE 100mm DIA UNO.
- ALL FO AND RWP LOCATIONS TO BE TO BE COMPLETE WITH A LOW LEVEL ACCESS PLATE FOR RODDING.
- WHERE PROPOSED DRAINAGE PIPEWORK RUNS ARE IN CLOSE PROXIMITY TO THE NEW FOUNDATIONS, THE CONTRACTOR SHALL ALLOW FOR EXTENDING THE DEPTH OF NEW FOUNDATIONS IN LEAN MIX CONCRETE DOWN TO THE PROPOSED PIPE BEDDING LEVEL.
- THE HYDRAULIC DESIGN HAS BEEN CARRIED OUT IN ACCORDANCE WITH CIRIA REPORT 753 THE SUBS MANUAL AND THE HYDRAULIC DESIGN OF PIPELINES AND OTHER CONDUITS HAS BEEN CARRIED OUT IN ACCORDANCE WITH BS EN 16933-2.

- Legend**
- OVERALL SITE BOUNDARY.
 - Ex. SURFACE WATER PUBLIC SEWER.
 - Ex. FOUL PUBLIC SEWER.
 - PROPOSED SURFACE WATER DRAIN.
 - (TYPICALLY 1000 FROM RWP AND 1500 FROM RGSU UNO).
 - PROPOSED SURFACE WATER PCC MANHOLE.
 - PROPOSED SURFACE WATER PPIC.
 - PROPOSED LINEAR DRAINAGE CHANNEL AND ASSOCIATED SUMP OUTLET.
 - PROPOSED TRAPPED ROAD GULLY.
 - PROPOSED SIPHONIC RAINWATER DOWN SPOUT.
 - PROPOSED RODDING EYE.
 - PROPOSED TANKED PERMEABLE BLOCK PAVING WITH FILTER DRAIN.
 - PROPOSED FOUL DRAIN (TYPICALLY 1000 UNO).
 - PROPOSED FOUL PCC MANHOLE.
 - PROPOSED FOUL PPIC.
 - PROPOSED FOUL OUTLET.
 - ALL EXISTING DRAINAGE TBC.
 - ALL SURFACE WATER CHAMBERS ARE TO BE PCC UNO C250 COVERS IN PEDESTRIAN AREAS.
 - D400 COVERS IN CARPARK AREAS.
 - E600 COVERS IN ACCESS ROAD AND YARD AREAS.
 - SIPHONIC BREAK CHAMBERS ARE TO HAVE D400 OPEN MESH COVERS. DETAILS BY SIPHONIC DRAINAGE DESIGNER.
 - ALL FOUL CHAMBERS ARE TO BE MIN 4500 HD PPIC UNO C250 COVERS IN PEDESTRIAN AREAS.
 - D400 COVERS IN CARPARK AREAS.
 - E600 COVERS IN ACCESS ROAD AND YARD AREAS.
 - ALL DRAINAGE WITH LESS THAN 750 COVER IS TO BE ENCASED IN MIN 150THK C32/40 CONCRETE - SEE DETAIL DRAWING FOR ENCASEING DETAILS.
 - ALL INTERNAL FOUL OUTLET POINTS ARE TBC.
 - ALL LINEAR DRAINAGE CHANNELS WITHIN HOV AREAS ARE TO BE GATIC.
 - ALL LINEAR DRAINAGE CHANNELS WITHIN ROADS ARE TO HAVE D400 HEEL GUARD GRATING.

NOTE:
ALL EXISTING DRAINAGE TBC.

PROPOSED 3.1m DEEP ATTENUATION BASIN TO ACHIEVE A VOLUME OF 510m³ REQUIRED TO CATER FOR THE 1 IN 100 YEAR EVENT +40% FOR CLIMATIC CHANGE. SLOPE SIDES TO BE AT A GRADIENT OF 1 IN 3. ATTENUATION BASIN FINISH/VEGETATION TO BE ADVISED BY LANDSCAPER.
Top of Basin = 25.600 Top Water Level = 24.787 (1 IN 100YR + 40%CL), 22.717 (1 IN 1YR) Base of Basin = 22.000

PROPOSED INLET HEADWALL WITH PROPOSED RENO MATTRESS TO PREVENT ATTENUATION BASIN EROSION IL 23.583

PROPOSED INLET HEADWALL WITH PROPOSED RENO MATTRESS TO PREVENT ATTENUATION BASIN EROSION IL 23.607

Rev	Date	By	Description	Drawn	Check
P8	08.12.2021	JH	SW DISCHARGE RATE AMENDED TO 10.7m ³ /H	CCF	PJB
P7	08.12.2021	CCF	ADDITIONAL SRWP ADDED	CCF	PJB
P6	07.12.2021	JCB	ADDITIONAL NOTES ADDED	CCF	PJB
P5	06.10.2021	CCF	UPDATED POND AND FOUL PUMP ADDED	CCF	PJB
P4	26.09.2021	CCF	REVISED INTERCEPTOR SIZE	CCF	PJB
P3	20.09.2021	CCF	REVISED SITE LAYOUT	JH	PJB
P2	17.08.2021	CCF	ISSUED FOR PLANNING	JH	PJB
P1	02.06.2021	CCF	ISSUED FOR PLANNING	JH	PJB

PLANNING

TIER CONSULT

Client

NET WORLD SPORTS

Project
NET WORLD SPORTS.
NEW DISTRIBUTION FACILITY.
WREXHAM.

Title
PROPOSED FOUL AND SURFACE WATER
DRAINAGE LAYOUT.

Scale
1:500@A0

Drawn
C.C.FITTON

Revision
P8

Date
25.05.2021

Checked
C.C.FITTON

Drawing No
T_21_2412-55-01

Tier Consult.
Richmond House,
Sandpiper Court,
Chester Business Park,
Chester L CH4 9QZ
T: 01244 684 900

NET WORLD SPORTS

Client

TIER CONSULT

Client

NET WORLD SPORTS

Project
NET WORLD SPORTS.
NEW DISTRIBUTION FACILITY.
WREXHAM.

Title
PROPOSED FOUL AND SURFACE WATER
DRAINAGE LAYOUT.

Scale
1:500@A0

Drawn
C.C.FITTON

Revision
P8

Date
25.05.2021

Checked
C.C.FITTON

Drawing No
T_21_2412-55-01

Tier Consult.
Richmond House,
Sandpiper Court,
Chester Business Park,
Chester L CH4 9QZ
T: 01244 684 900

NET WORLD SPORTS

Client

TIER CONSULT

Client

NET WORLD SPORTS

Project
NET WORLD SPORTS.
NEW DISTRIBUTION FACILITY.
WREXHAM.

Title
PROPOSED FOUL AND SURFACE WATER
DRAINAGE LAYOUT.

Scale
1:500@A0

Drawn
C.C.FITTON

Revision
P8

Date
25.05.2021

Checked
C.C.FITTON

Drawing No
T_21_2412-55-01

Tier Consult.
Richmond House,
Sandpiper Court,
Chester Business Park,
Chester L CH4 9QZ
T: 01244 684 900

NET WORLD SPORTS

Client

TIER CONSULT

Client

NET WORLD SPORTS

Project
NET WORLD SPORTS.
NEW DISTRIBUTION FACILITY.
WREXHAM.

Title
PROPOSED FOUL AND SURFACE WATER
DRAINAGE LAYOUT.

Scale
1:500@A0

Drawn
C.C.FITTON

Revision
P8

Date
25.05.2021

Checked
C.C.FITTON

Drawing No
T_21_2412-55-01

Tier Consult.
Richmond House,
Sandpiper Court,
Chester Business Park,
Chester L CH4 9QZ
T: 01244 684 900