


NOTES
All dimensions and levels to be checked on site
Any discrepancies are to be reported to the Architect before any work commences
This drawing shall not be scaled to ascertain any dimensions, work to figured dimensions only
This drawing shall not be reproduced without express written permission from AFL Architects Ltd.

DISCLAIMER
When this drawing is issued in CAD, it is an uncontrolled version issued for information only, to enable the recipient to prepare their own documents/drawings for which they are solely responsible.

SOFTWARE INTEROPERABILITY
AFL prepared this drawing using Autodesk REVIT Architecture.
AFL does not accept liability for any loss or degradation of any information held in the drawing resulting from the translation from the original file format to any other file format or from the recipients reading of it in any other programme.

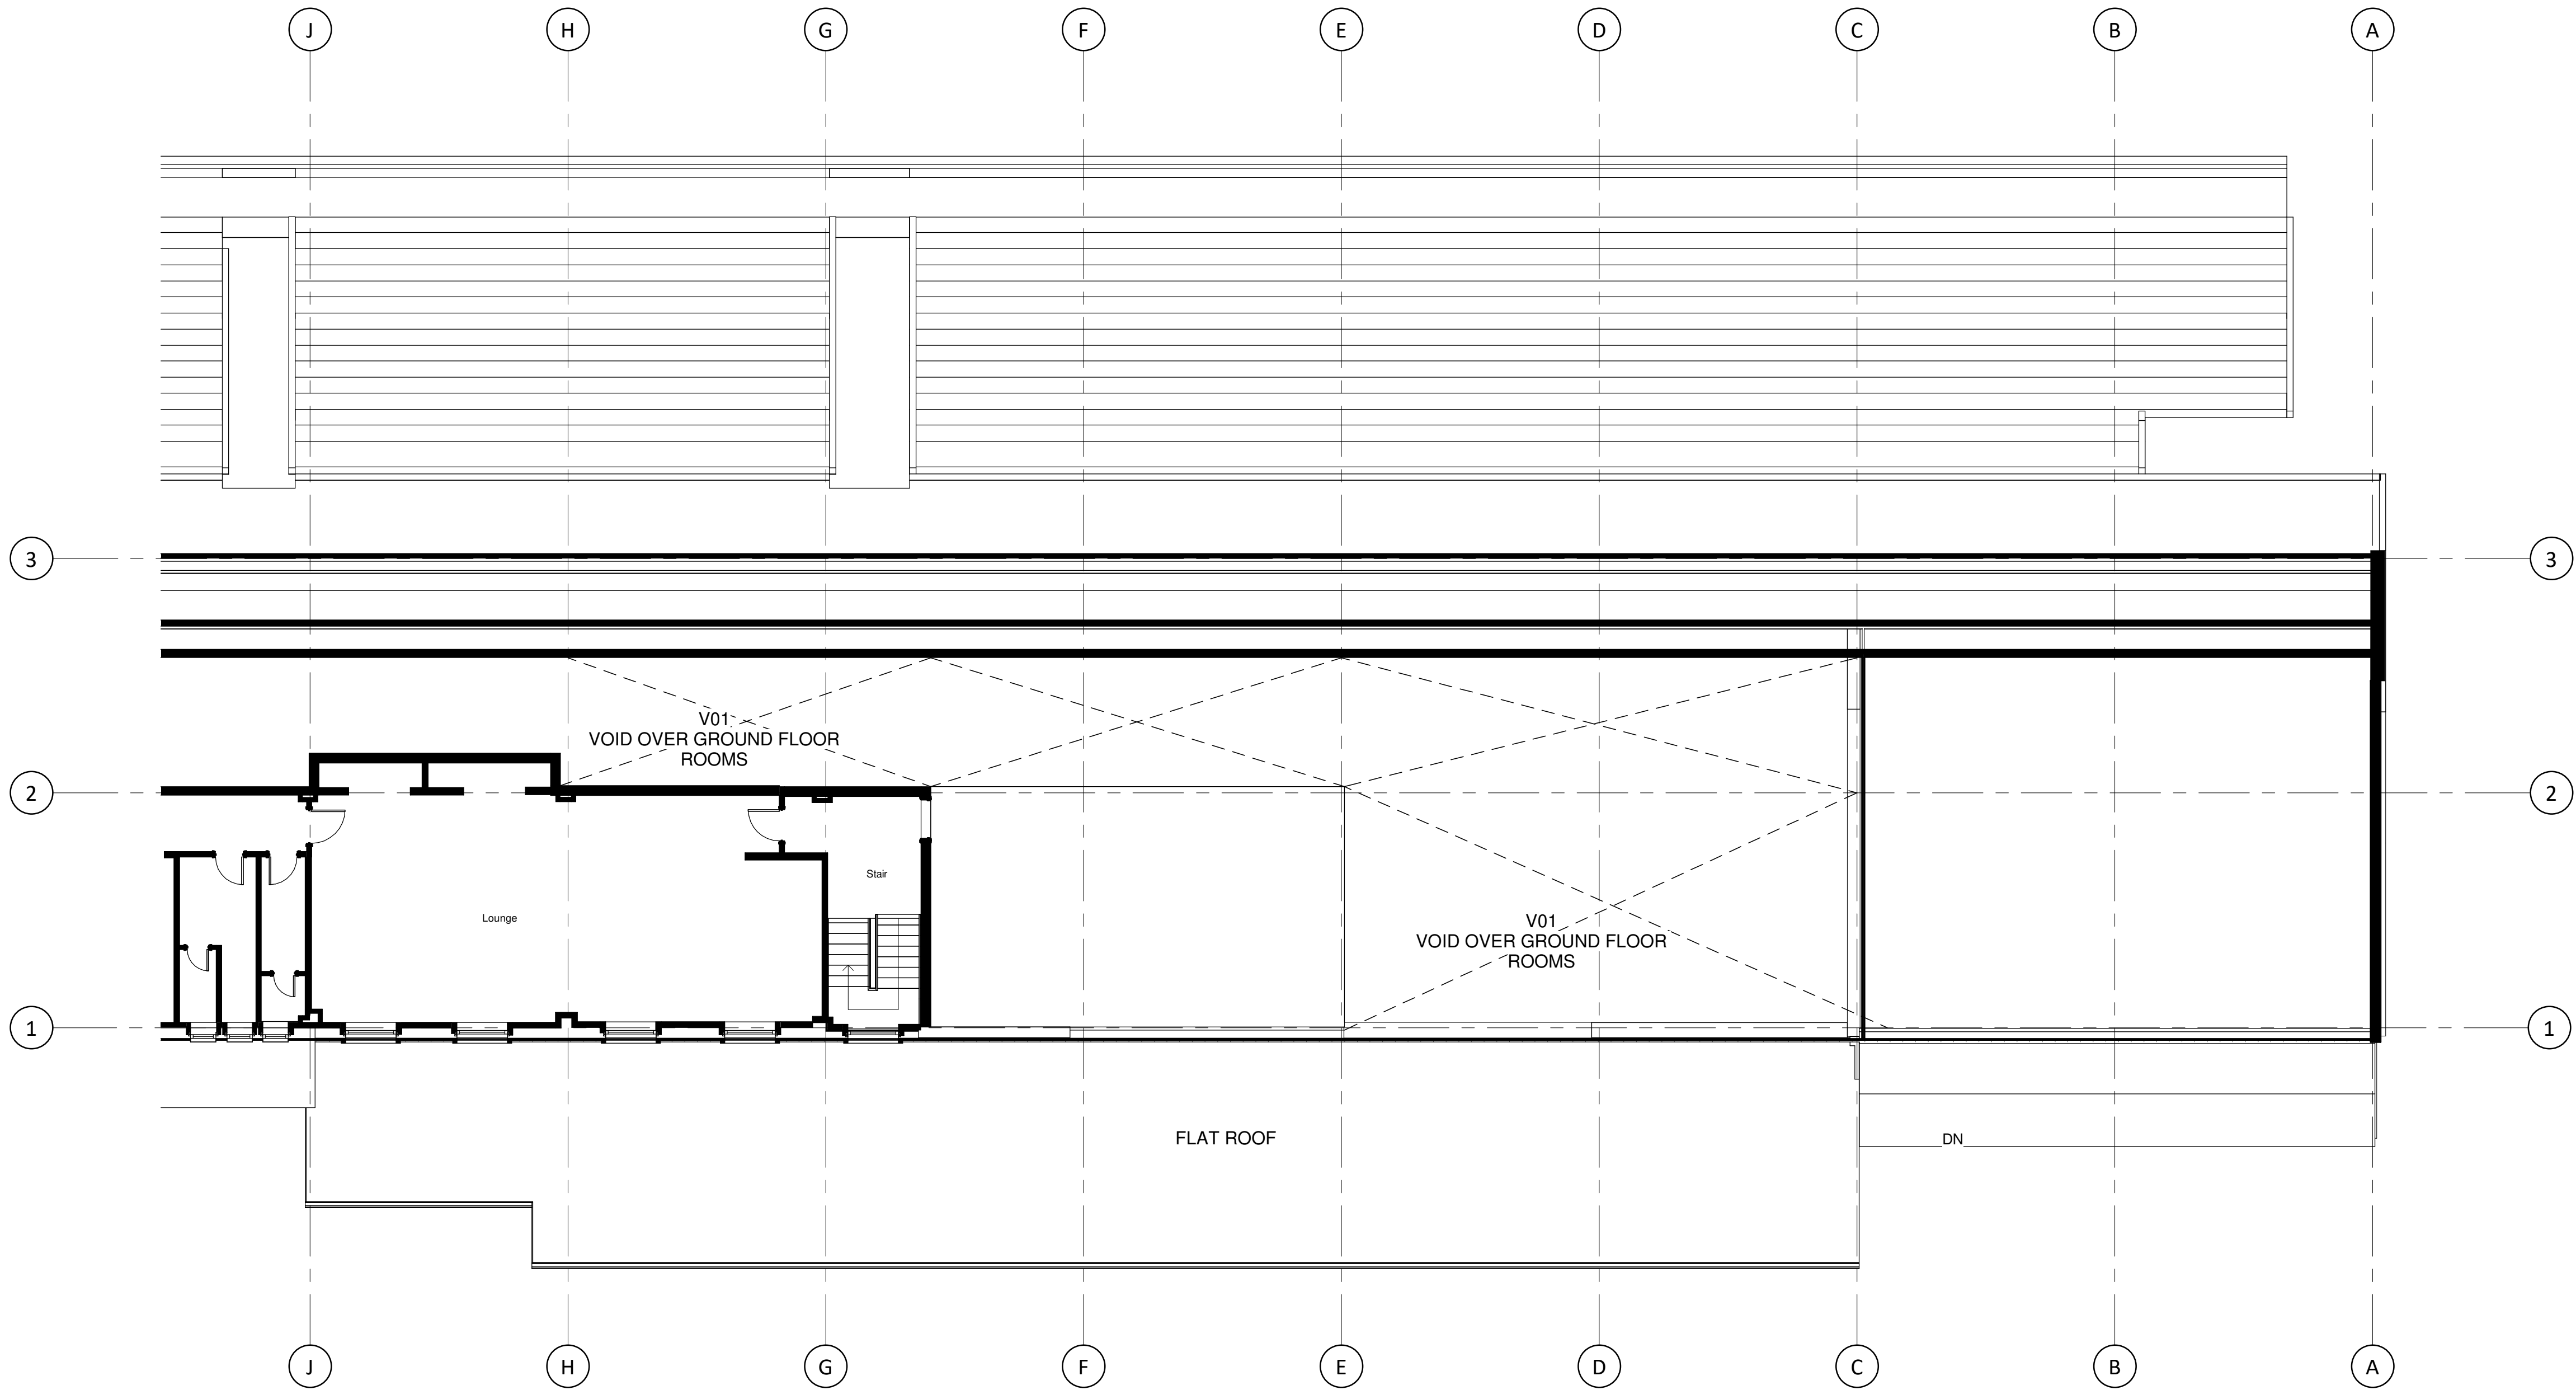

1 Yale L01 Level TBC Existing
1 : 100

P1	14.07.2022	AE	Planning Drawings
rev no.	rev date	rev by	description
project			
Wrexham Lager Stand			
location			
Racecourse Stadium			
Employer			
client			
			
AFL Architects 1st Floor St Georges House 56 Peter Street Manchester M2 3NQ t: +44(0)161 236 6263 f: +44(0)161 236 6484 w: www.afl-architects.com e: mail@afl-uk.com twitter.com/AFLArchitects			
			
key plan			

drawing title
Existing First Floor Plan

AFL job number	scale @ A1	drawn	AE	checked	WR
211540	1 : 100	rev date	14.07.2022		
dwg purpose		status		rev	
PLANNING				P1	
bim project origin zone level type role 5-digit no.					
WRX-AFL-Z4-ZZ-DR-A-20002					