




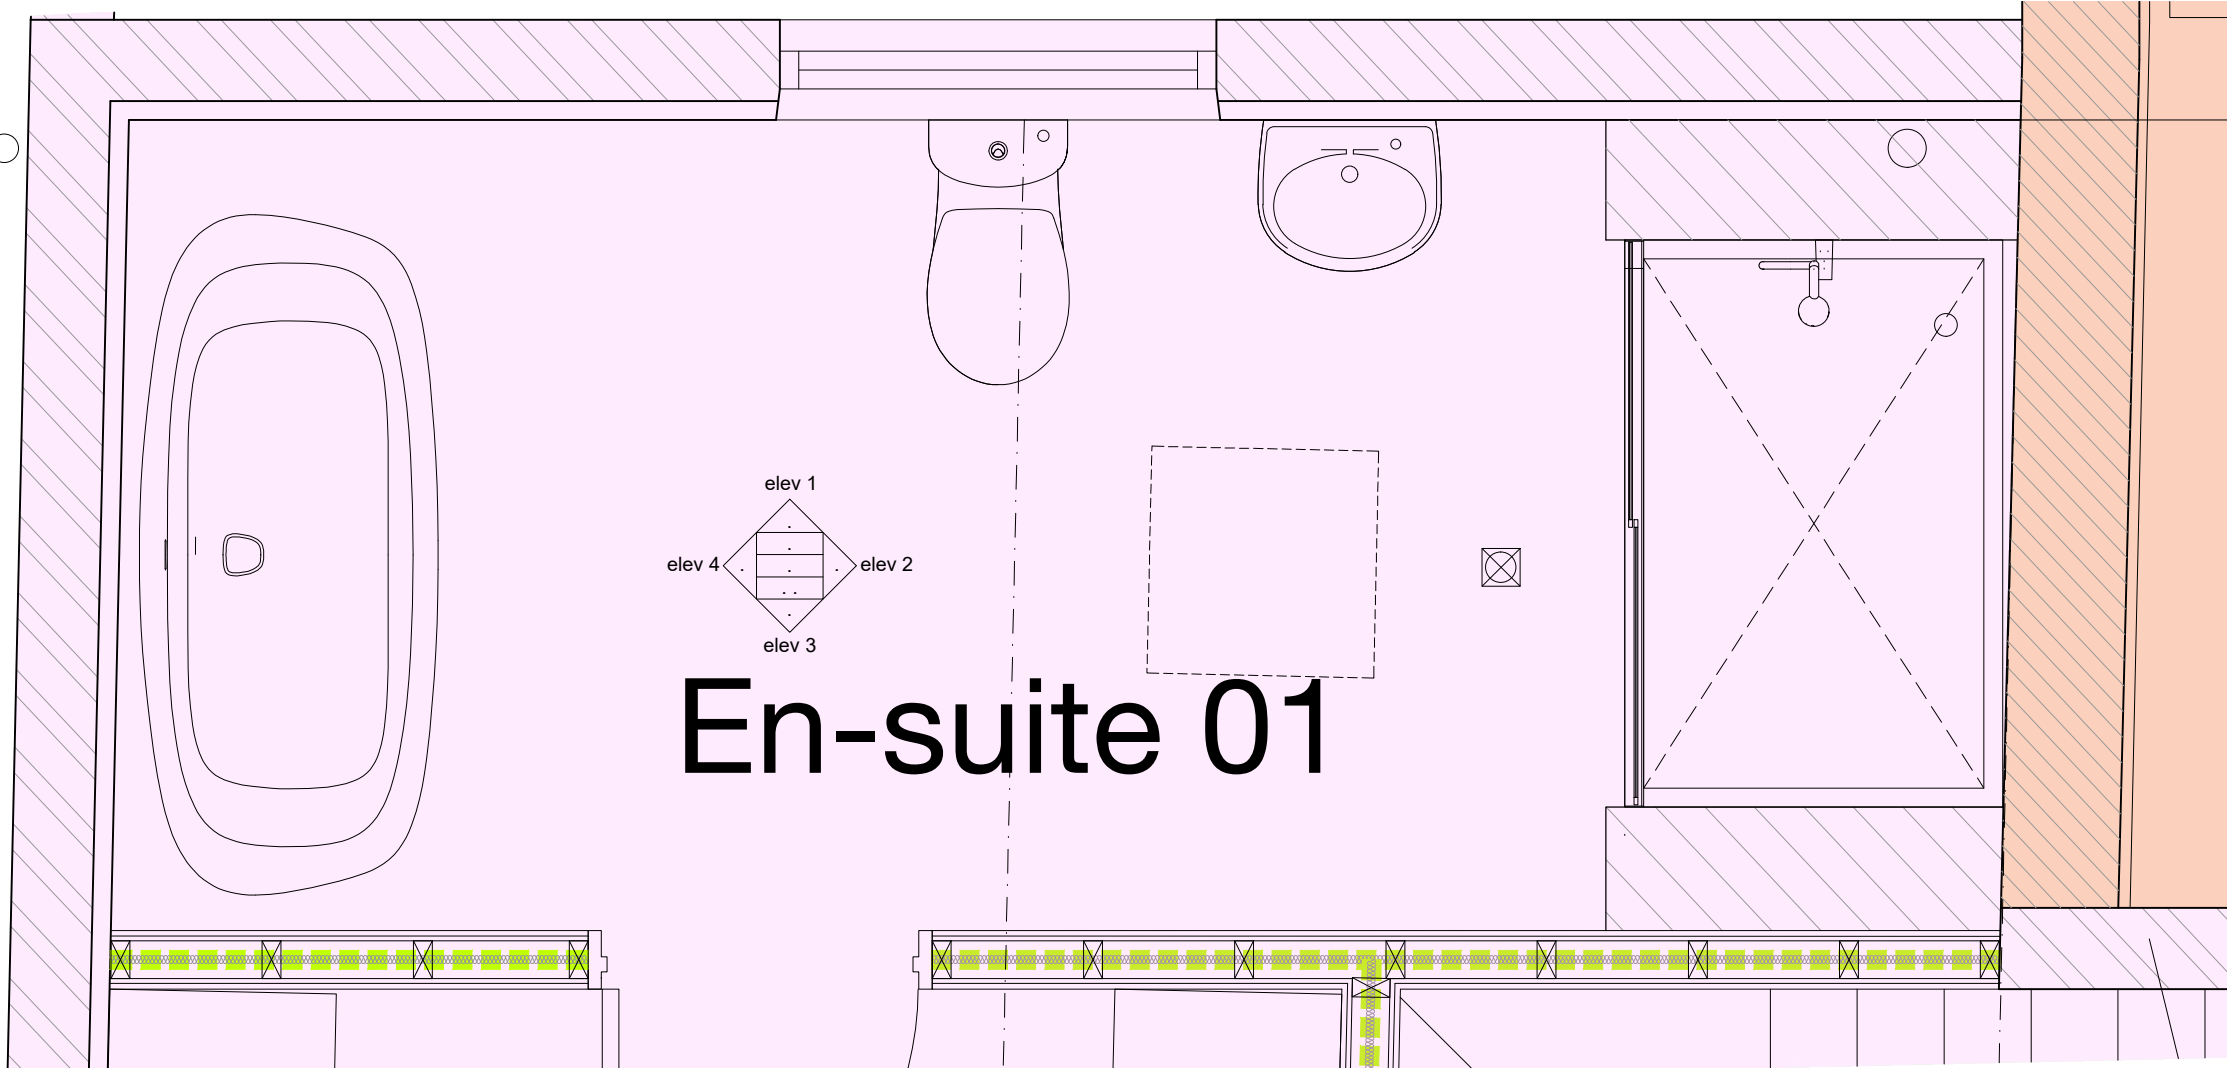


FIRST FLOOR EN-SUITE 01 PLAN

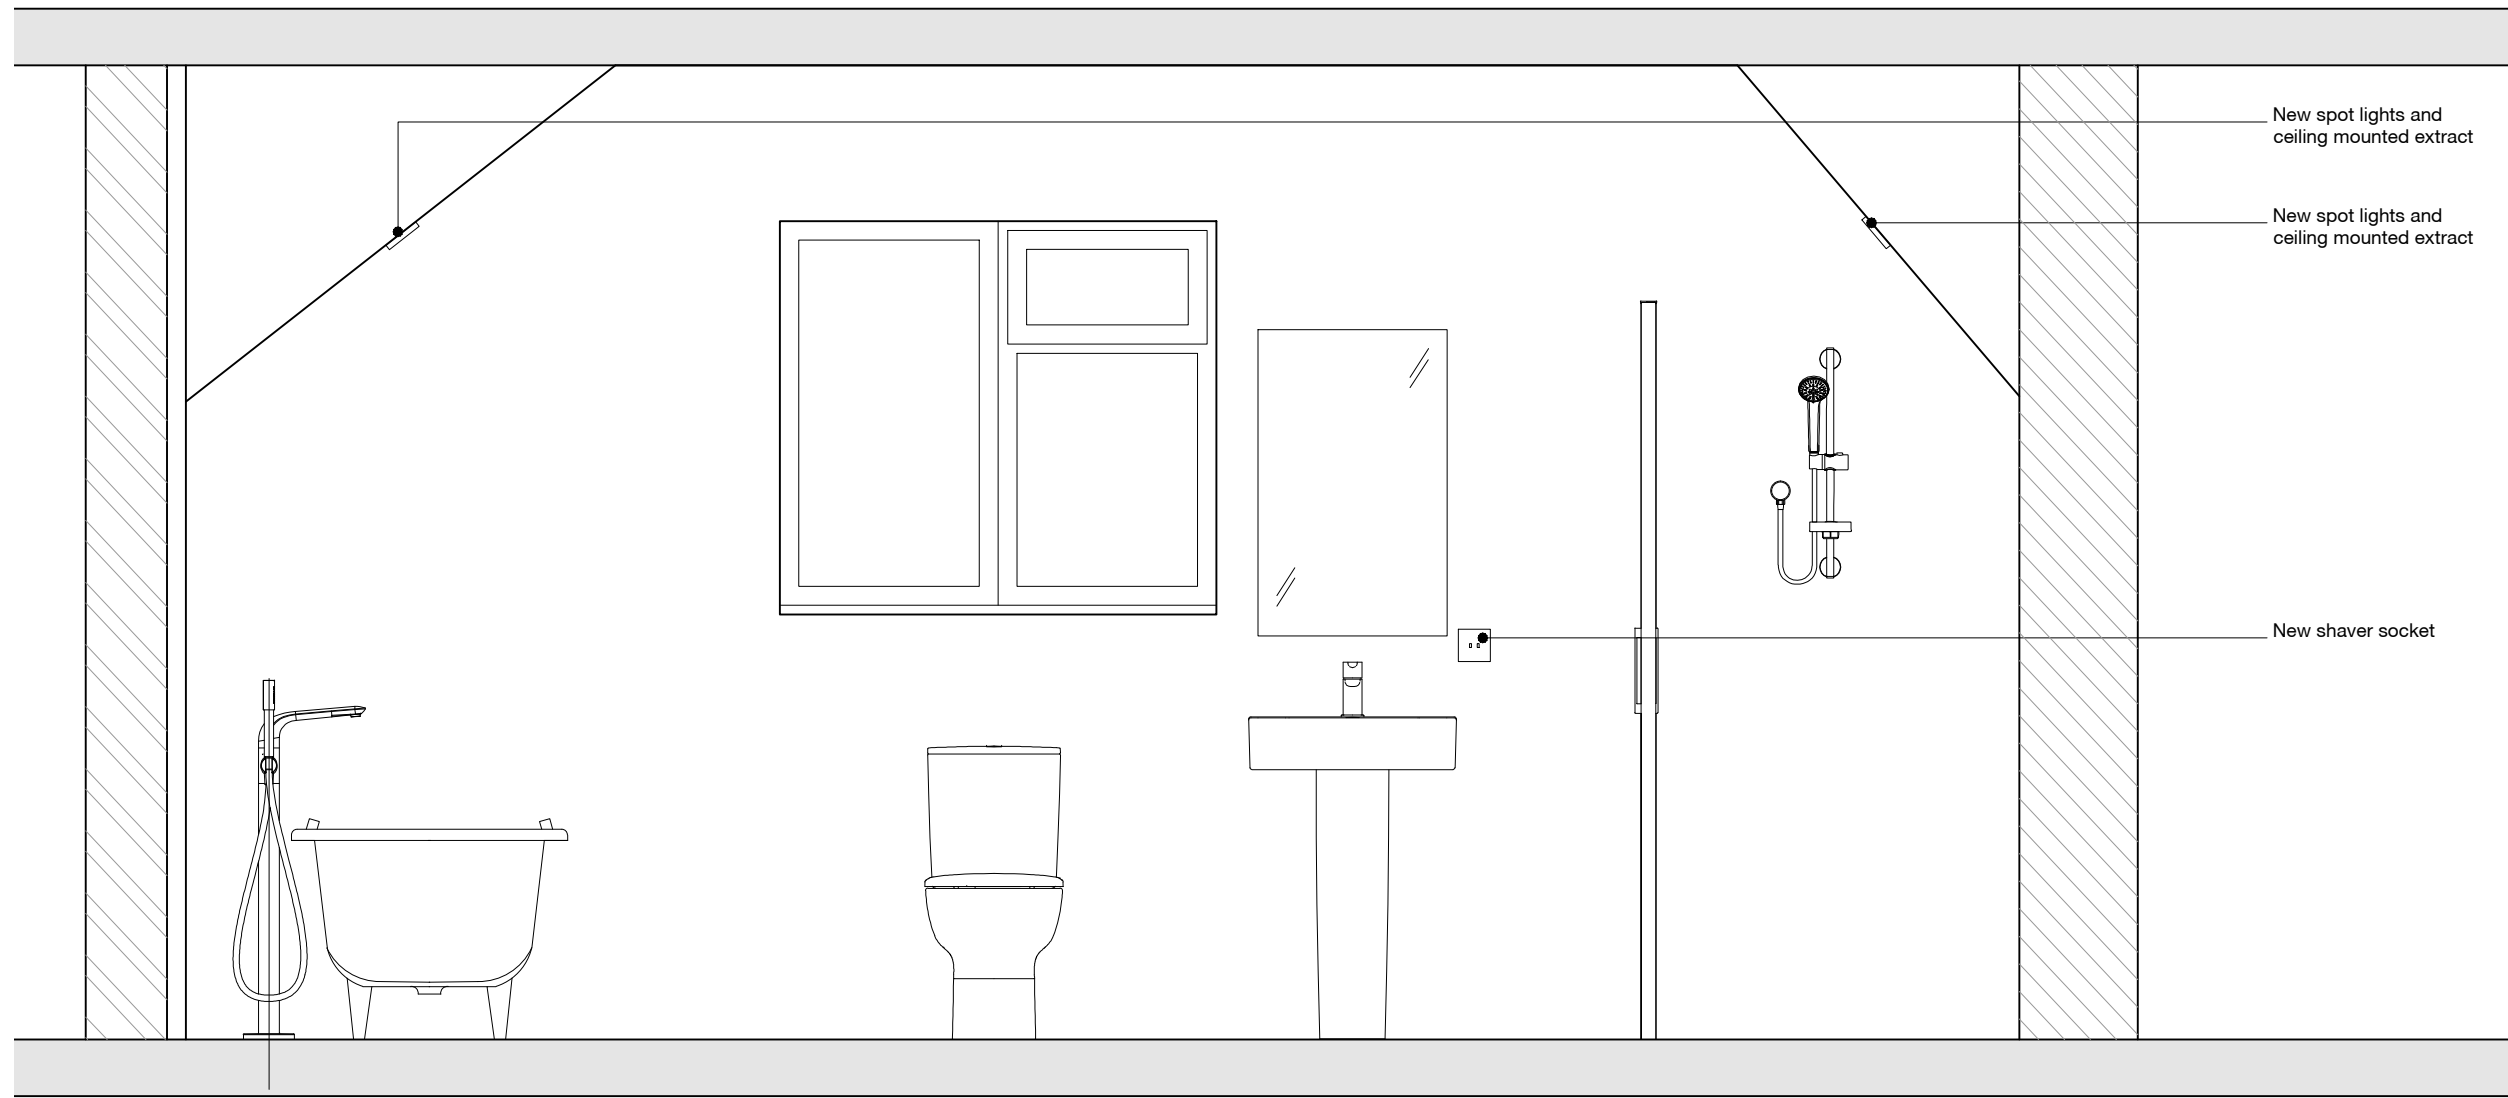


ELEVATION 01

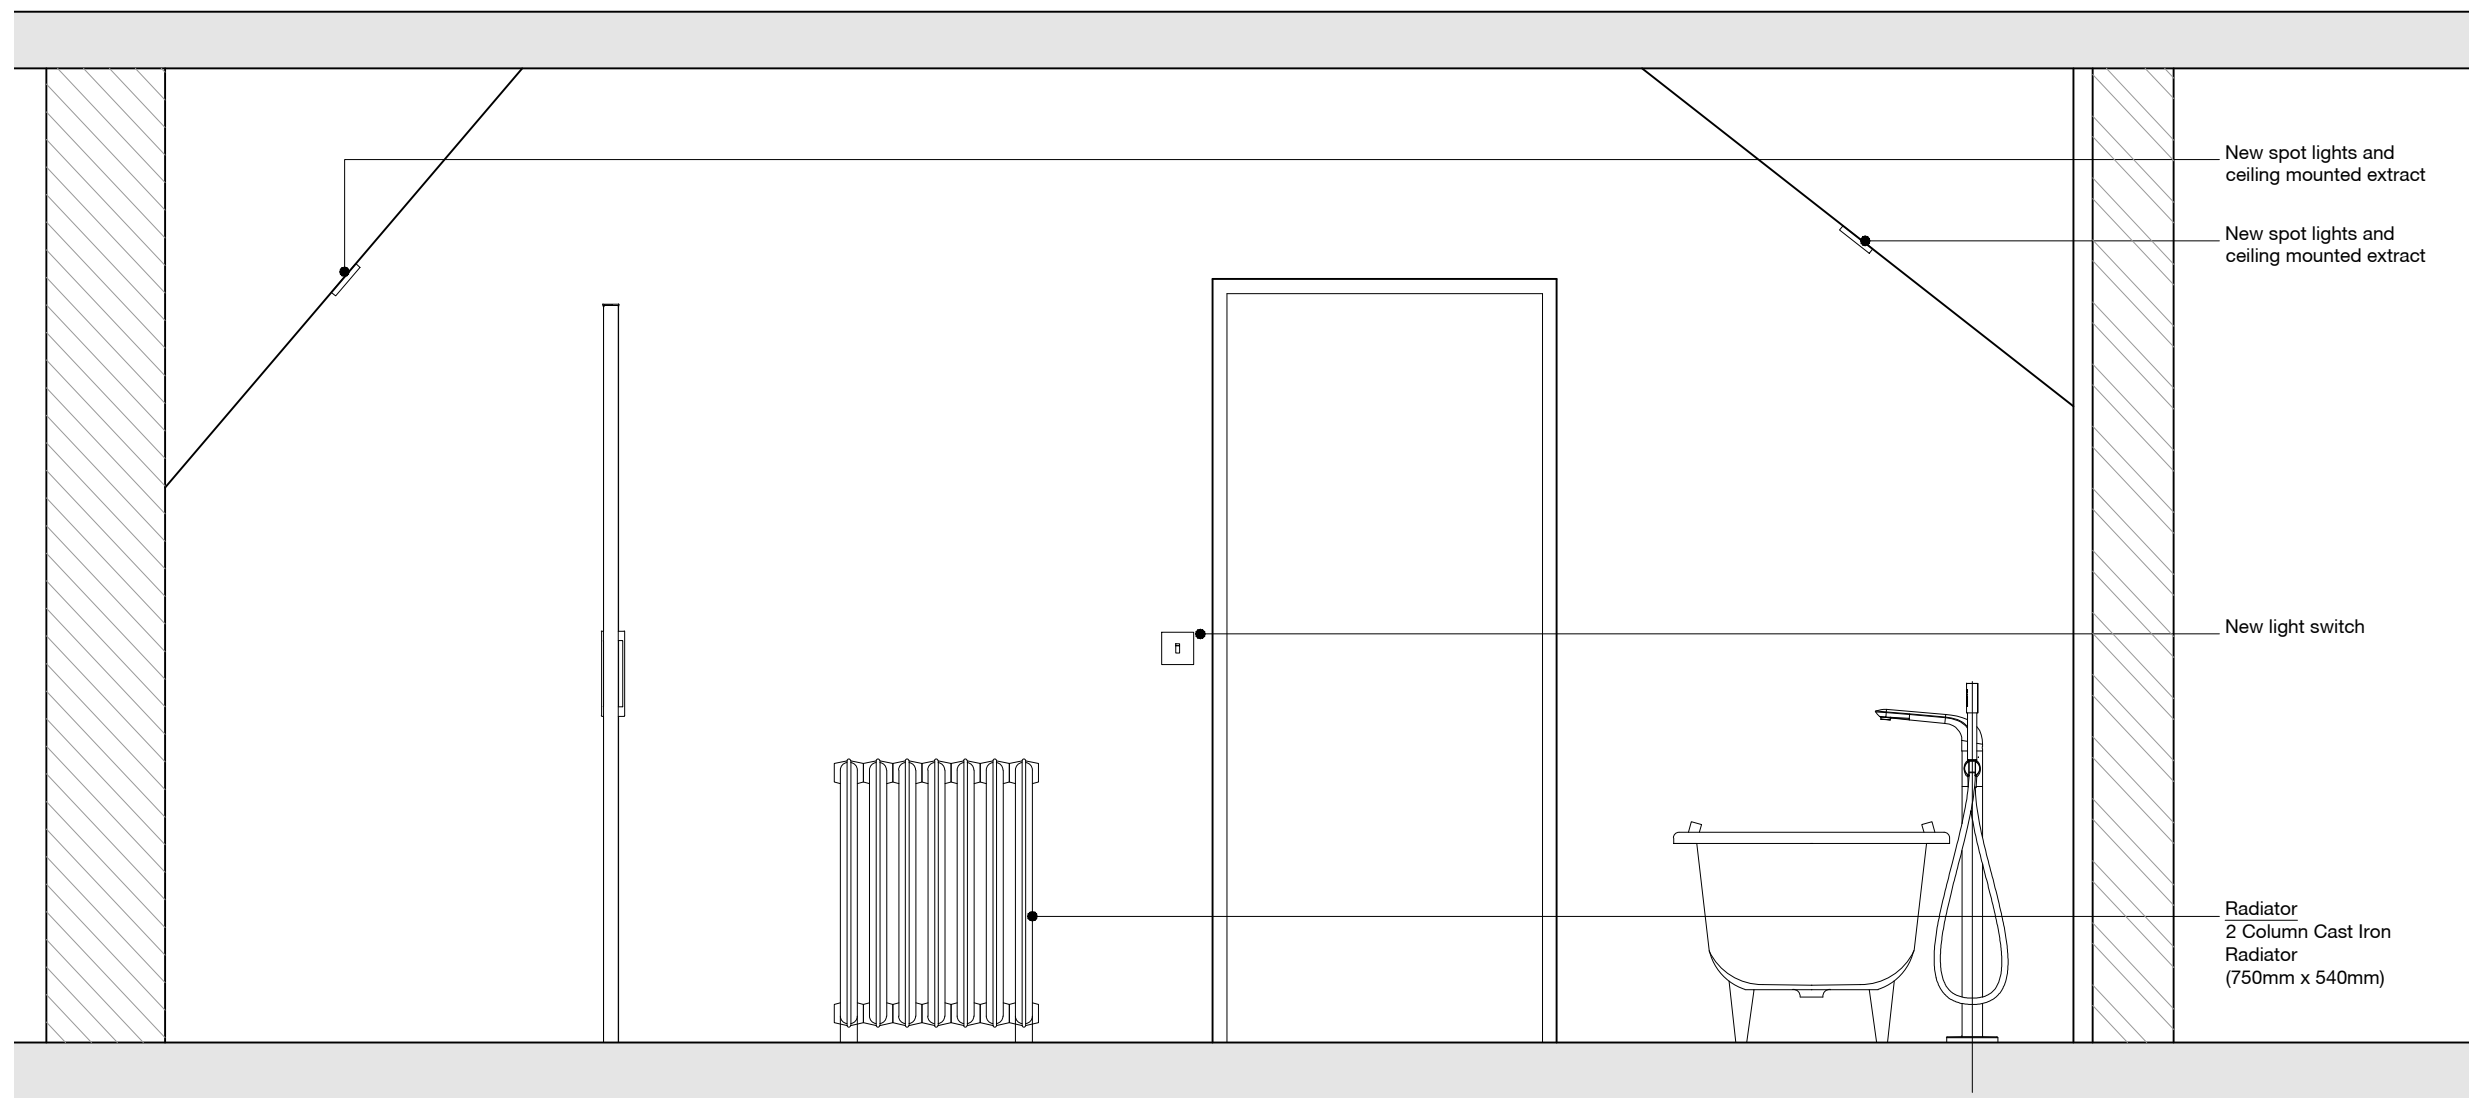

ELEVATION 03

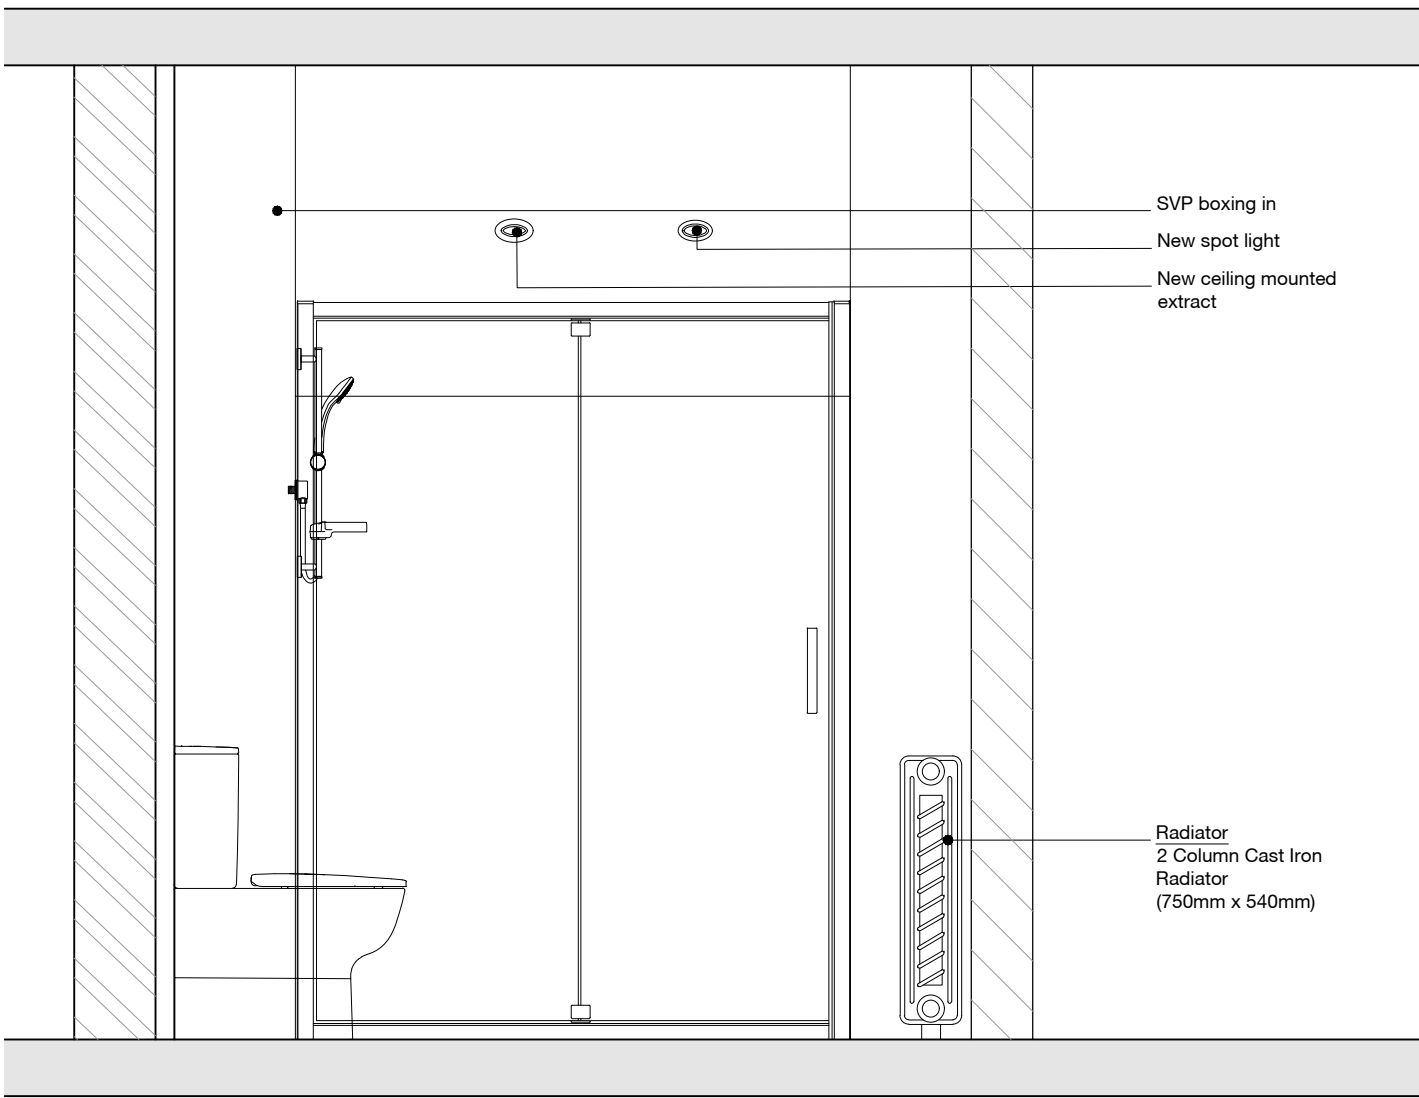

ELEVATION 02

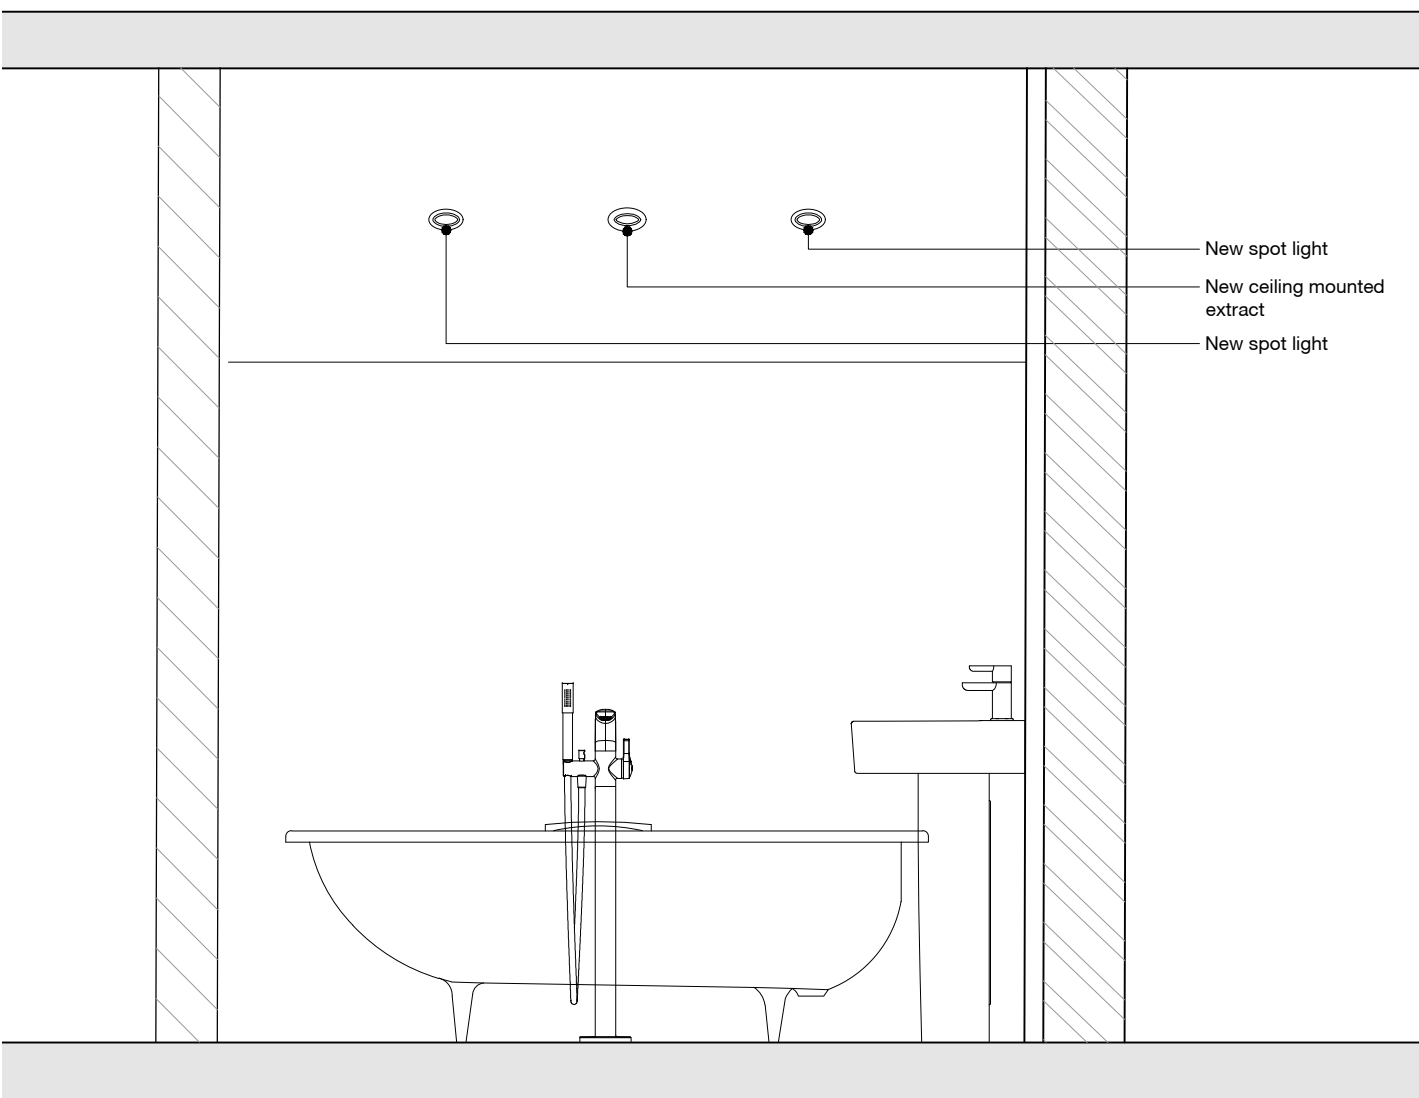

ELEVATION 04

Notes | Sketch schemes may be based on plan information of unknown origin and is subject to verification and survey. Contractors must verify all dimensions on site before commencing any work or shop drawings. This drawing is not to be scaled. Use figured dimensions only. Ensure digital versions are printed at 'Actual Size'. Building areas are liable to adjustment over the course of the design process due to ongoing construction detailing developments. Subject to statutory approvals and survey. The bar above is to check that the drawing has been printed to scale.

KEY TO ELECTRIC SYMBOLS
Existing Shown Black / Proposed Shown Blue / Removed Shown Red

NOTE: Height of sockets and switches in habitable rooms to be in accordance with Building Regulations Part M (between 450mm and 1200mm above finished floor level.) Refer to Employers requirements for other mounting heights. Heating and Electrical Layouts to Sub Contractors Design. Extracts and boiler positions (where shown) indicative only. Final position determined by M&E designer.

Contractor Design portions


Allow sum for installation of new wiring circuit to facilitate room layout and electrical requirements accordingly. This work shall be carried out by a competent approved and certified NICEIC electrical installer or similar. This shall be to the latest Edition and all current amendments revisions. Electrician to design and plan out the positions of socket outlets and light switch gear in accordance with construction drawings and the client's requirements and brief. A test certificate and commissioning certification should be provided on completion of all electrical work.

Allow sum for management / design and installation of burglar alarm. Burglar alarm to be contractor designed; however all windows and doors to receive contacts, with the rest of the property to be supplemented with PIR's.

Supply and fit new boiler and vented central heating / hot water system (Vaillant / Worcester Bosch or similar approved boilers).

Supply and fit new large water cistern and water tank to accommodate heating and hot water requirements.

Supply and fit Skelrad Softline K2 radiators or similar approved with TRV's, Peglar or Danfoss to suit. All pipe work above floor level to be in polished chrome or other metal pipe work or alternatively copper tails with chrome clip on pipe covers. Grey Hep20 pipe work will not be permitted above floor finishes.

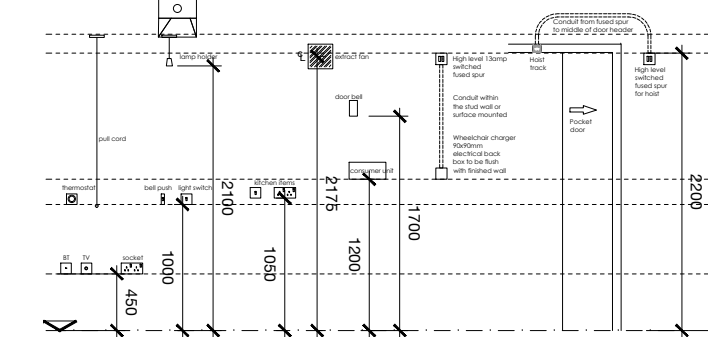

NOTE: Height of sockets and switches in habitable rooms to be in accordance with Building Regulations Part M (between 450mm and 1200mm above finished floor level.) Refer to Employers requirements for other mounting heights. Heating and Electrical Layouts to Sub Contractors Design. Extracts and boiler positions (where shown) indicative only. Final position determined by M&E designer.

Contractor Design portions

Allow sum for installation of new wiring circuit to facilitate room layout and electrical requirements accordingly. This work shall be carried out by a competent approved and certified NICEIC electrical installer or similar. This shall be to the latest Edition and all current amendments revisions. Electrician to design and plan out the positions of socket outlets and light switch gear in accordance with construction drawings and the client's requirements and brief. A test certificate and commissioning certification should be provided on completion of all electrical work.

Allow sum for management / design and installation of burglar alarm. Burglar alarm to be contractor designed; however all windows and doors to receive contacts, with the rest of the property to be supplemented with PIR's.

Supply and fit new boiler and vented central heating / hot water system (Vaillant / Worcester Bosch or similar approved boilers).

Supply and fit new large water cistern and water tank to accommodate heating and hot water requirements.

Supply and fit Skelrad Softline K2 radiators or similar approved with TRV's, Peglar or Danfoss to suit. All pipe work above floor level to be in polished chrome or other metal pipe work or alternatively copper tails with chrome clip on pipe covers. Grey Hep20 pipe work will not be permitted above floor finishes.

All internal walls to be 150mm:
100x50mm SVP Studing at 400mm C/C with 12.5mm British Gypsum plasterboard and skim on 12.5mm marine grade plywood. Sound insulation lightly packed between studs to achieve min 40 dB.

All external walls to be British Gypsum insulated plasterboard and skim

B	13.01.22	Insulation zone reduced to external walls. Internal walls to be typical timber stud build up. Lime mortar omitted.	po	rsq
A	25.11.21	Job number and drawing number changed from 0759 - EA - A - C045 - Proposed Internal Elevations - FF En-Suite 01 Condition 06	po	rsq

Rev	Date	Description	Drawn	Checked
Project	For & on behalf of Irwin Mitchell Holt Hill, Green Street, Holt, Wrexham			
Drawing	Proposed Internal Elevations - FF En0Suite 01			
Client	CE			
BIM Subability Description				BIM Subability Code
SUITABLE FOR CONSTRUCTION				A
Status	Construction			
Date	Nov '20	2 Riverside Way Wrexham Waterfront LEEDS	320 City Road Angel LONDON	
Drawn	po	LS1 4EH 01173 816 8241	ECW 2N2 0203 885 8852	
Checked	rsq	e info@edwardarchitectur.co.uk		
Scale (A1)	1:20	e info@edwardarchitectur.co.uk		
0961 - EA - A - PL141 - B				edward architecture