


Final kitchen design by Symphony
Final heating design by Vaillant
Final sprinkler design by Homesafe

Final kitchen design by Symphony
Final heating design by Vaillant
Final sprinkler design by Homesafe

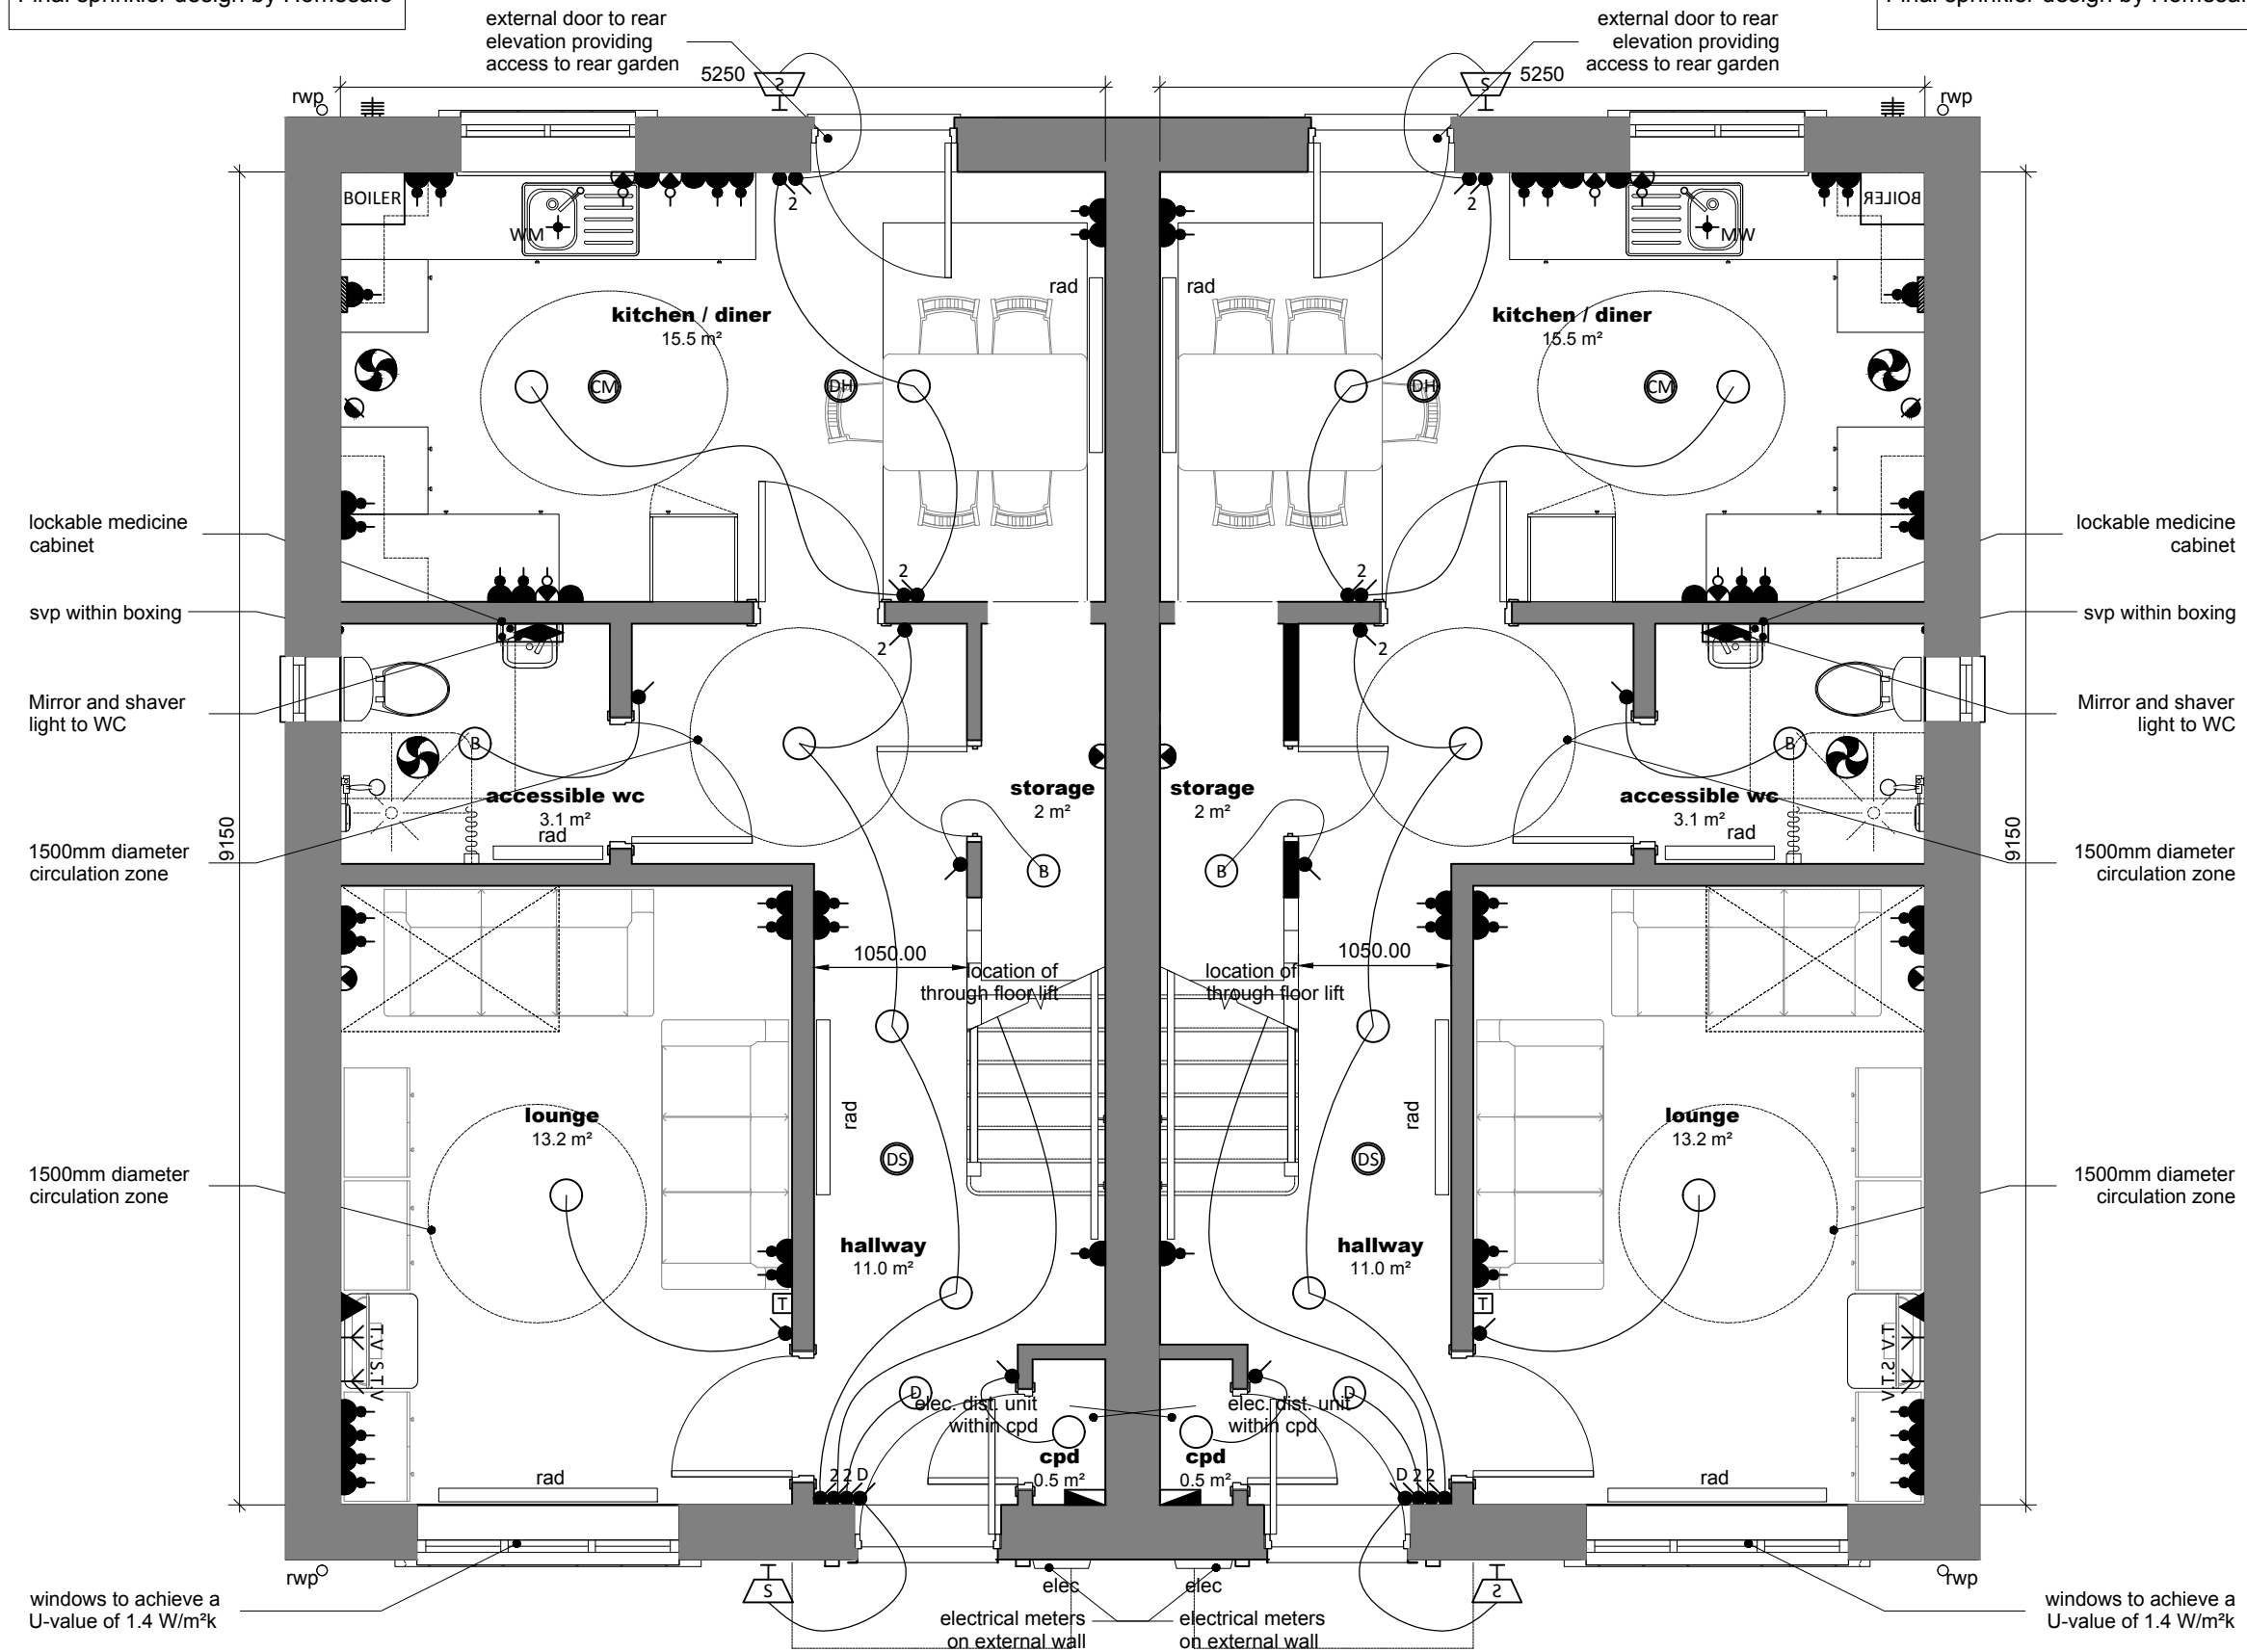

Ground Floor Plan

HDS ARCHITECTURAL SERVICES
Ferndale Villa, 25 Manley Road,
Wrexham, LL13 8HD
Tel (01978) 353445
www.hdsarchitectural.co.uk

Project; Residential Development to Land Adjoining 'Premier Inn', Jacques Way, Wrexham	
Title; Plots 2 - 5 Ground Floor Plan	Scale (A3); 1:50
Dwg No; JWA/PD/08	Date; July 2018
Revision;	