




0	1	2	3	4	5	6	7	8	9
 OM LETTINGS									
Company House Details Drawing Rev No. O&M Lettings Ltd 31 Watery Road Plans Revision 1									
Edit date 04/11/2021 by James Bulkeley Number of Pages - 17									
Revision	Date	Description	Drawn By	App By	 OM LETTINGS	COVER PAGE	N/A		= +
R01	25/10/2021	Original Issue	JB	CT					Page 1
R02			JB	CT					Page 17
R03			JB	CT			31 Watery Road Plans		

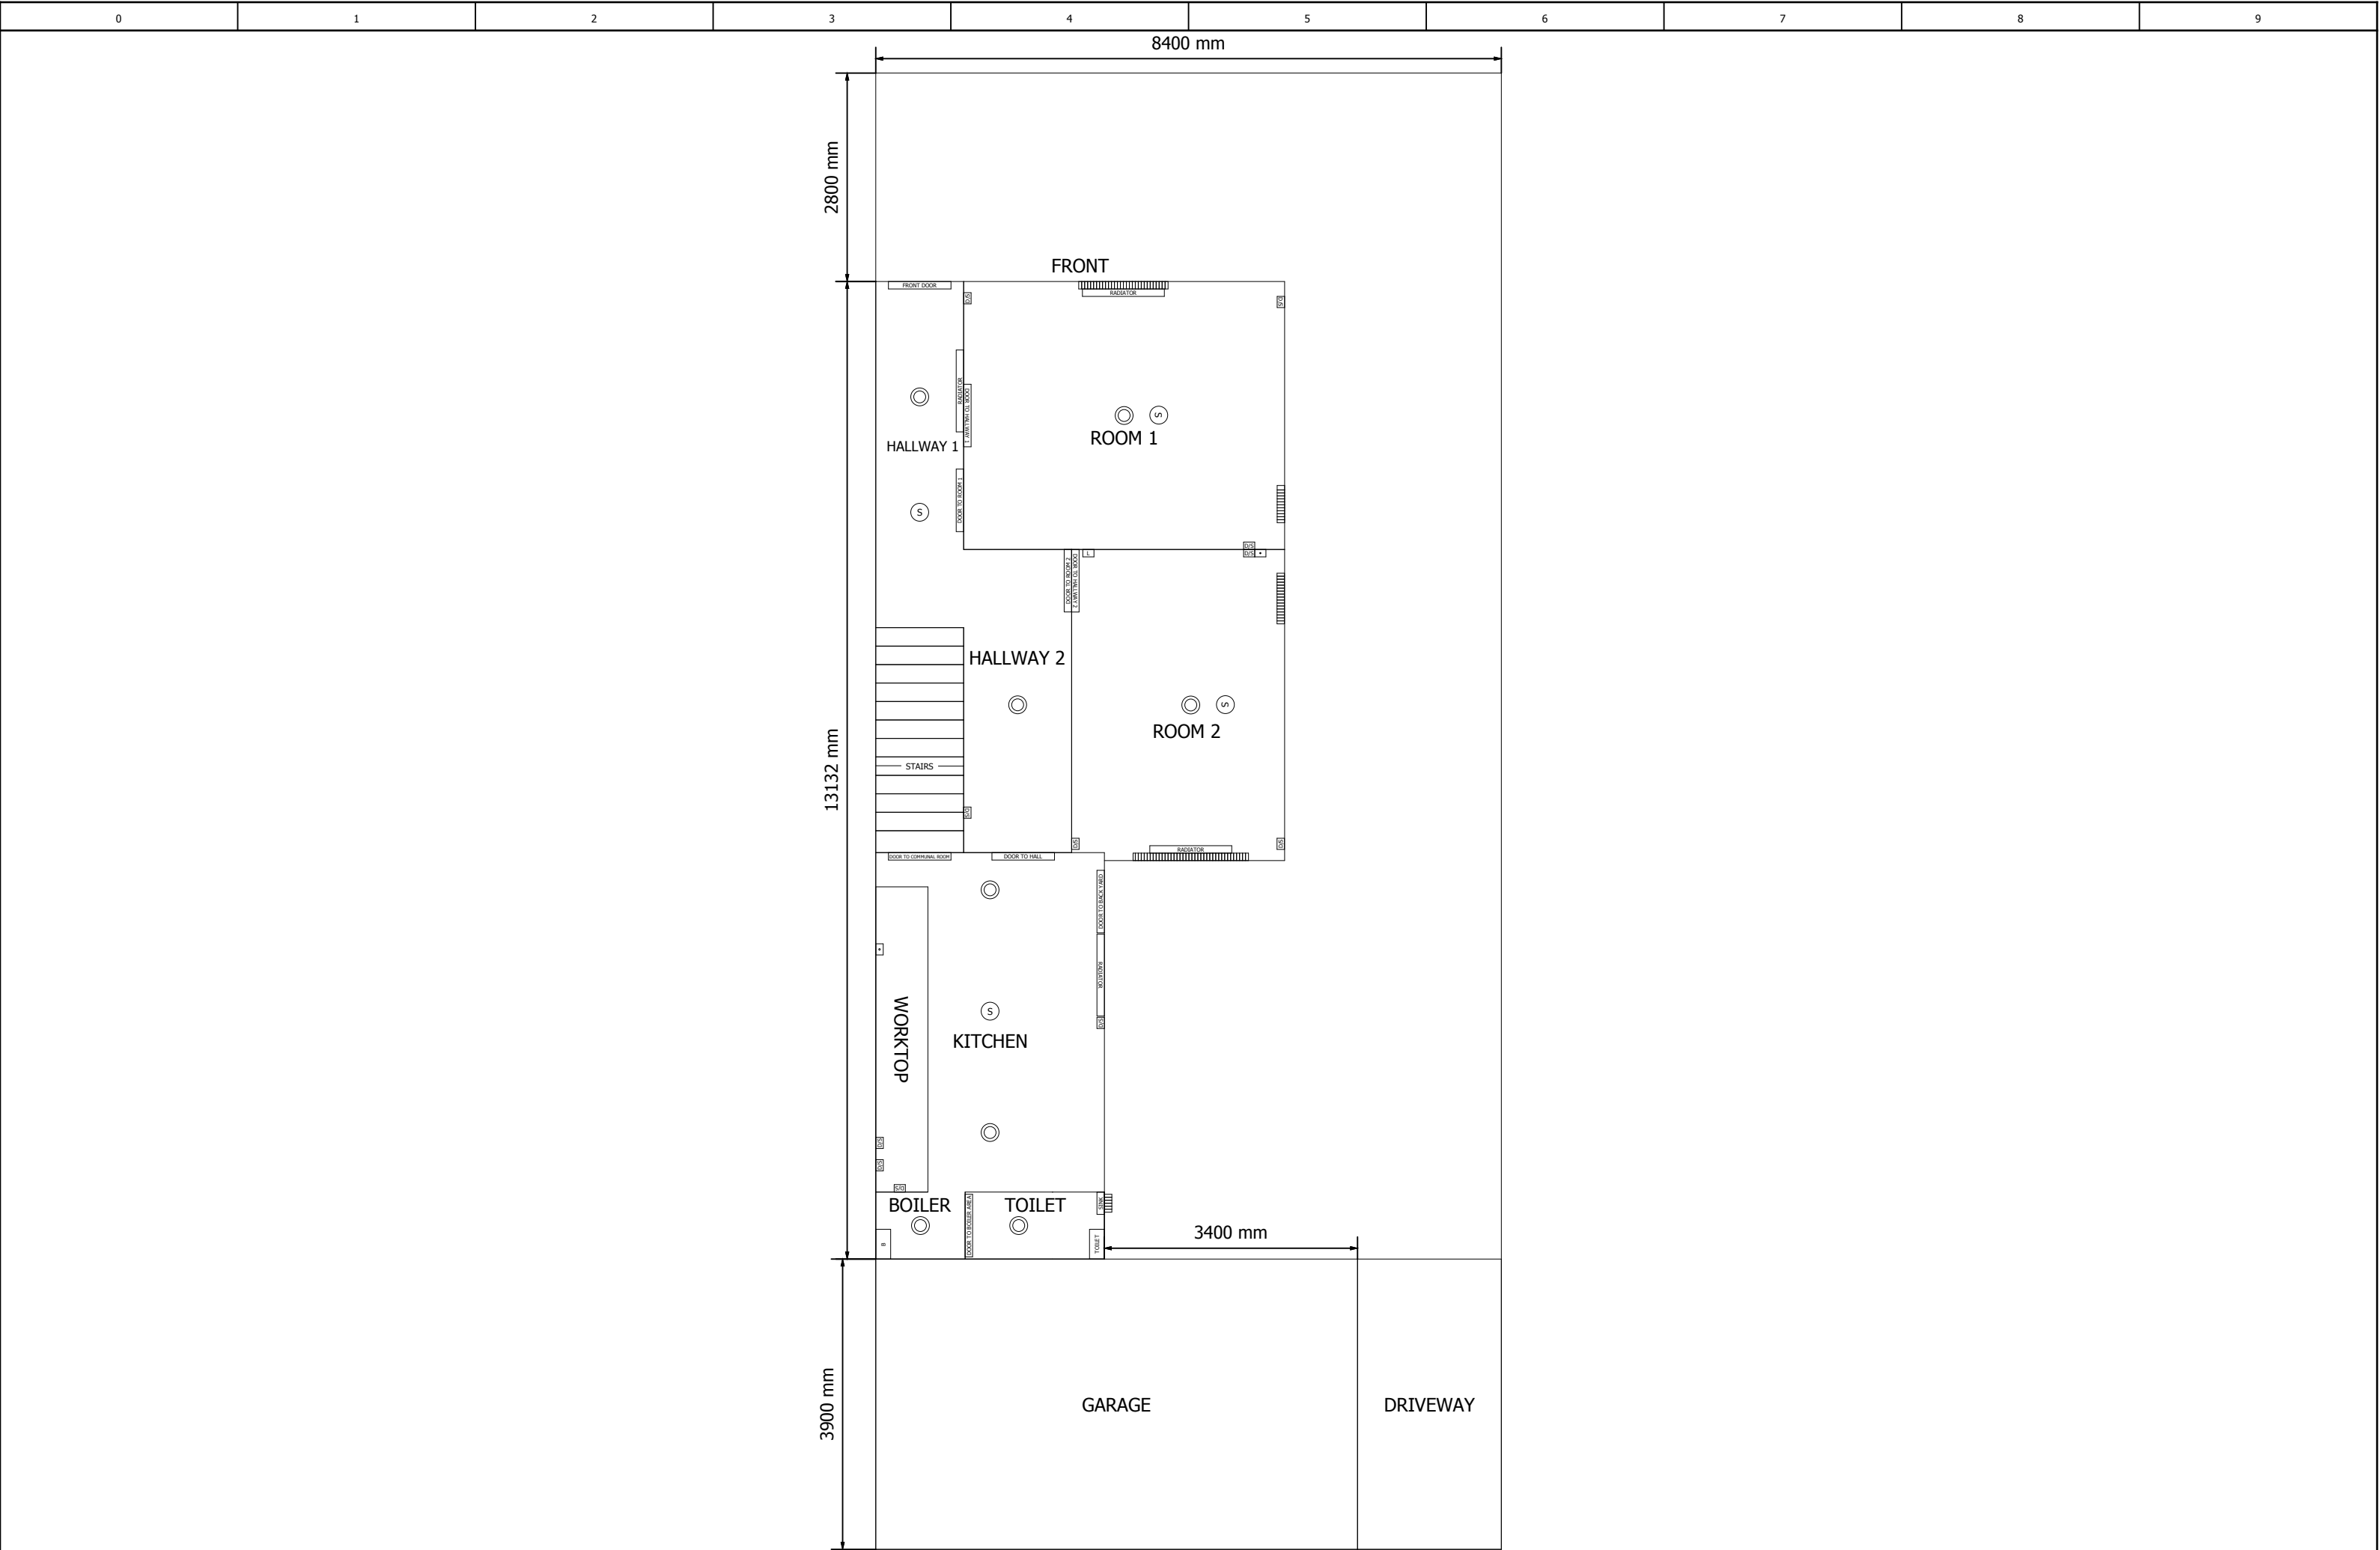


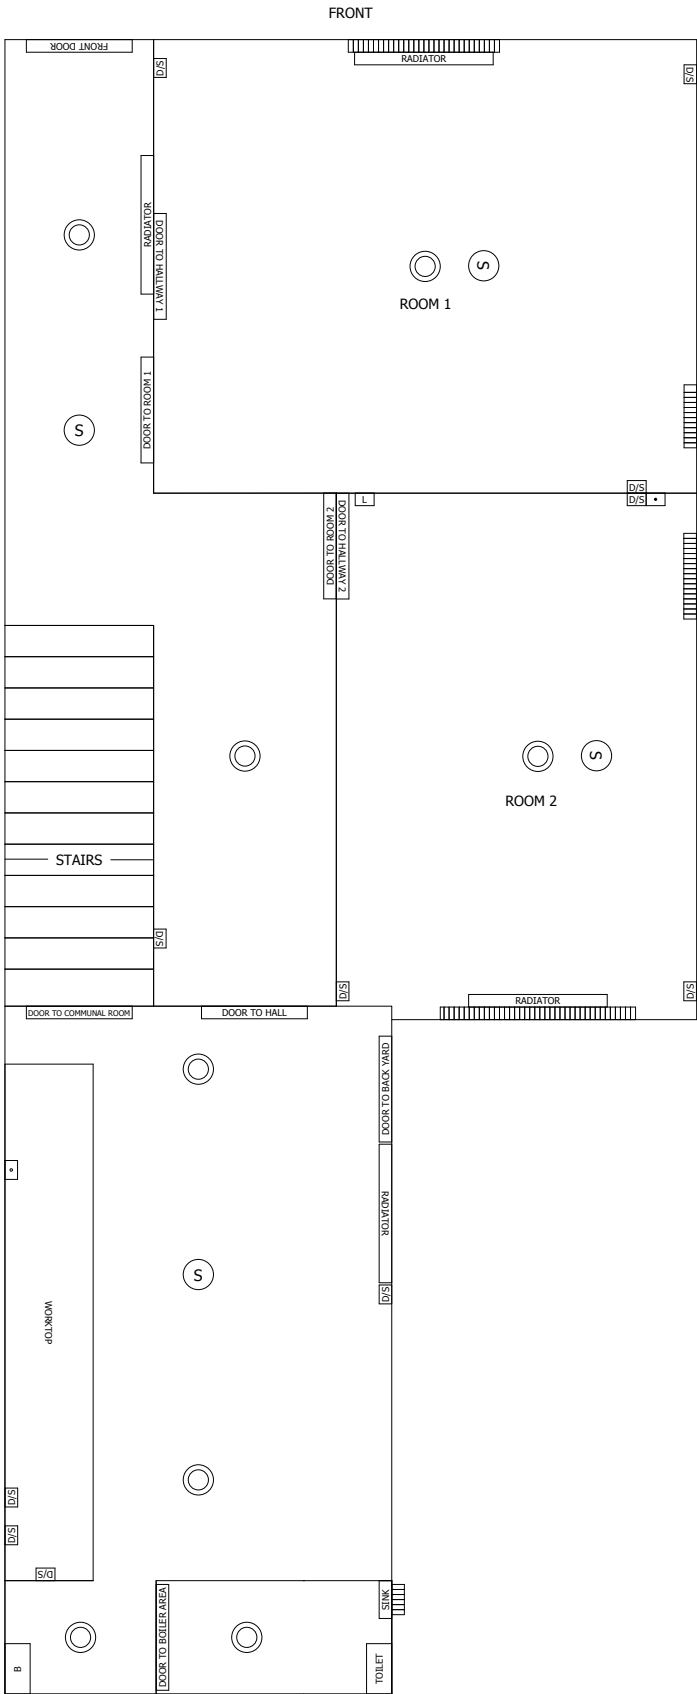

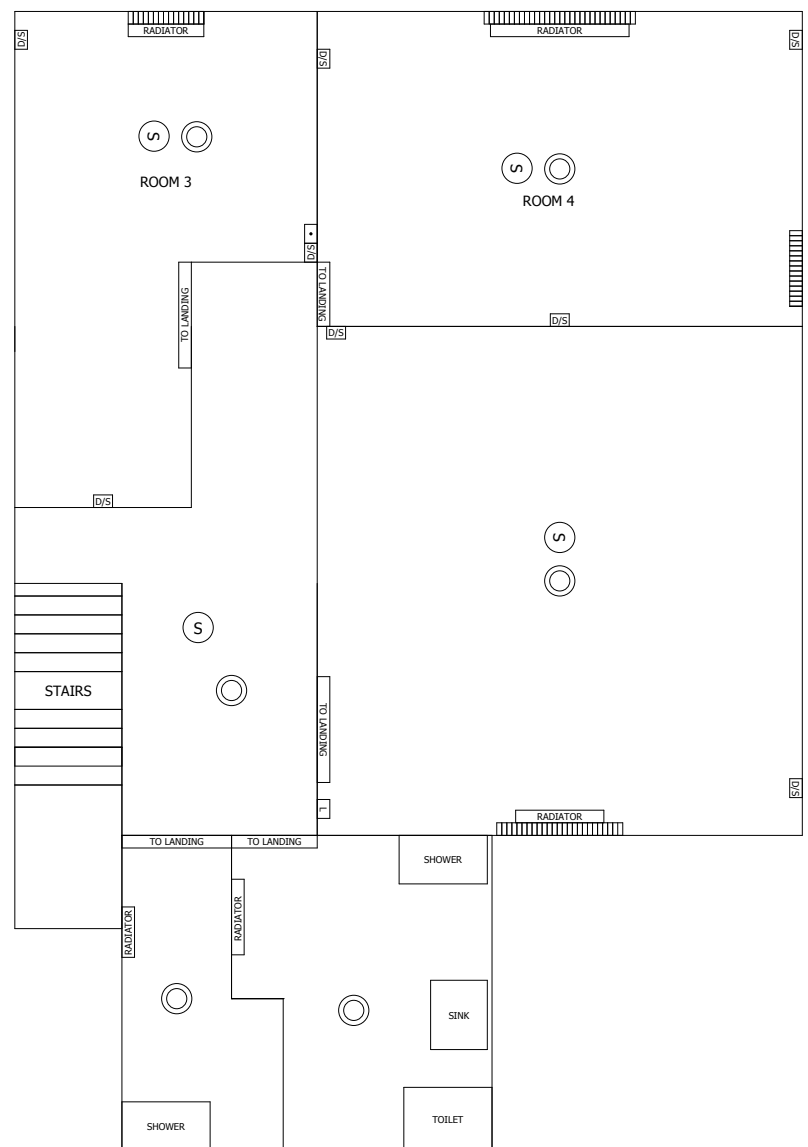


Revision	Date	Description	Drawn By	App By		UPSTAIRS OVERVIEW	N/A		=	
R01	25/10/2021	Original Issue	JB	CT					+	
R02			JB	CT						
R03			JB	CT						

0	1	2	3	4	5	6	7	8	9
SYMBOL KEY									
DOOR	DOOR								
RADIATOR	RADIATOR								
D/S	DOUBLE SOCKET								
S	SMOKE ALARM								
LS	LIGHT SENSOR								
⊙	LIGHT								
■	FUSE SWITCH								
◦	OVEN SWITCH & SOCKET								
A	ATTICK DOOR								
B	BOILER								
SM	SMART METRE								
F	FAN								
S/S	SINGLE SOCKET								

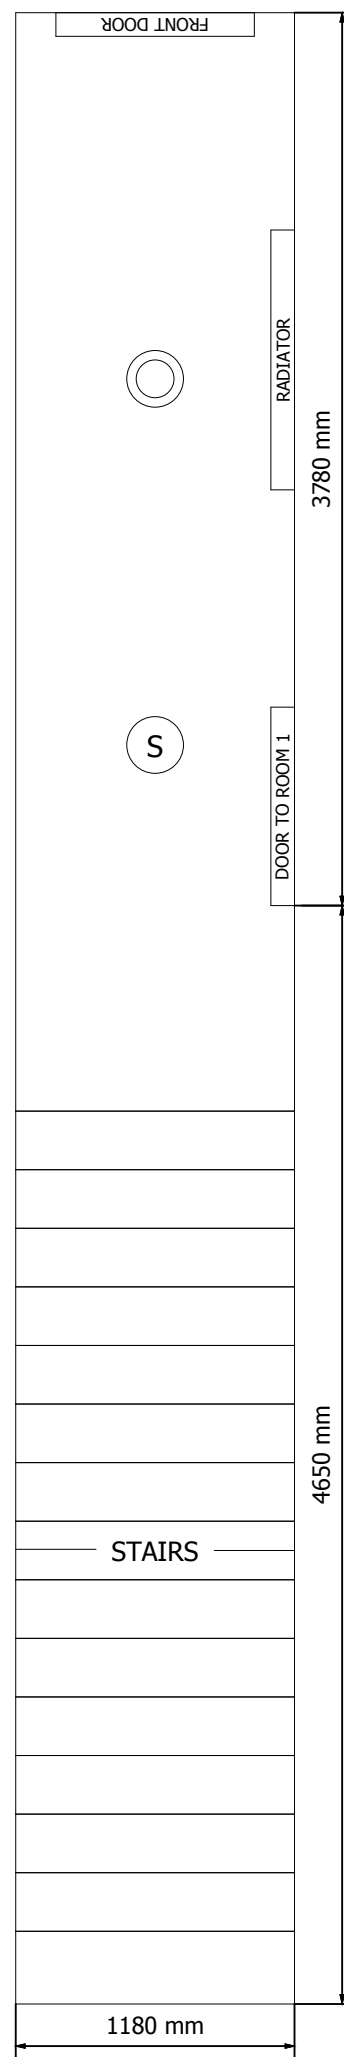

Revision	Date	Description	Drawn By	App By		HALLWAY 1	N/A		
R01	25/10/2021	Original Issue	JB	CT					
R02			JB	CT			31 Watery Road Plans	Page	6
R03			JB	CT				Page	17

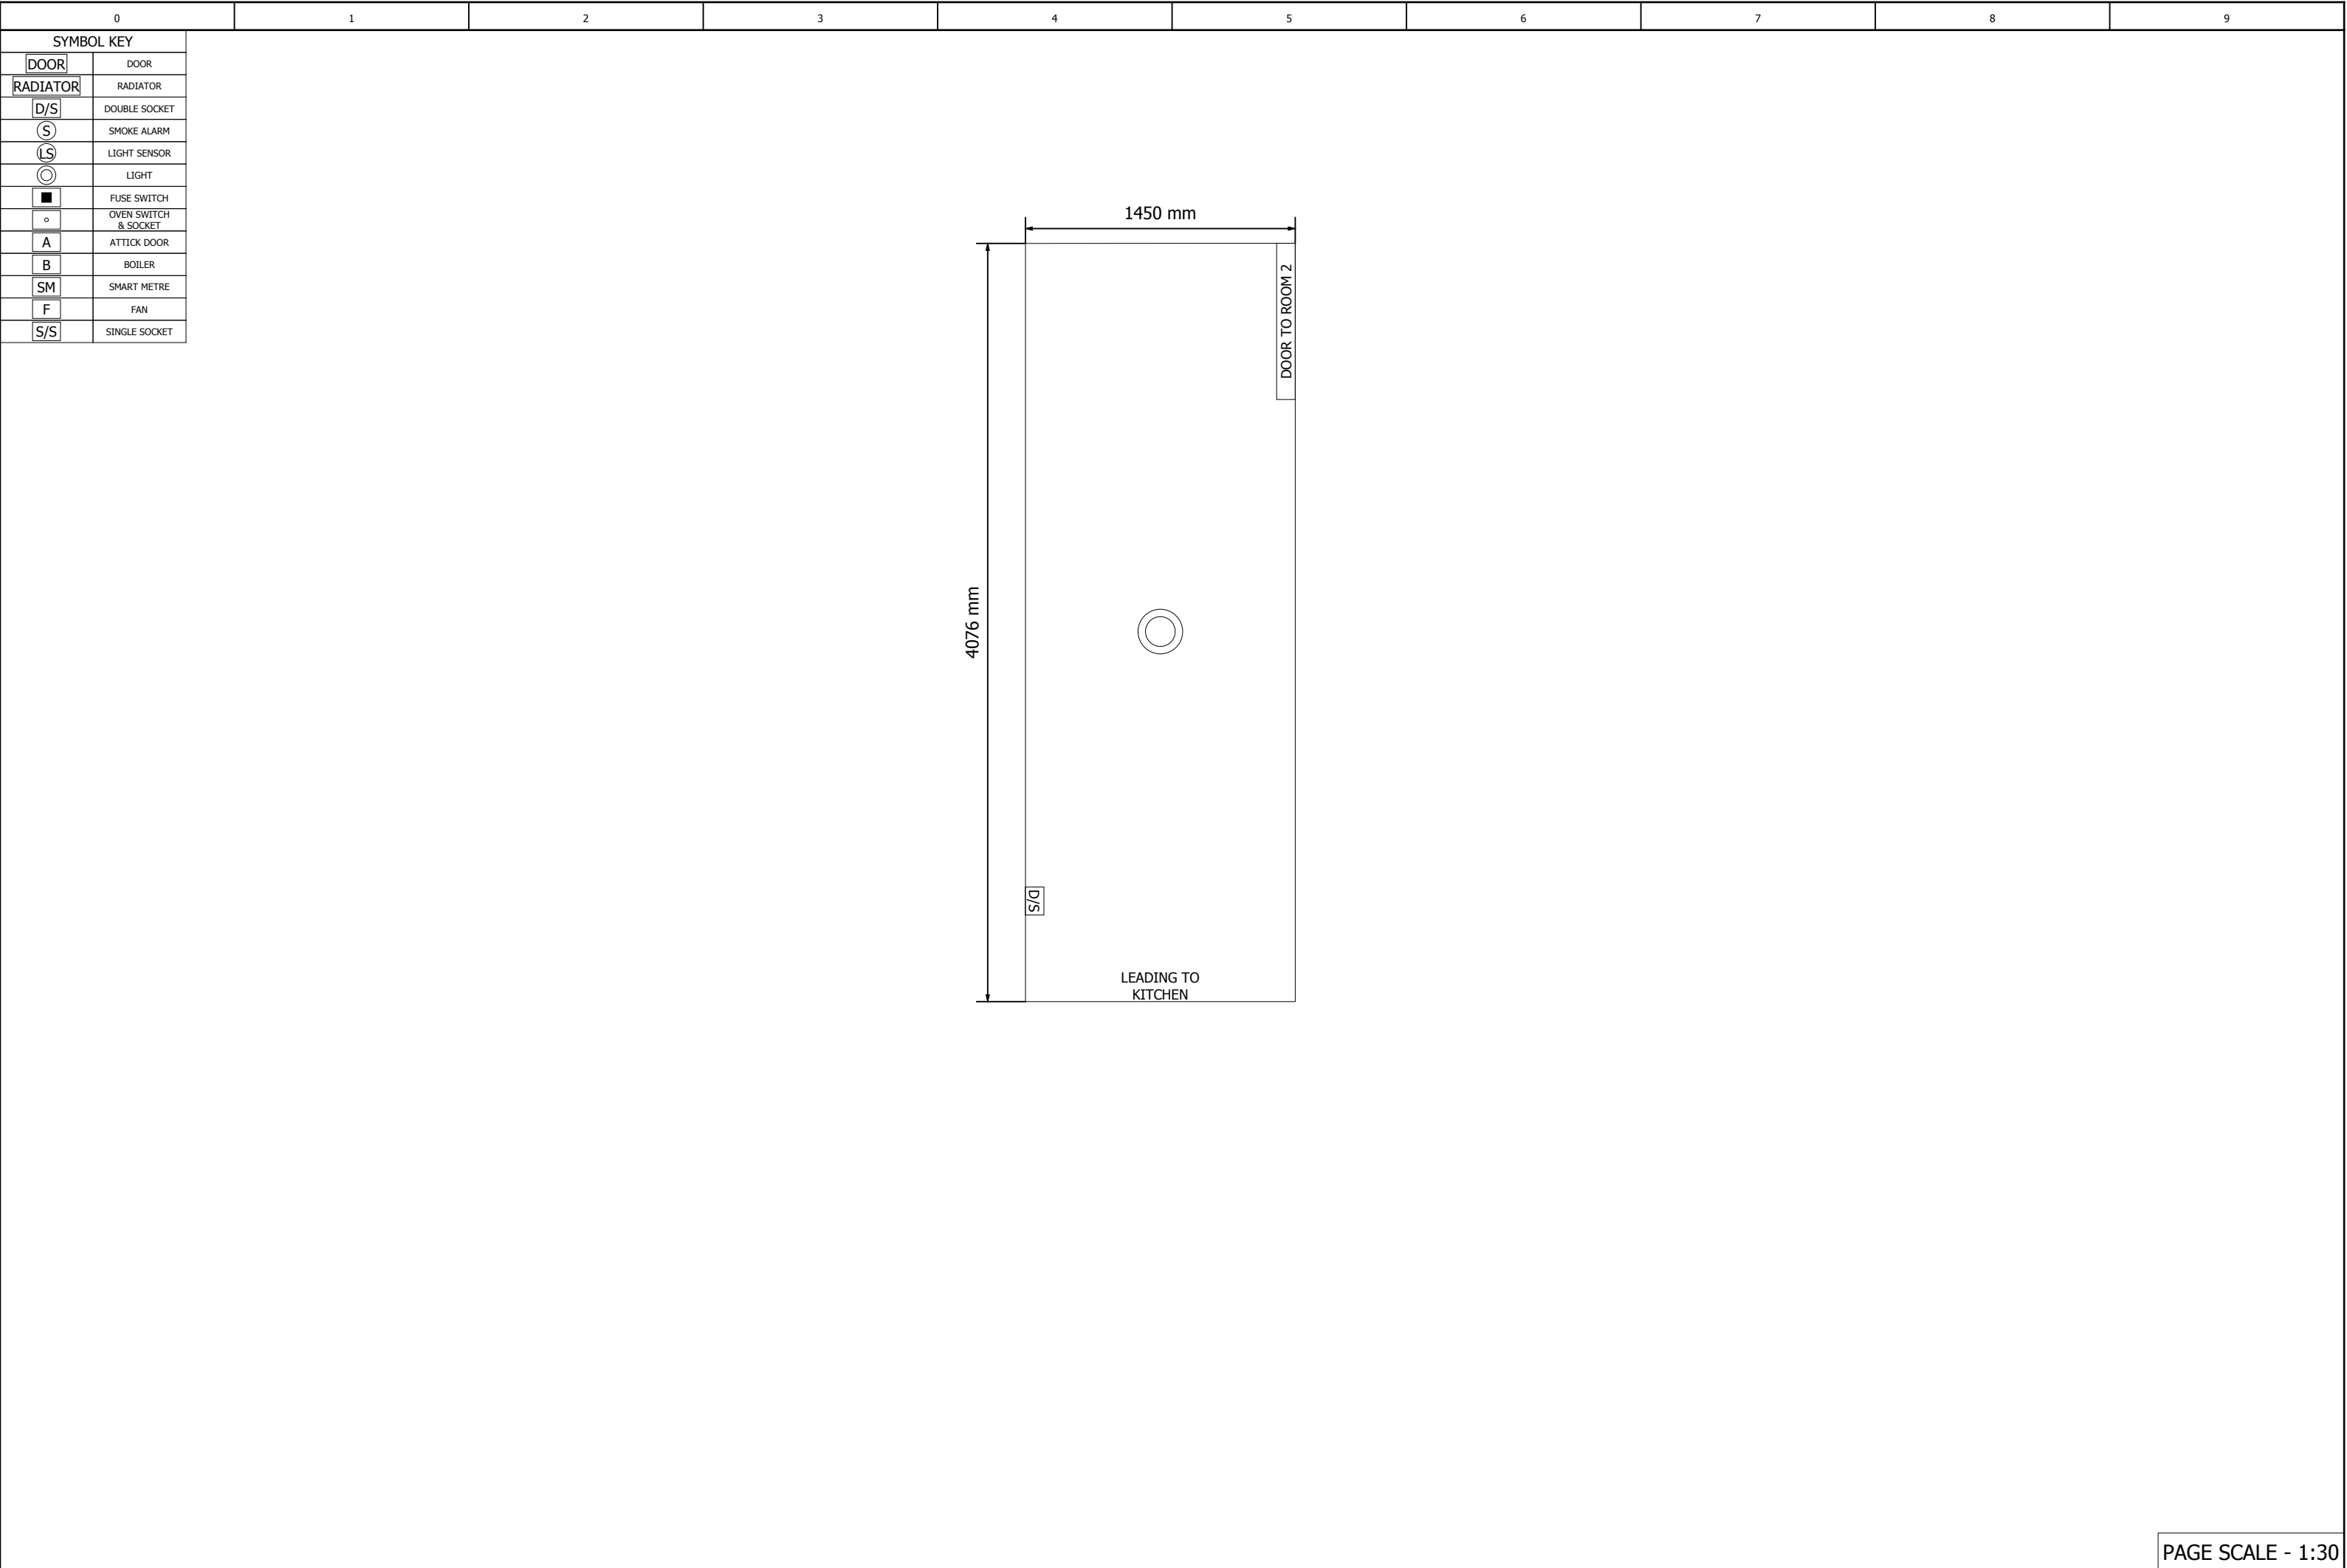


SYMBOL KEY	
	DOOR
	RADIATOR
	DOUBLE SOCKET
	SMOKE ALARM
	LIGHT SENSOR
	LIGHT
	WINDOW
	LIGHT SWITCH
	TV POINT
	CONSUMER UNIT
	FIRE PLACE
	FUSE SWITCH
	OVEN SWITCH & SOCKET
	ATTICK DOOR
	BOILER
	SMART METRE
	FAN
	SINGLE SOCKET

The floor plan shows a rectangular room with overall dimensions of 3070 mm by 700 mm. The room contains a central circular feature, likely a light or vent. On the left wall, there is a door labeled "DOOR TO COMMUNAL ROOM". On the right wall, there are two doors: "DOOR TO HALL" and "DOOR TO BACK YARD". A radiator is located along the bottom wall. Various symbols from the key are placed throughout the room, including a double socket, smoke alarm, light sensor, light, window, light switch, TV point, consumer unit, fire place, fuse switch, oven switch & socket, attick door, boiler, smart metre, fan, and single socket.




		PAGE SCALE TWO	
=			
+			
		Page	9
		Page	17

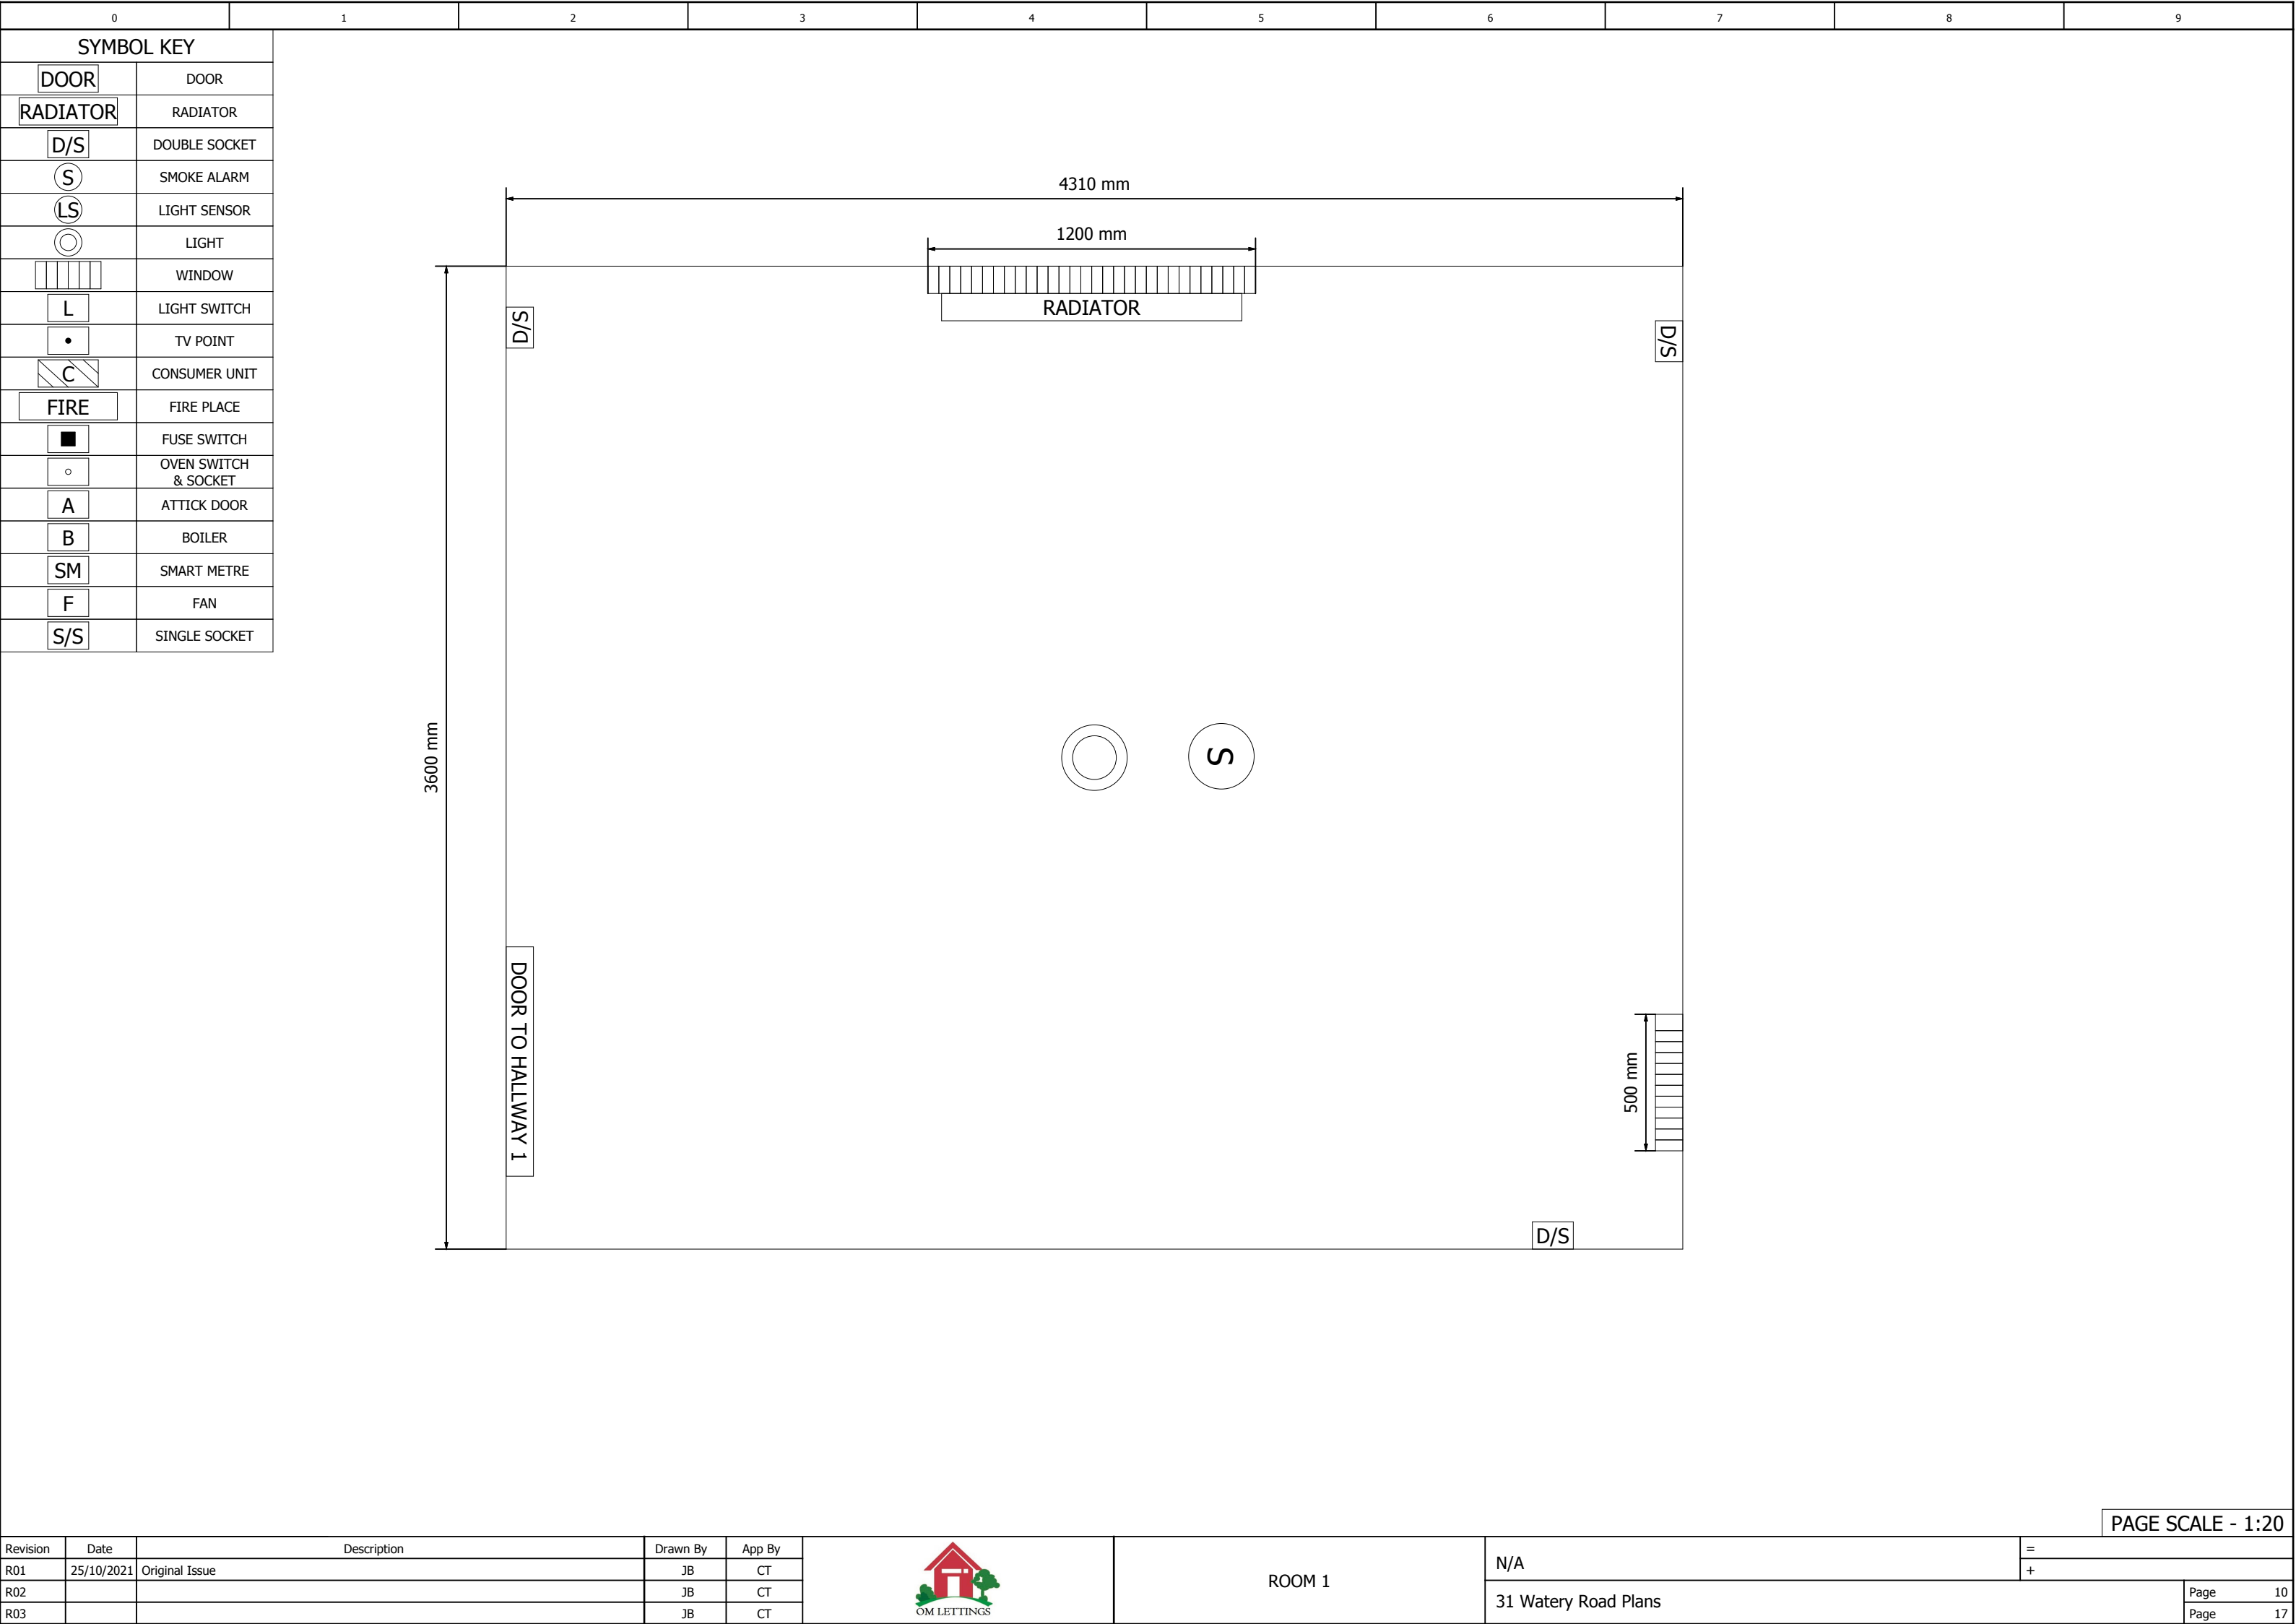



0	1	2	3	4	5	6	7	8	9
---	---	---	---	---	---	---	---	---	---


SYMBOL KEY	
	DOOR
	RADIATOR
	DOUBLE SOCKET
	SMOKE ALARM
	LIGHT SENSOR
	LIGHT
	WINDOW
	LIGHT SWITCH
	TV POINT
	CONSUMER UNIT
	FIRE PLACE
	FUSE SWITCH
	OVEN SWITCH & SOCKET
	ATTICK DOOR
	BOILER
	SMART METRE
	FAN
	SINGLE SOCKET

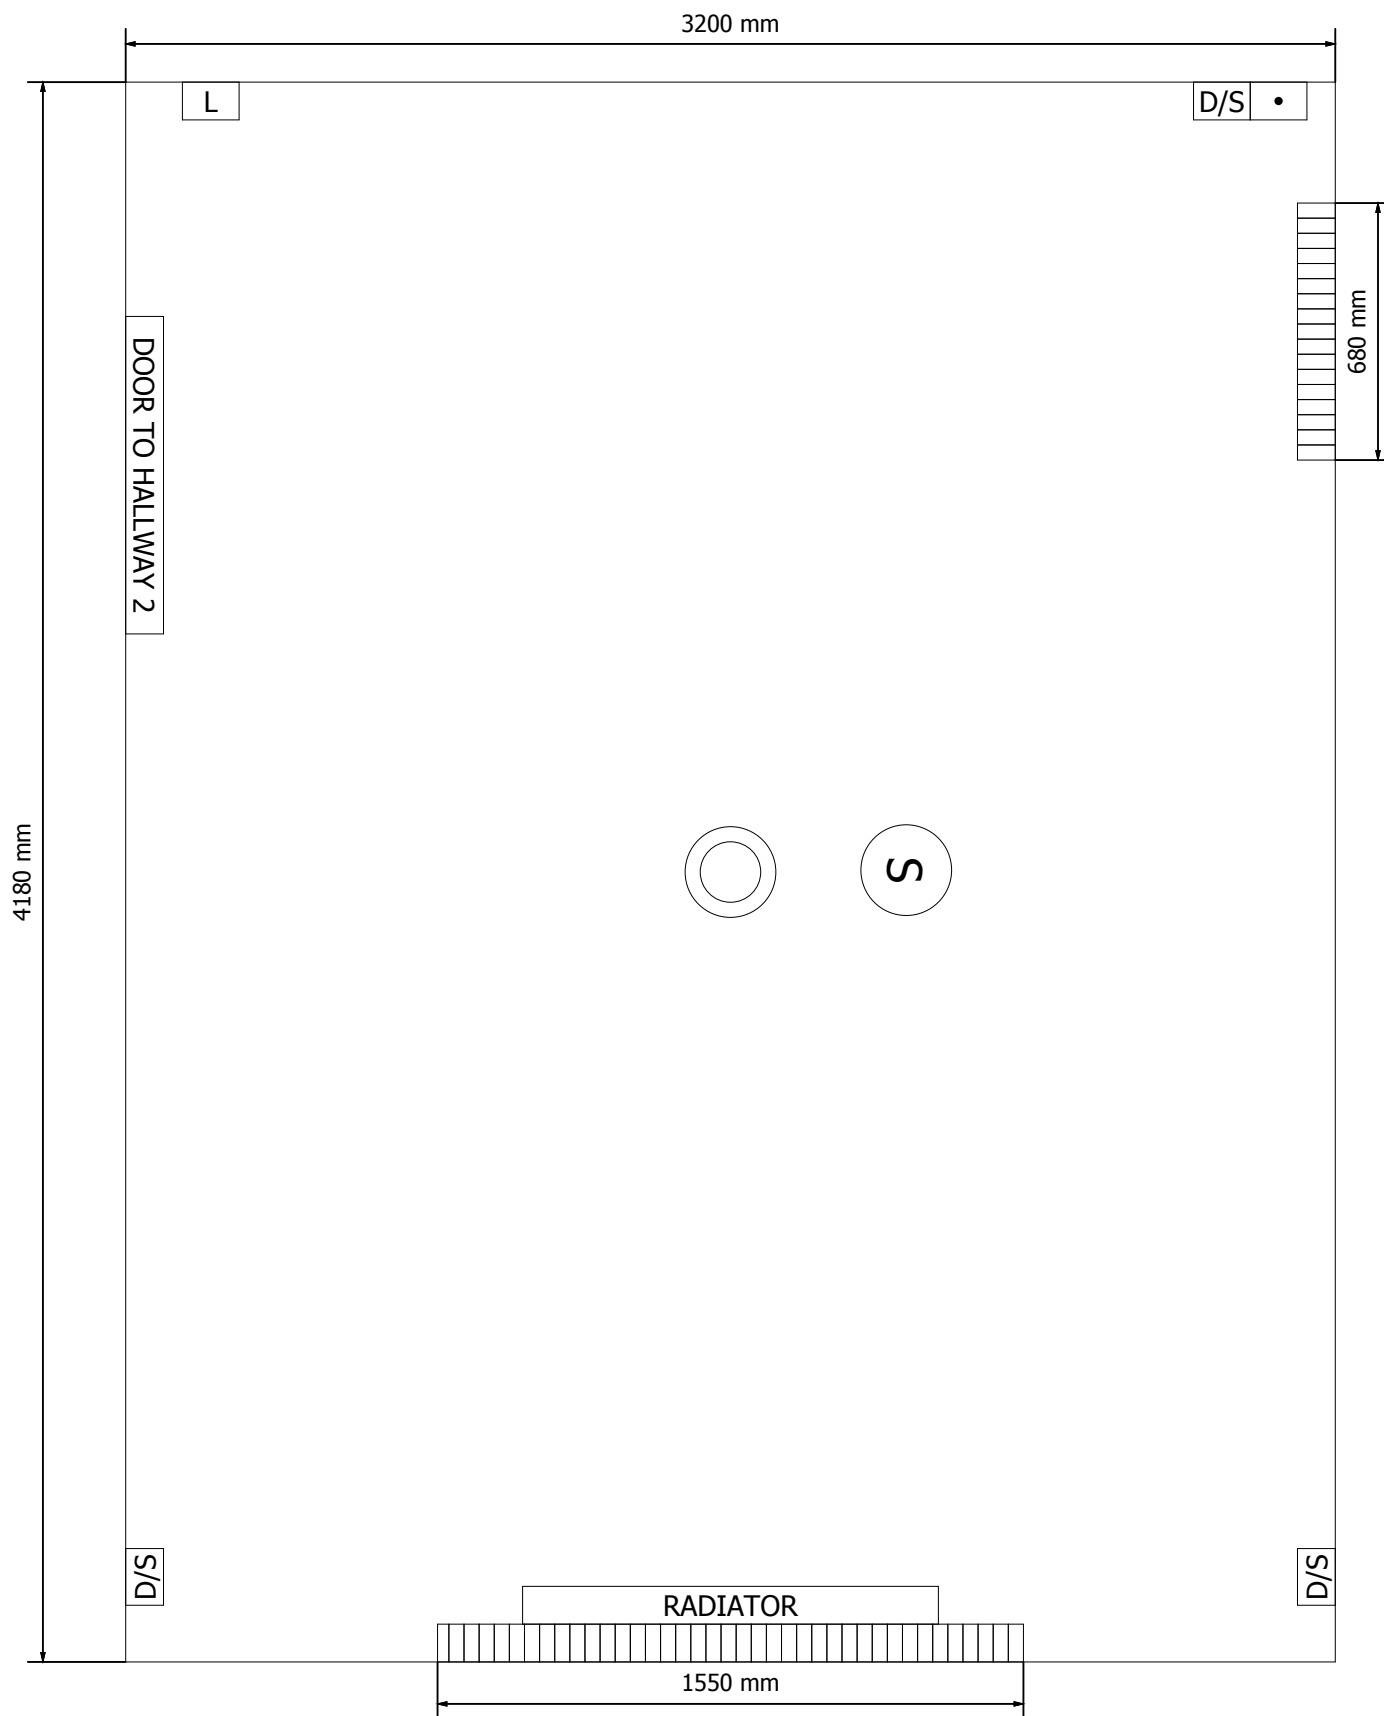


Revision	Date	Description	Drawn By	App By		ROOM 2			
R01	25/10/2021	Original Issue	JB	CT			N/A	=	
R02			JB	CT				+	
R03			JB	CT			31 Watery Road Plans	Page	11
								Page	17

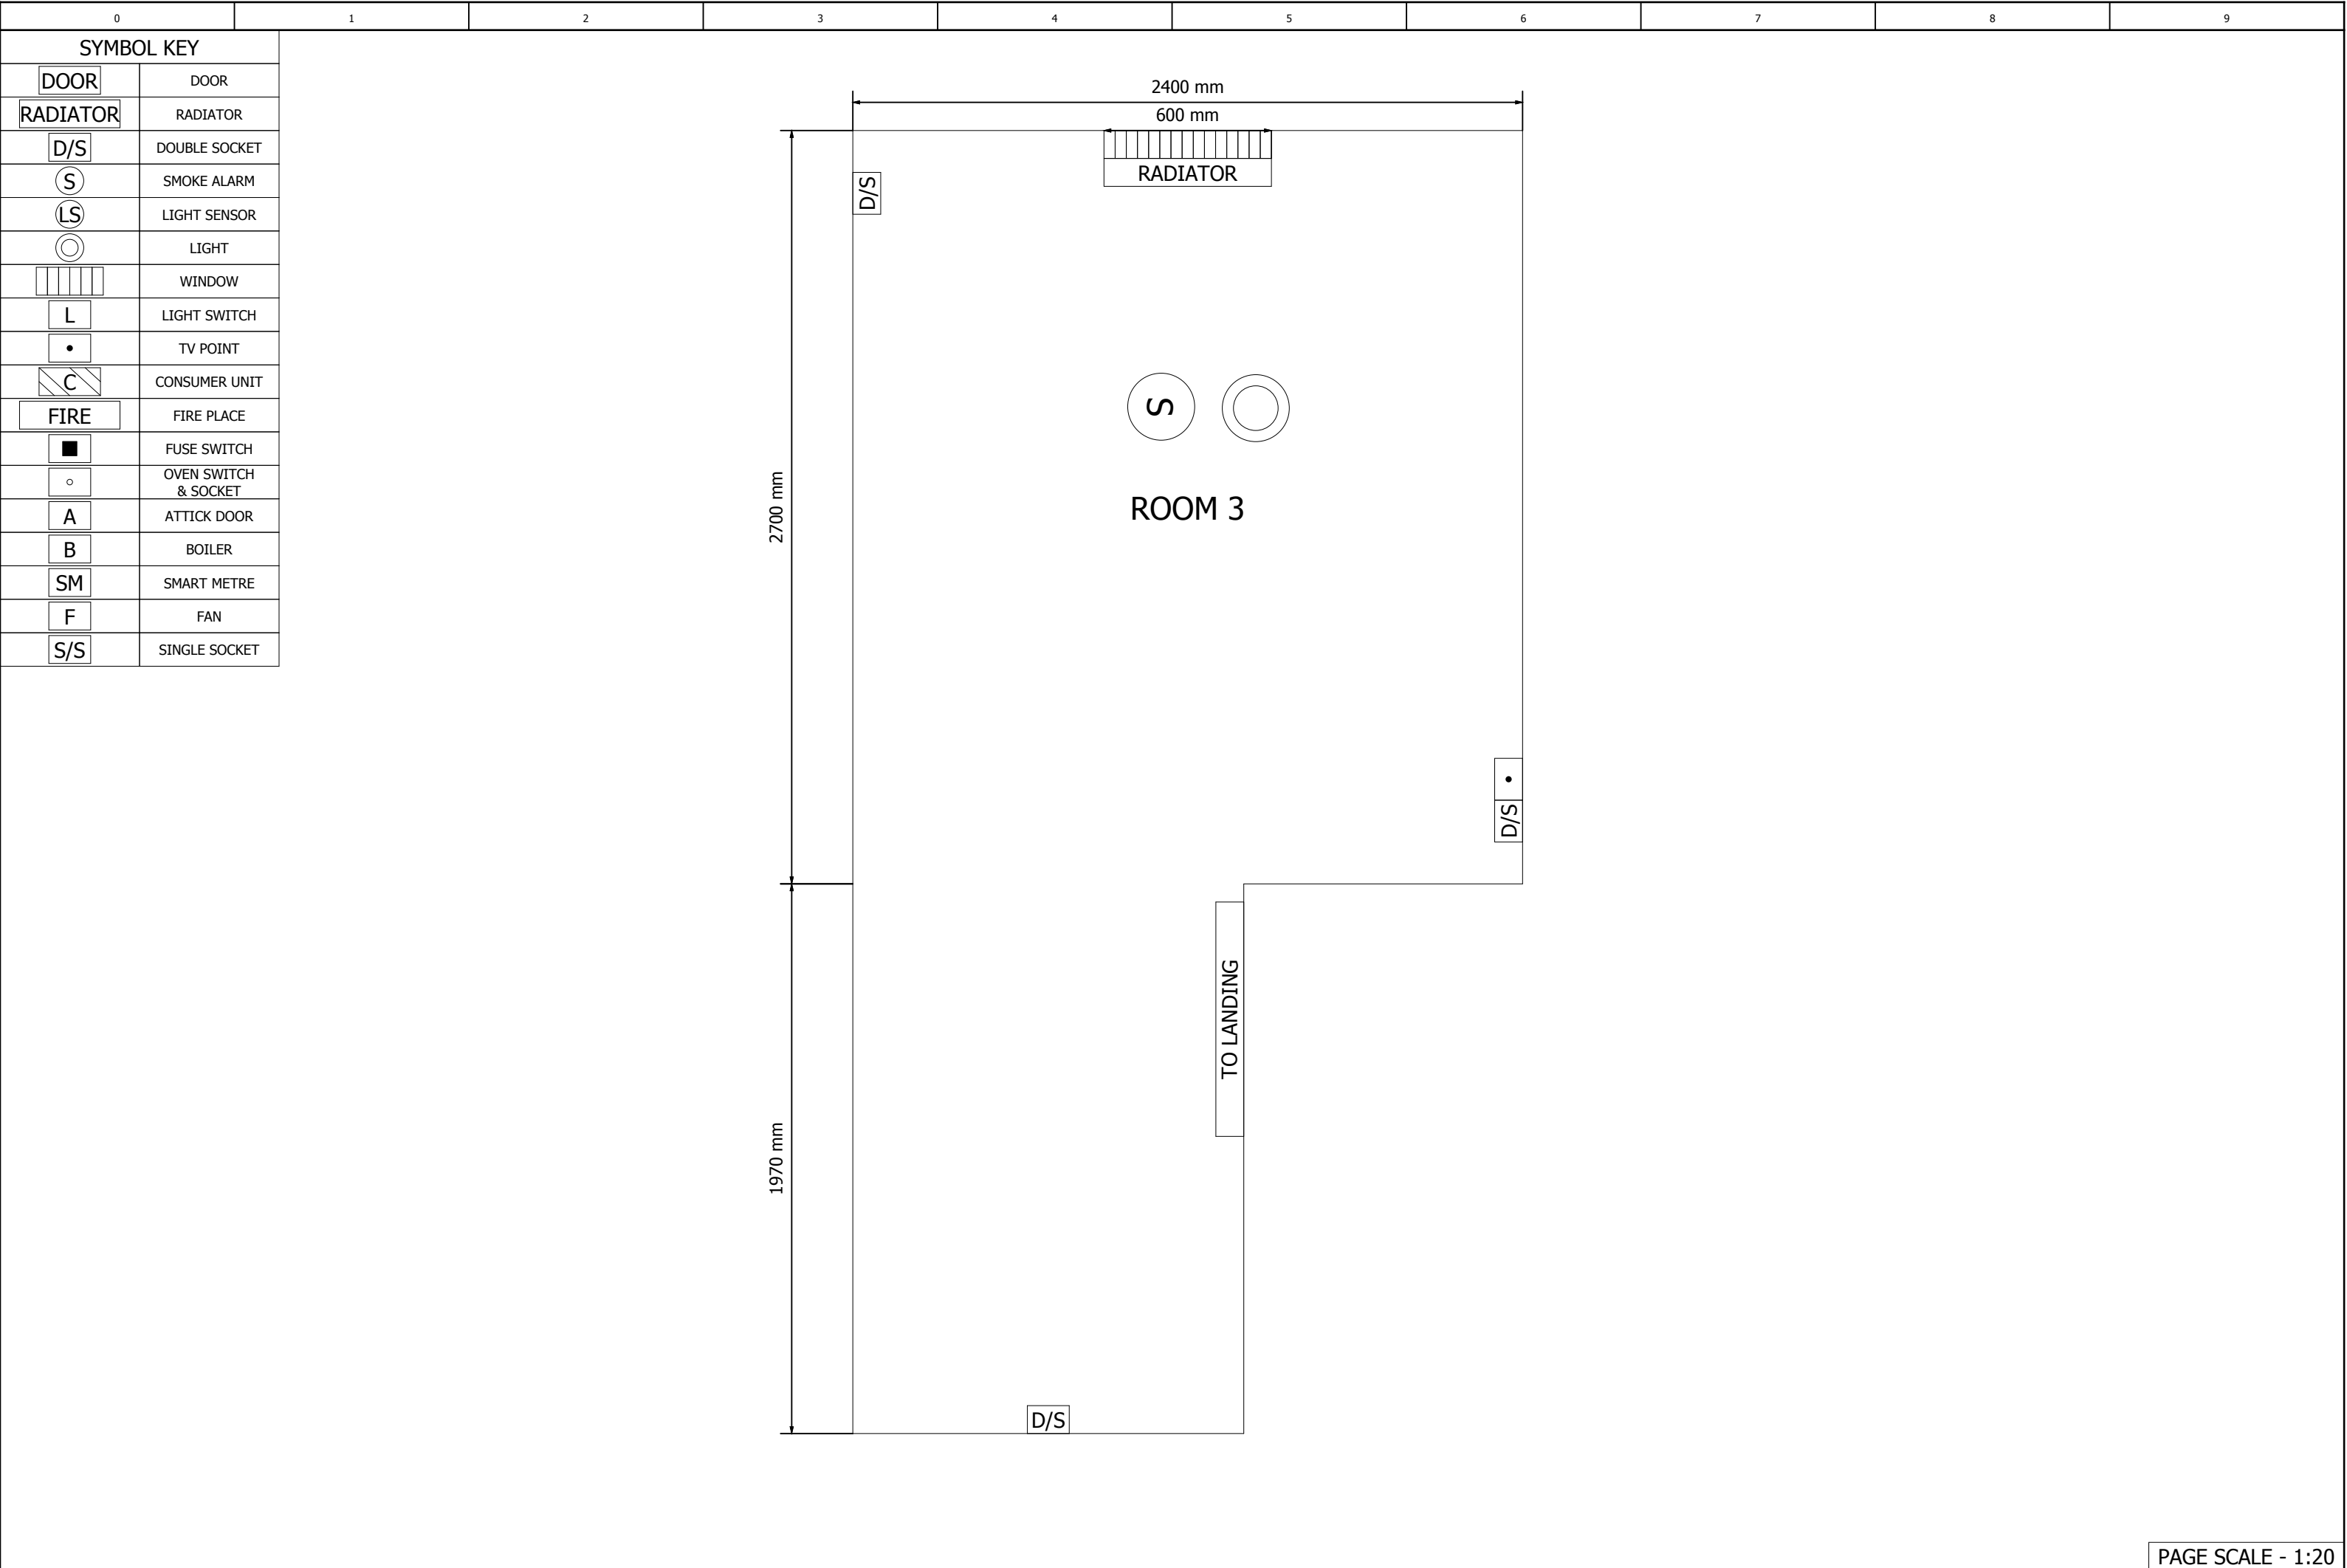


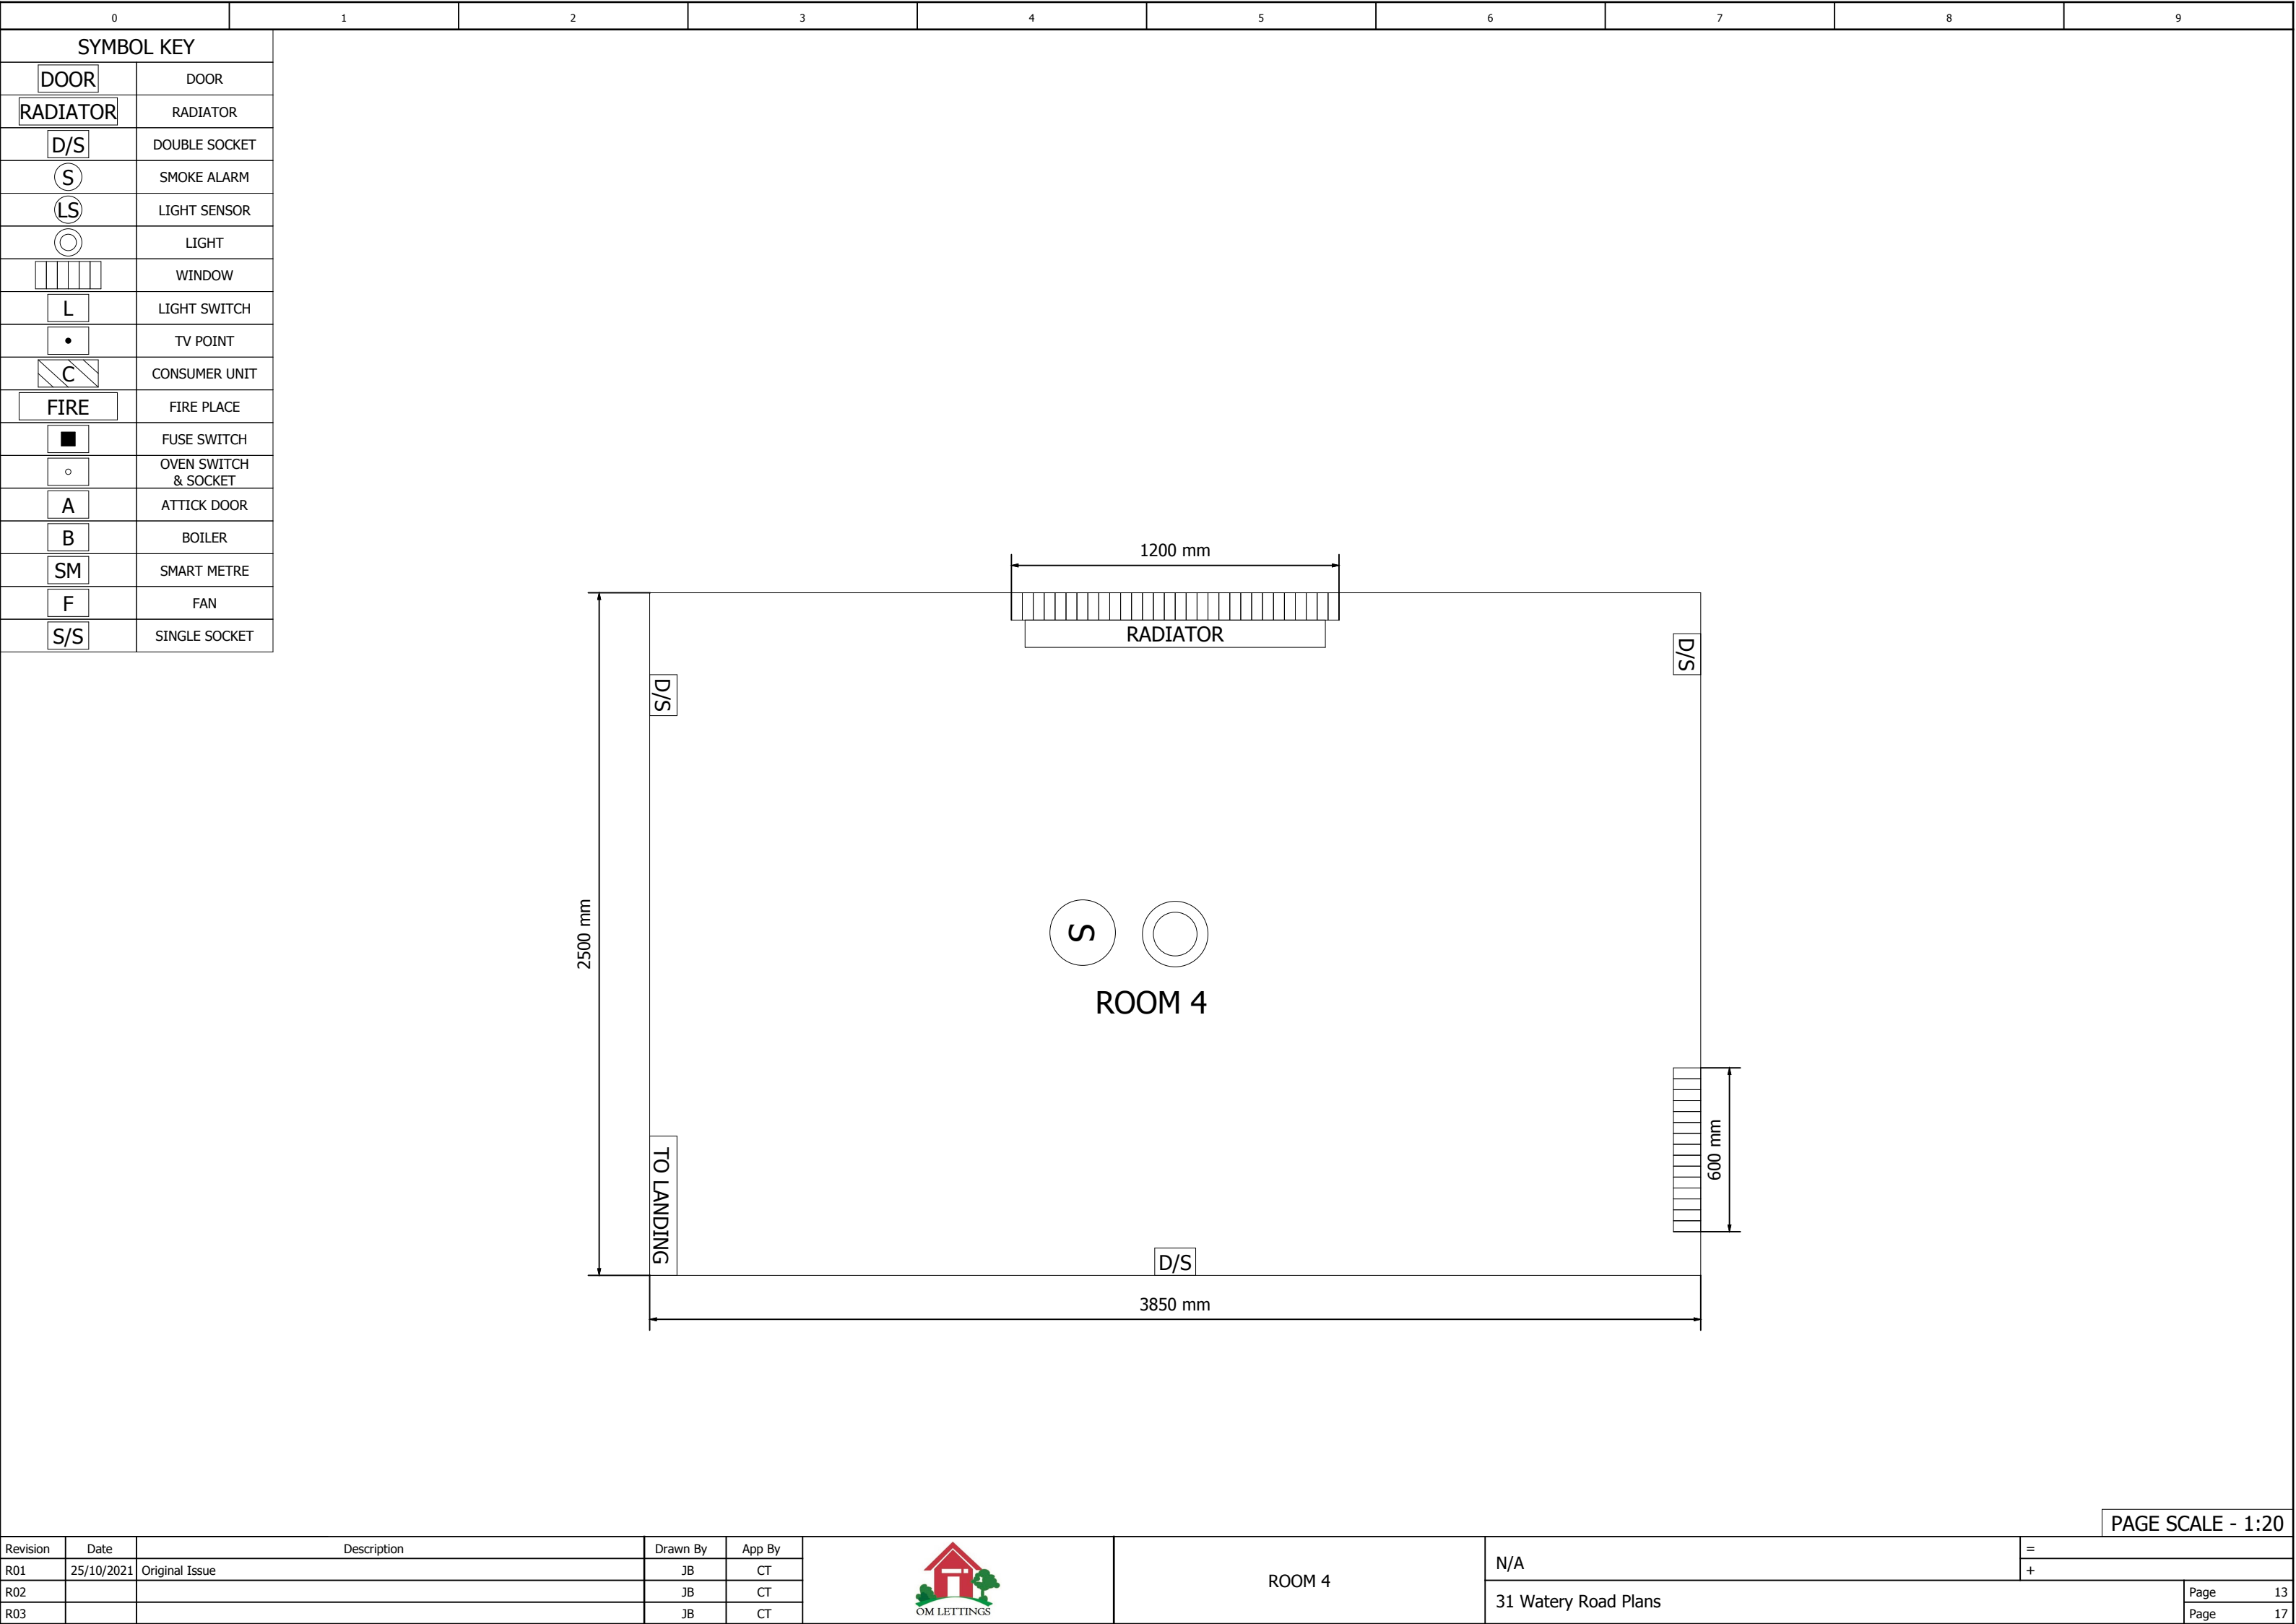

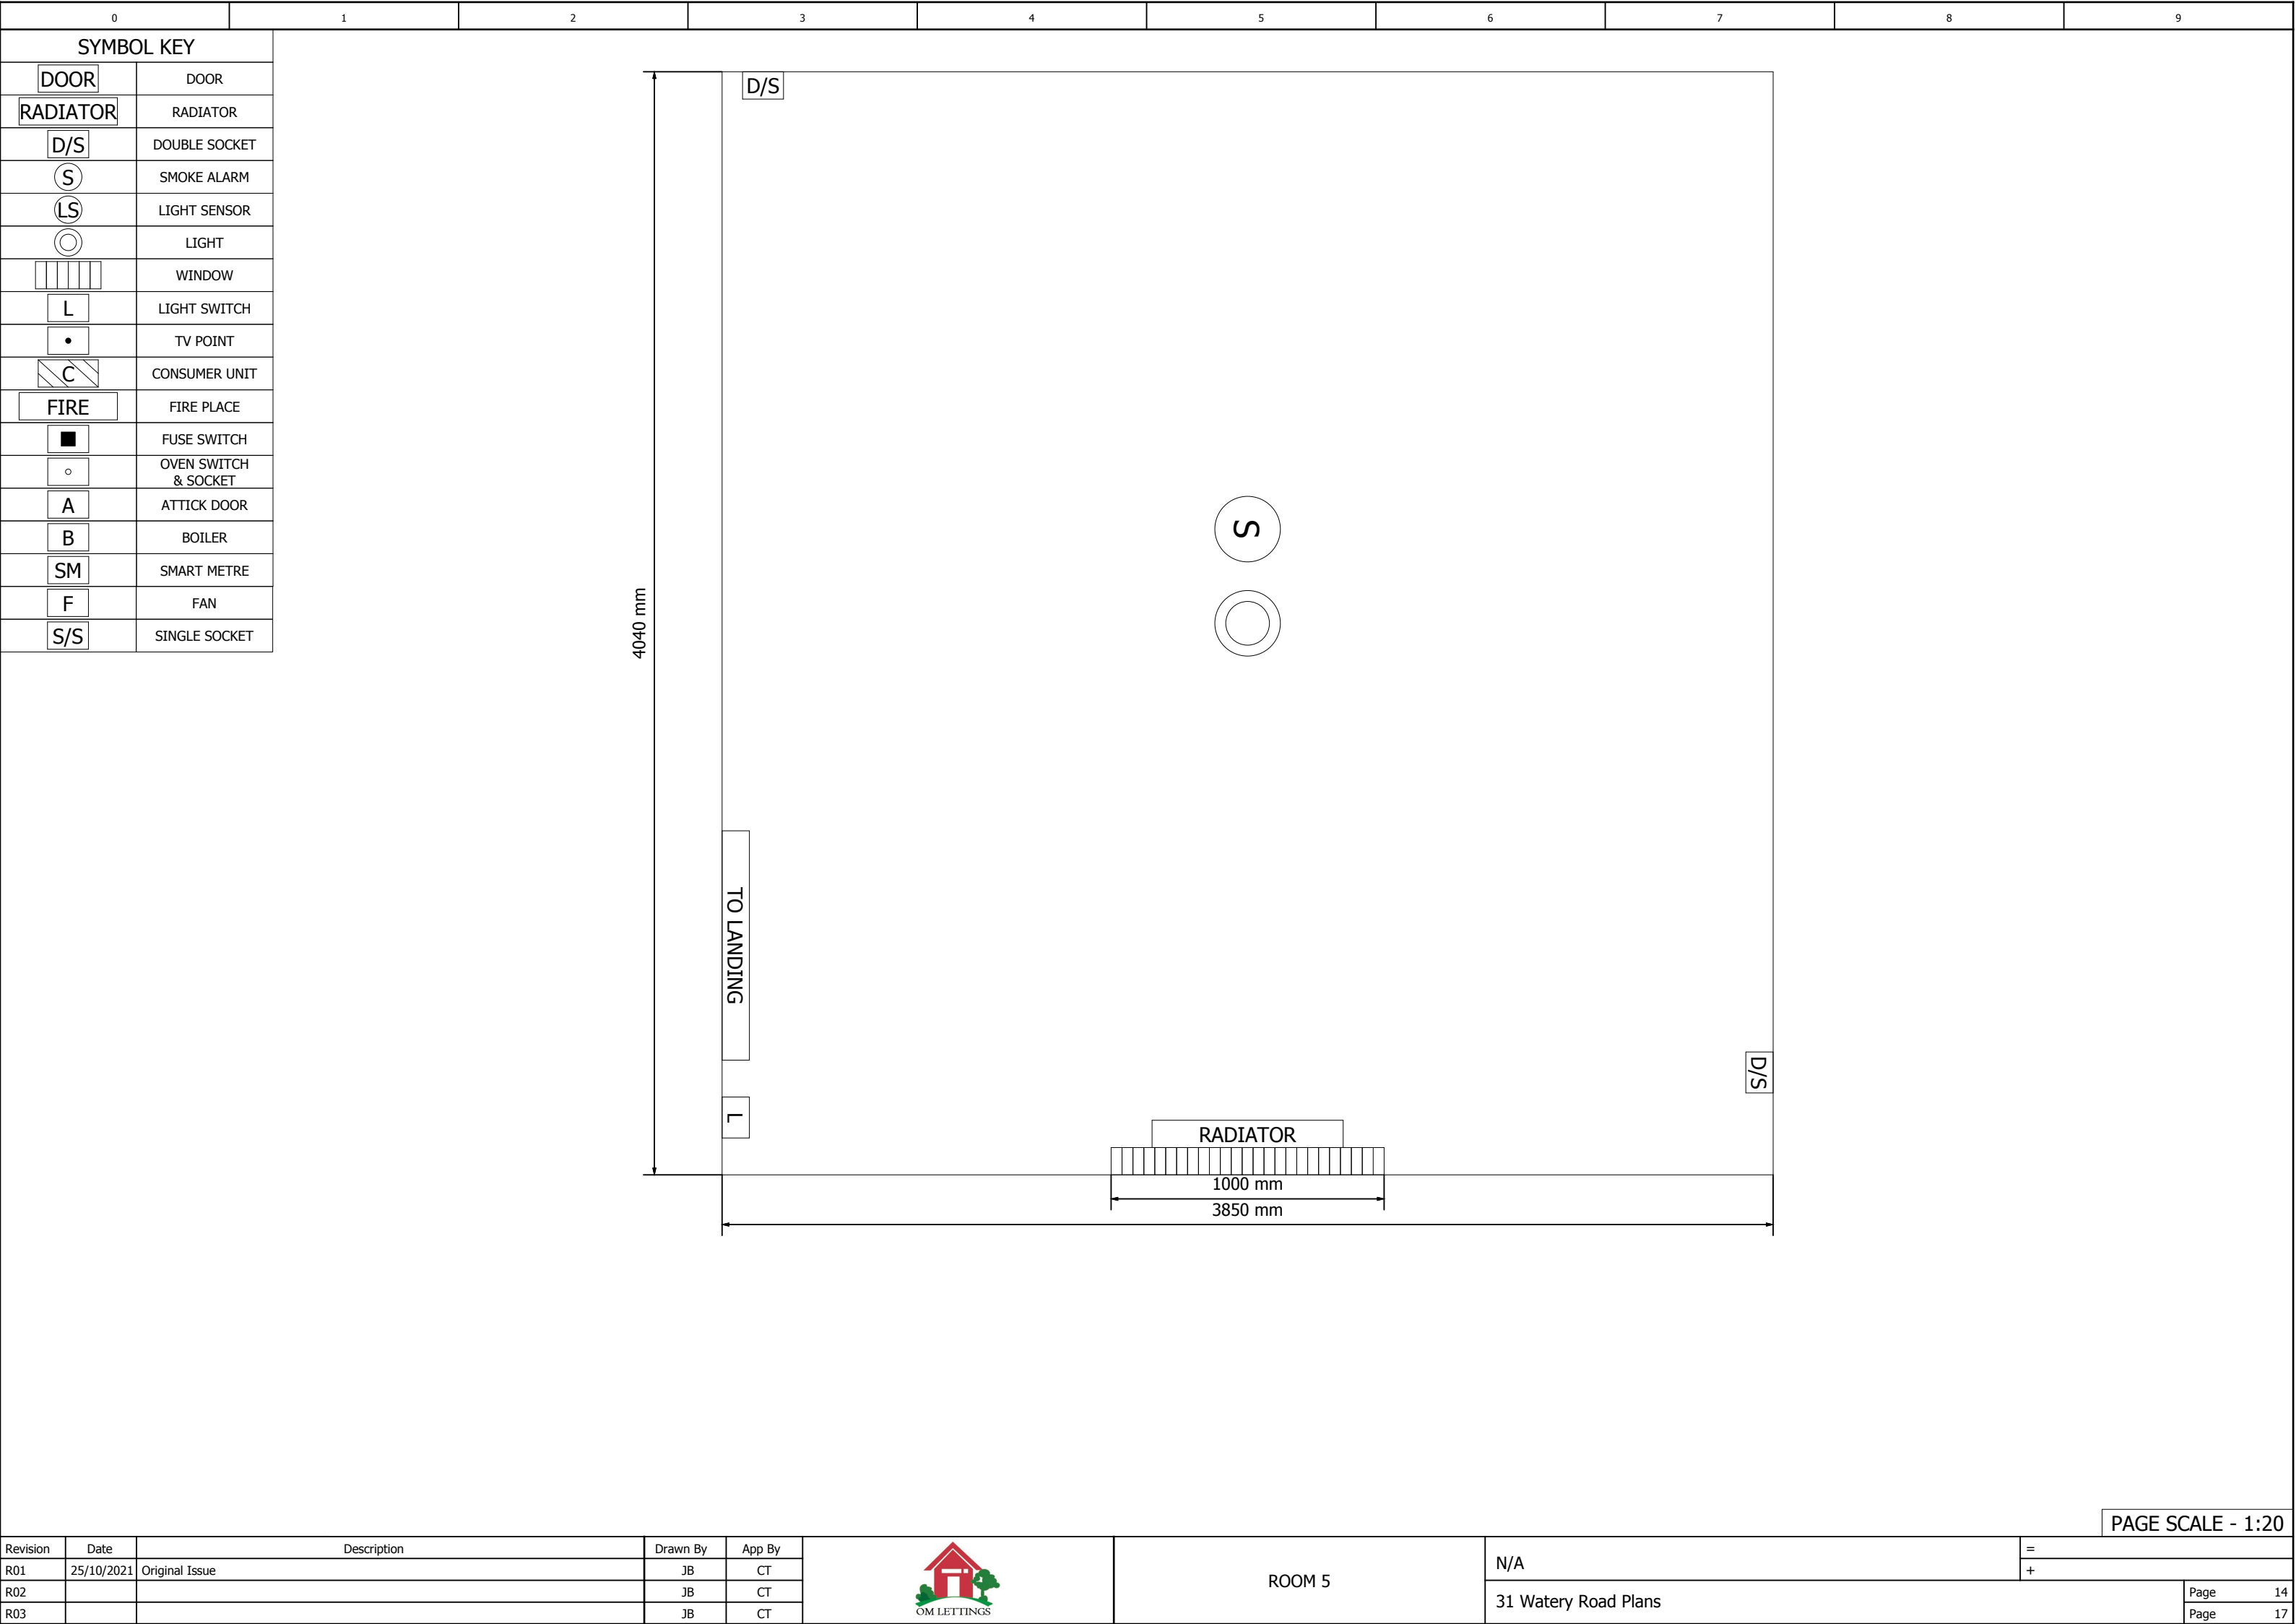

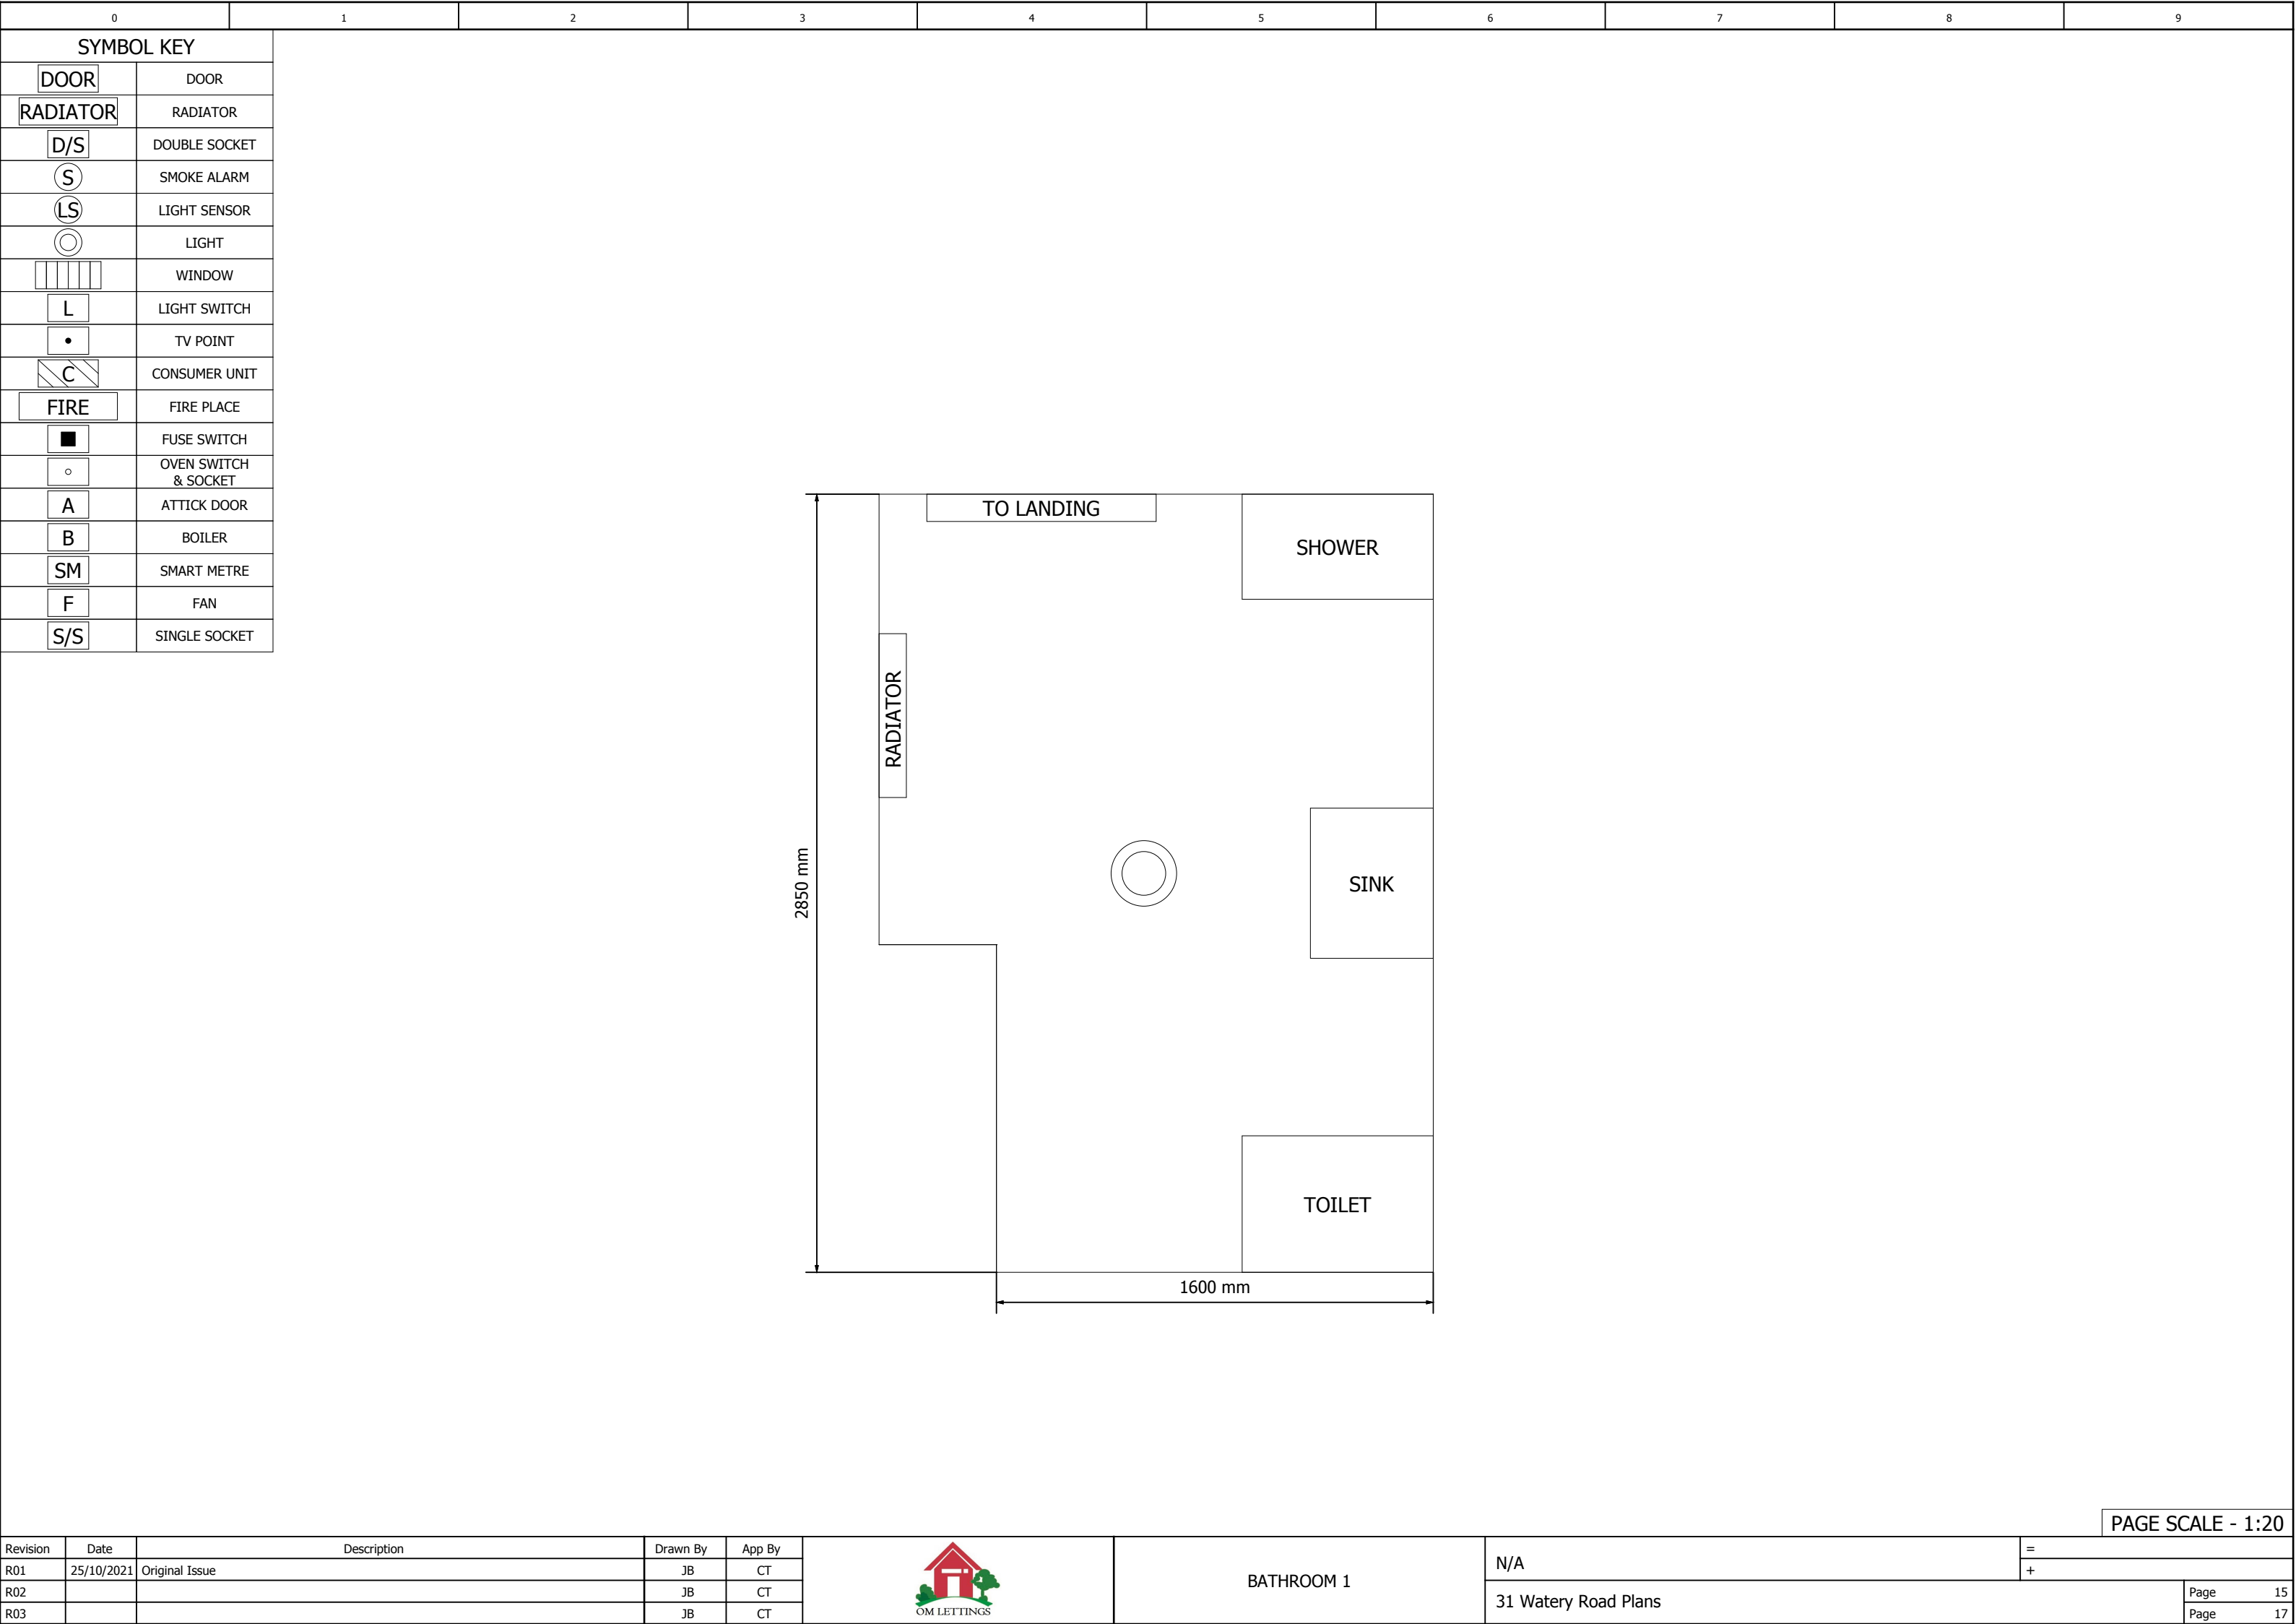

Revision	Date	Description	Drawn By	App By		BATHROOM 1	N/A	PAGE SCALE - 1:20		
R01	25/10/2021	Original Issue	JB	CT			31 Watery Road Plans	=		
R02			JB	CT				+		
R03			JB	CT					Page	15
								Page	17	

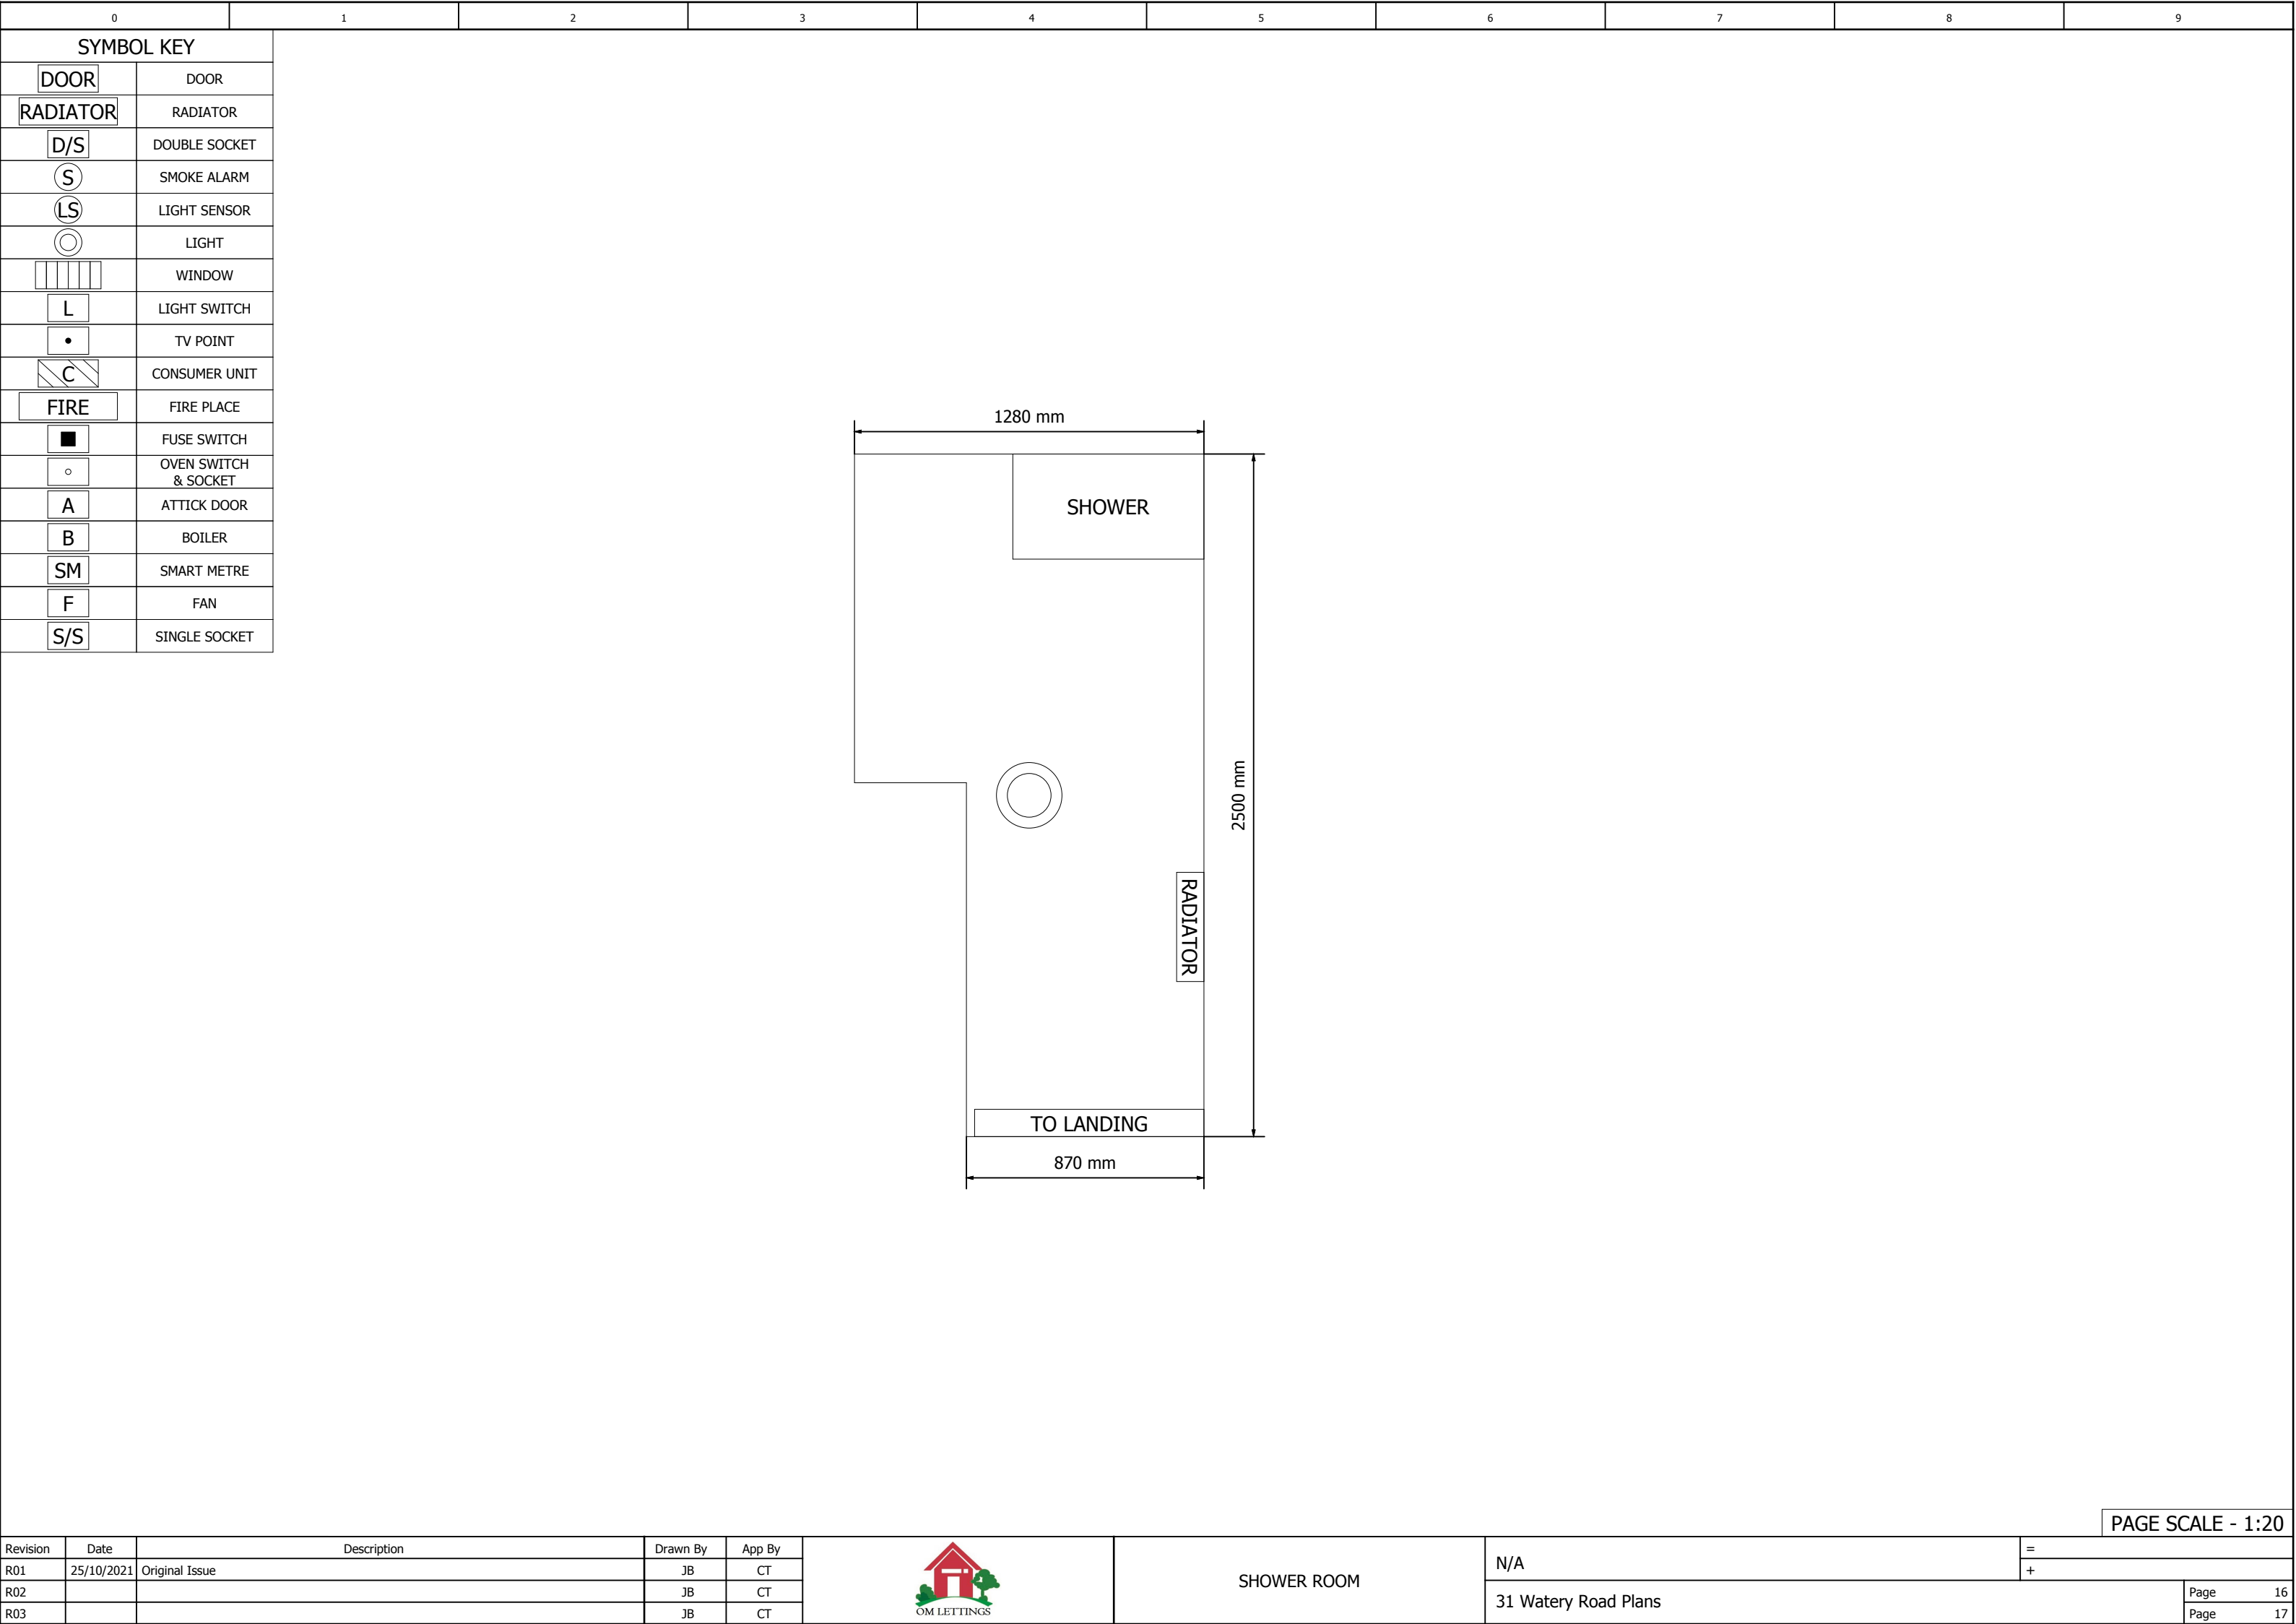

SYMBOL KEY	
DOOR	DOOR
RADIATOR	RADIATOR
D/S	DOUBLE SOCKET
S	SMOKE ALARM
LS	LIGHT SENSOR
○	LIGHT
	WINDOW
L	LIGHT SWITCH
•	TV POINT
C	CONSUMER UNIT
FIRE	FIRE PLACE
■	FUSE SWITCH
○	OVEN SWITCH & SOCKET
A	ATTICK DOOR
B	BOILER
SM	SMART METRE
F	FAN
S/S	SINGLE SOCKET

