


FOUL

DO NOT SCALE FROM DRAWING

NOTES:-

- 1 ALL MEASUREMENTS ARE IN METRES UNLESS INDICATED OTHERWISE.
- 2 DRAINAGE TO BE CONSTRUCTED IN ACCORDANCE WITH SEWERS FOR ADOPTION 6TH EDITION.
- 3 FOR CONSTRUCTION DETAILS REFER STANDARD DETAILS DRAWINGS.
- 4 FOR LEVEL INFORMATION REFER TO DRAINAGE SECTIONS.

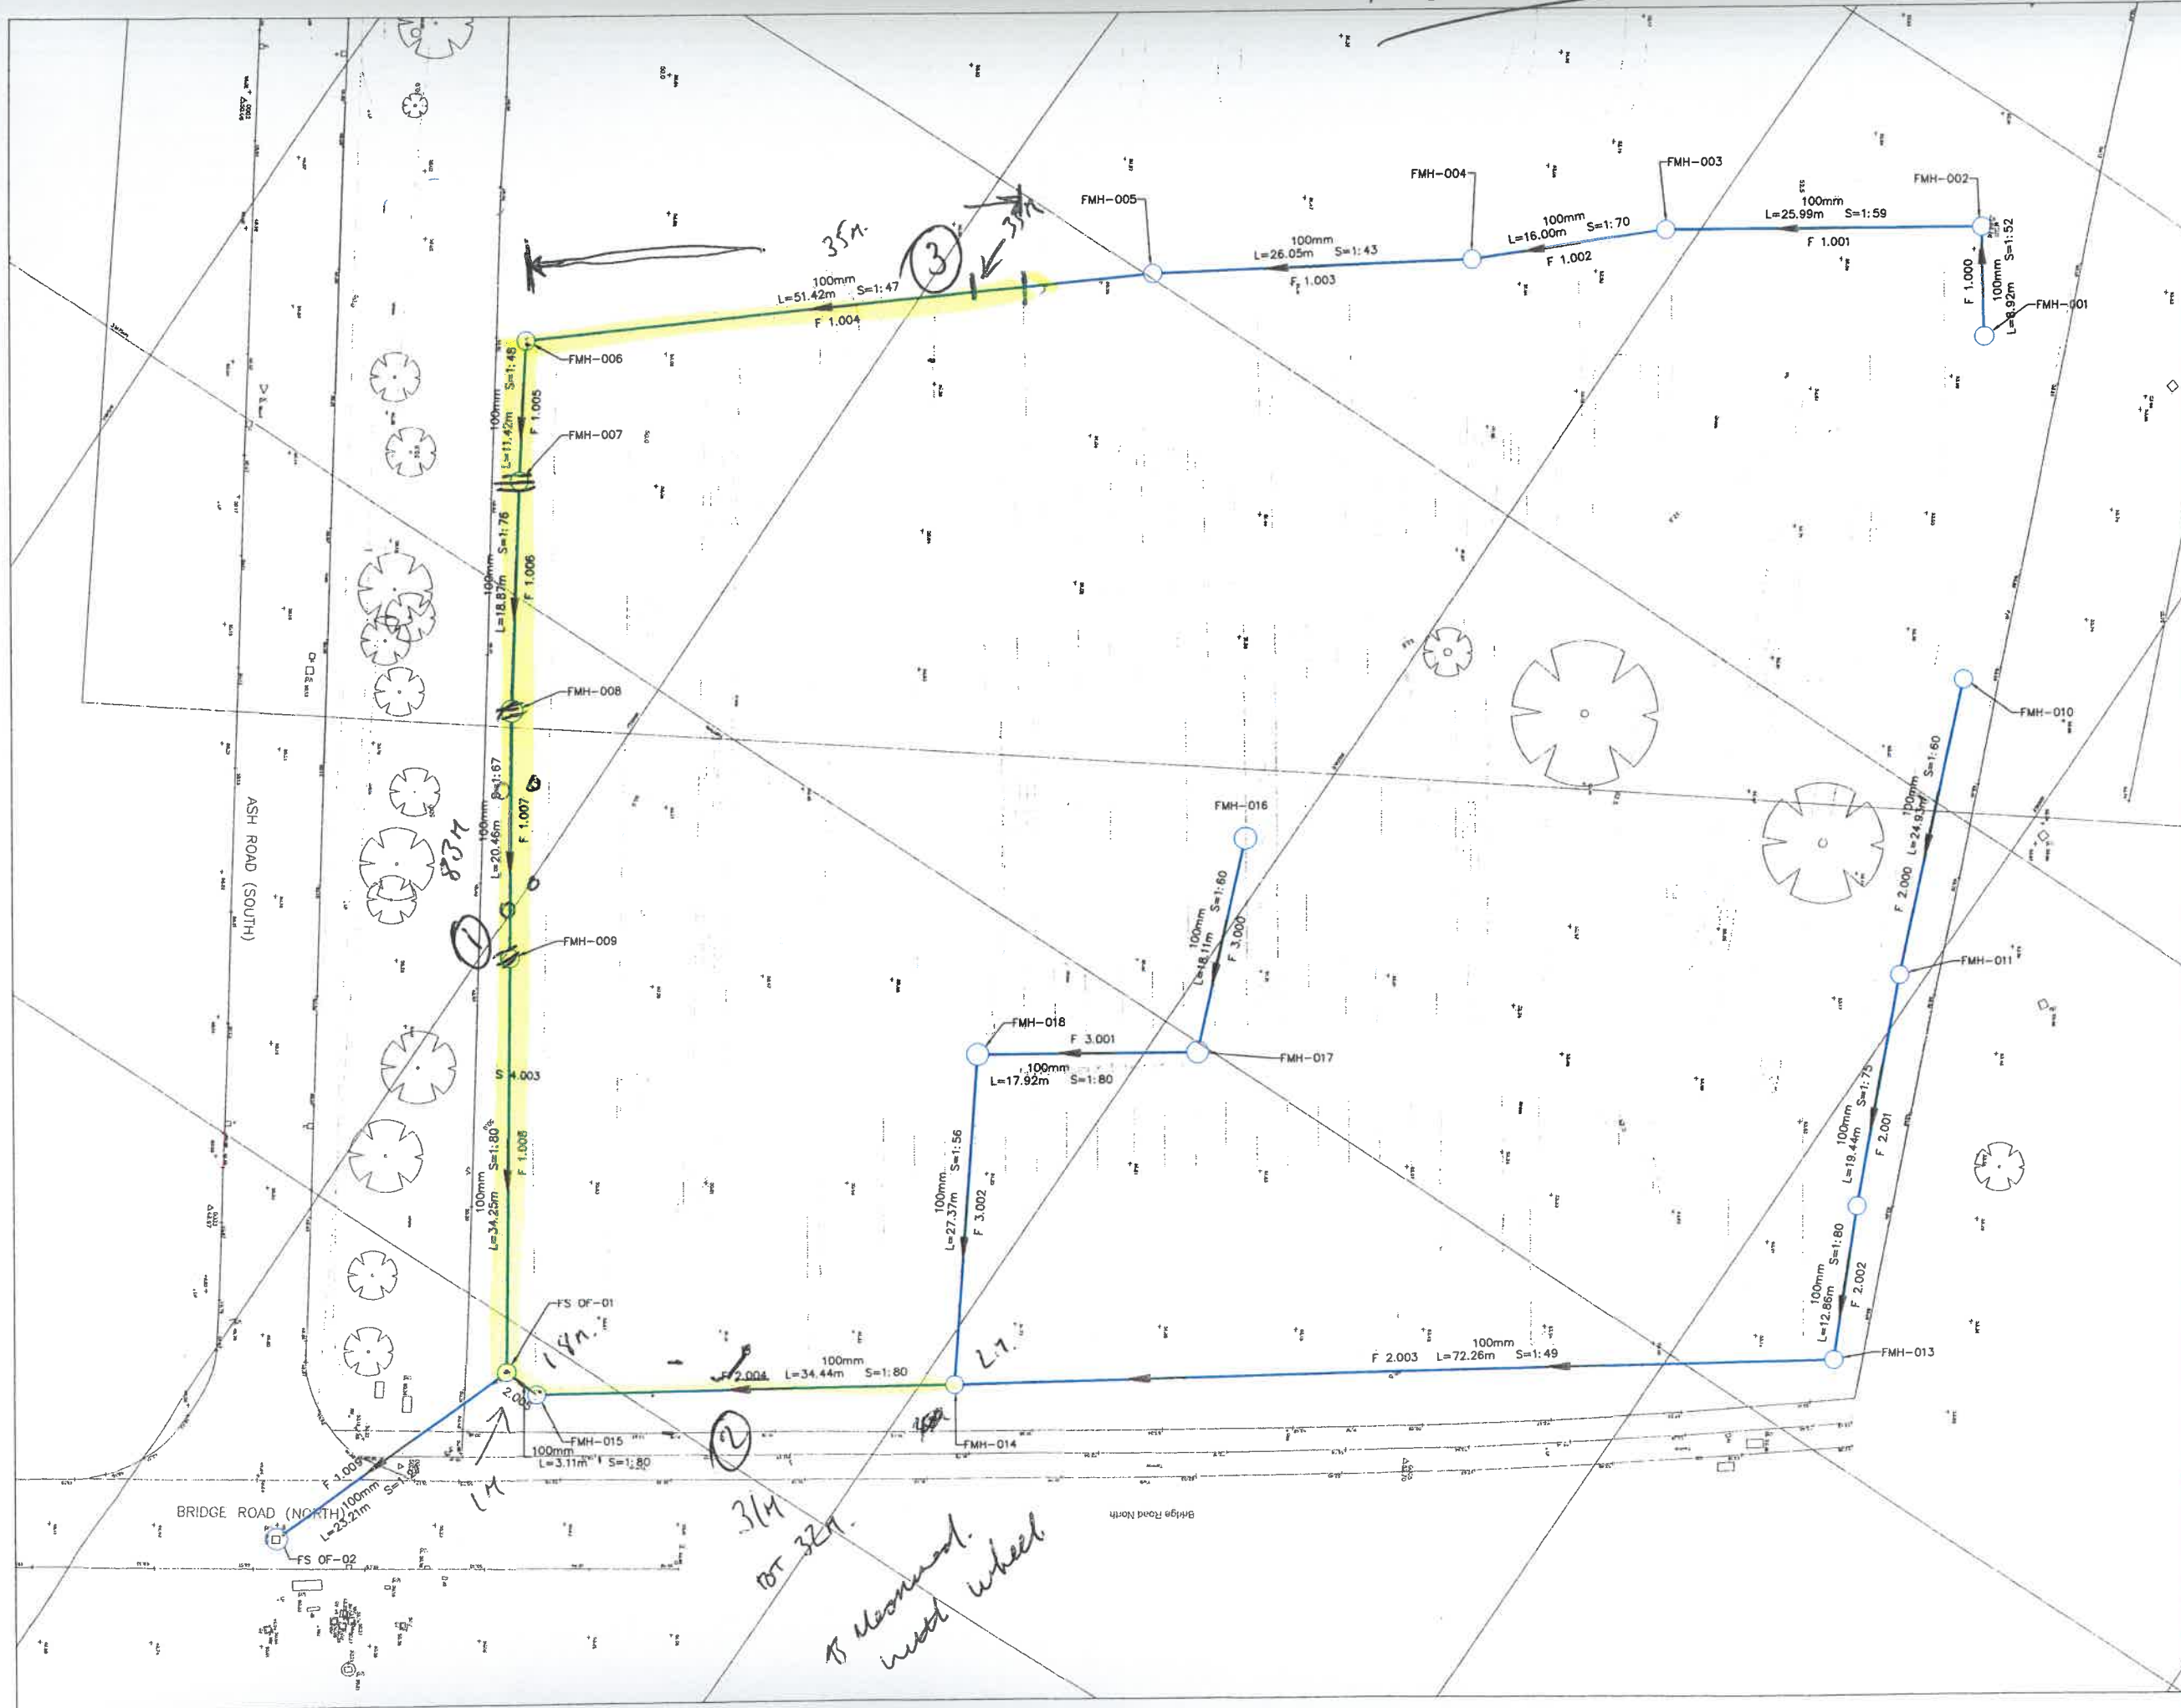

Rev	Date	Drawn	Checkd	Appr	Descr
P4	14/08	PMA	KB		Units 5 & 6 Repaired.
P3	14/12	KB			REV B

ERLAS DEVELOPMENTS

The BRIDGE BUSINESS CENTER

PROPOSED DRAINAGE
FOUL DRAINAGE
DRAINAGE LAYOUT

REDES
INFRASTRUCTURE DESIGN

APPROVAL

Remote Engineering Design Services Ltd.
3 Blackwood Business Park,
Ash Road South, Wrexham, LL13 9UG
Tel. 01978 66 99 36 Fax. 0870 762 50 51
Email. admin@redes.co.uk
Web. www.redes.co.uk

Scale	1:250 @ A1	Date	12-11-07
Drawn	MB	Checked	KB
Project no.	ERL_001	Drawing no.	DR_003
Issue			P4