

- LONDON
- LEEDS
- CARDIFF
- GLASGOW
- ABERYSTWYTH
- NEWTOWN
- MANCHESTER
- LOUGHBOROUGH

1 no. new AC unit to be situated in external yard area on new level concrete base. See CGR drawing HOL/12257/CR3 for details.


Proposed new 2.3m high chiller and freezer units formed in cold room panels to rear service to replace existing removed shed store and container.

1 no. new Condenser to be situated in external yard area on new level concrete base. See CGR drawing HOL/12257/CR3 for details.

1 no. new timber frame canopy with polycarbonate roof to be installed from warehouse to chiller and freezer areas.

1 no. new AC unit to be situated in external yard area on new level concrete base. See CGR drawing HOL/12257/CR3 for details.

1 no. new Compressor to be situated in external yard area on new level concrete base. See CGR drawing HOL/12257/CR3 for details.

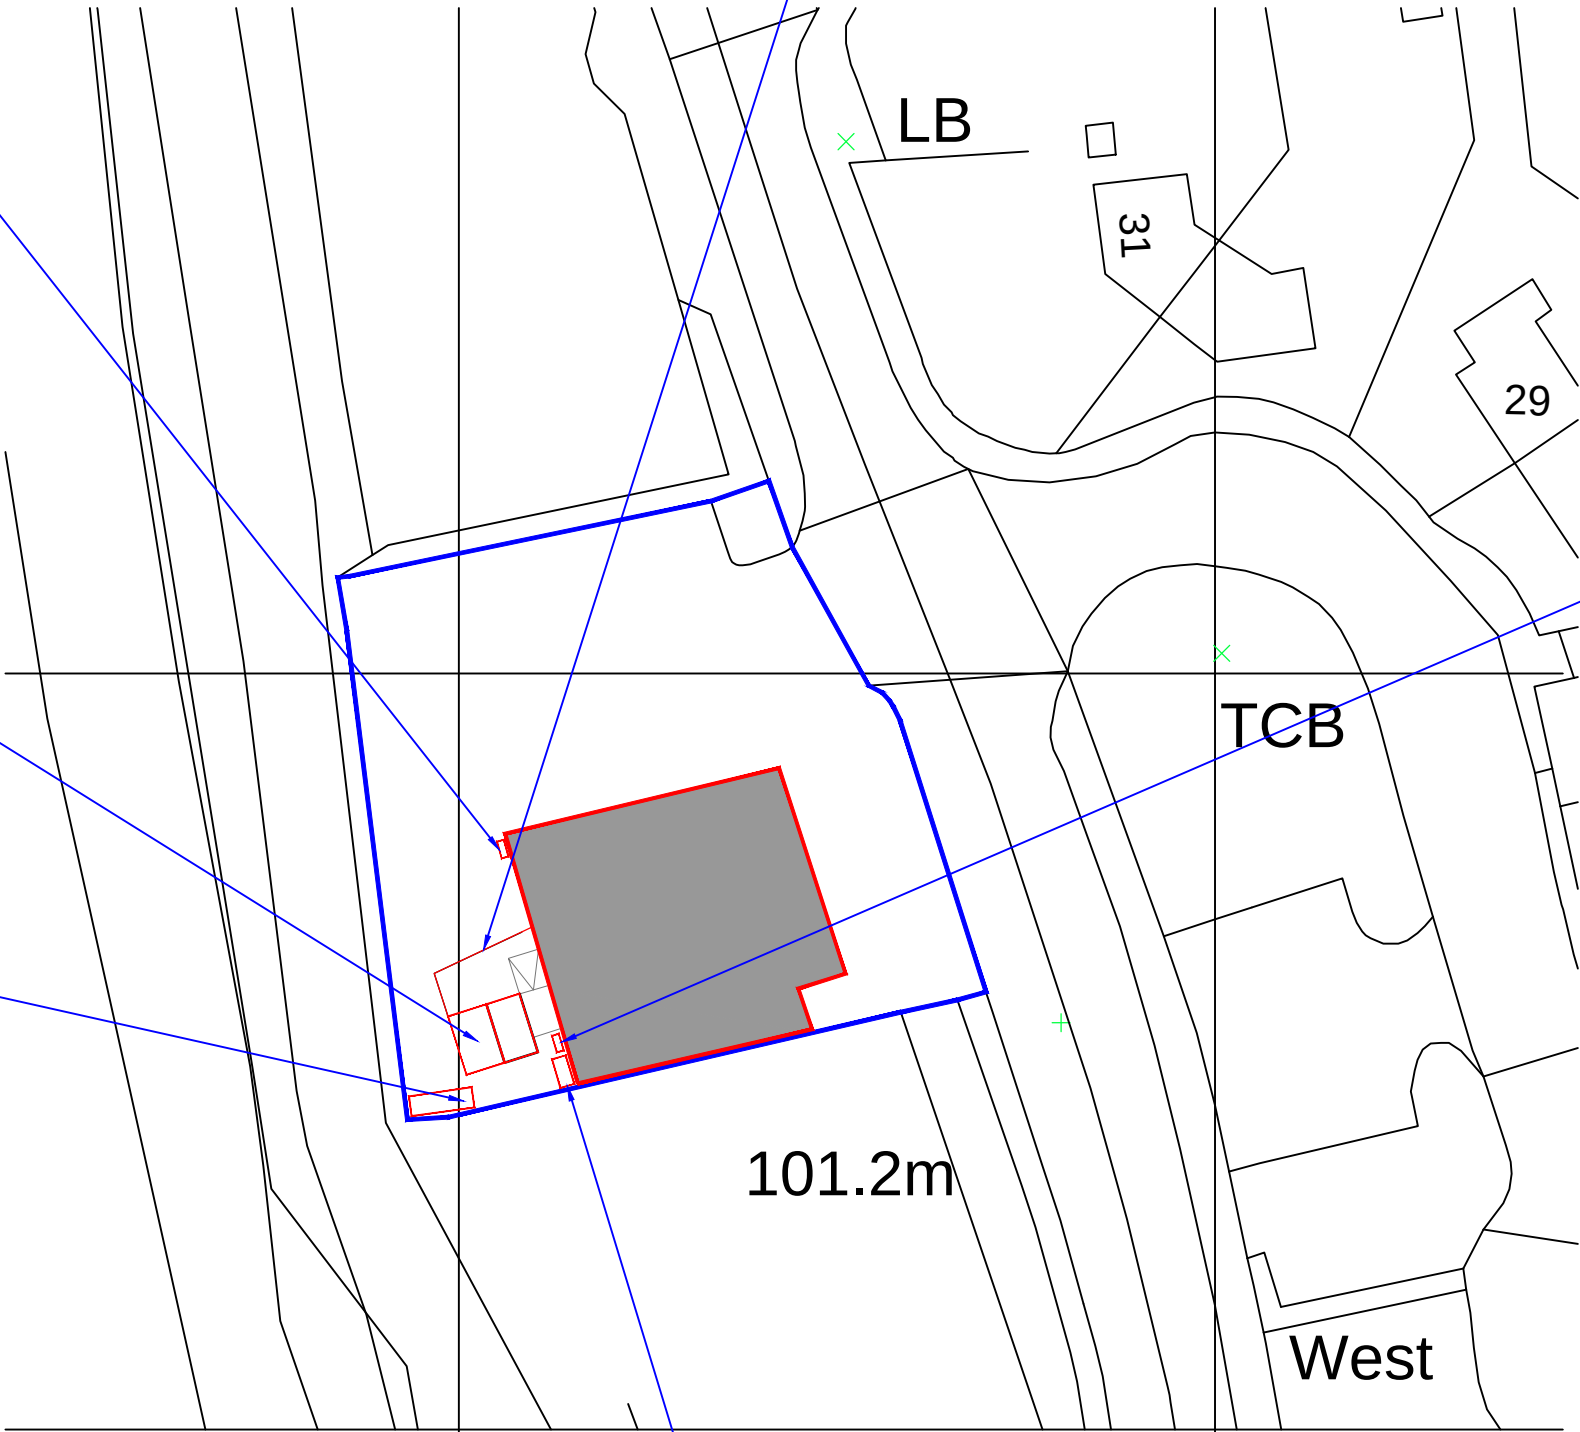

Ordnance Survey (c) Crown Copyright 2018. All rights reserved. Licence number 100022432

1 PROPOSED SITE PLAN
1:500

REV	DATE	DESCRIPTION	DR	CH
-----	------	-------------	----	----

PLANNING ISSUE

darnton_{B3}
ARCHITECTURE

LEEDS
The Coach House, Monk Fryston Hall, Monk Fryston, Leeds, LS25 5DU.
T: 01977 681 001 www.darntonb3.com

CLIENT		
TCG		
-		
PROJECT		
Co operative Group		
Chirk		
DRAWING		
Proposed Site Plan		
-		
SCALE @ A3	DRAWN	CHECKED
1:500	SN	-
CREATION DATE		REVISION
04.06.18		-
DARNTONB3 DRAWING NO.		
12635 DB3 - - - - - A 90001		
PROJECT NO-COMPANY- ZONE - LEVEL - TYPE - ROLE -NUMBER		
© COPYRIGHT: ALL RIGHTS RESERVED.		
THIS DRAWING IS TO BE READ IN CONJUNCTION WITH ALL OTHER RELEVANT DRAWINGS PREPARED BY CONSULTANTS AND SUB-CONTRACTORS.		
DO NOT SCALE FROM THIS DRAWING. WORK ONLY TO THE PRINTED DIMENSIONS.		
THIS DRAWING MUST NOT BE USED FOR CONSTRUCTION UNLESS ISSUED FOR CONSTRUCTION.		
REPORT ANY DISCREPANCIES TO THE ARCHITECT OR REPRESENTATIVES THEREOF.		
DARNTONEGS LTD WORK TO A MANAGEMENT SYSTEM WHICH IS APPROVED TO ISO-9001 BY LRQA – CERTIFICATE NUMBER LRQA-0947182		