


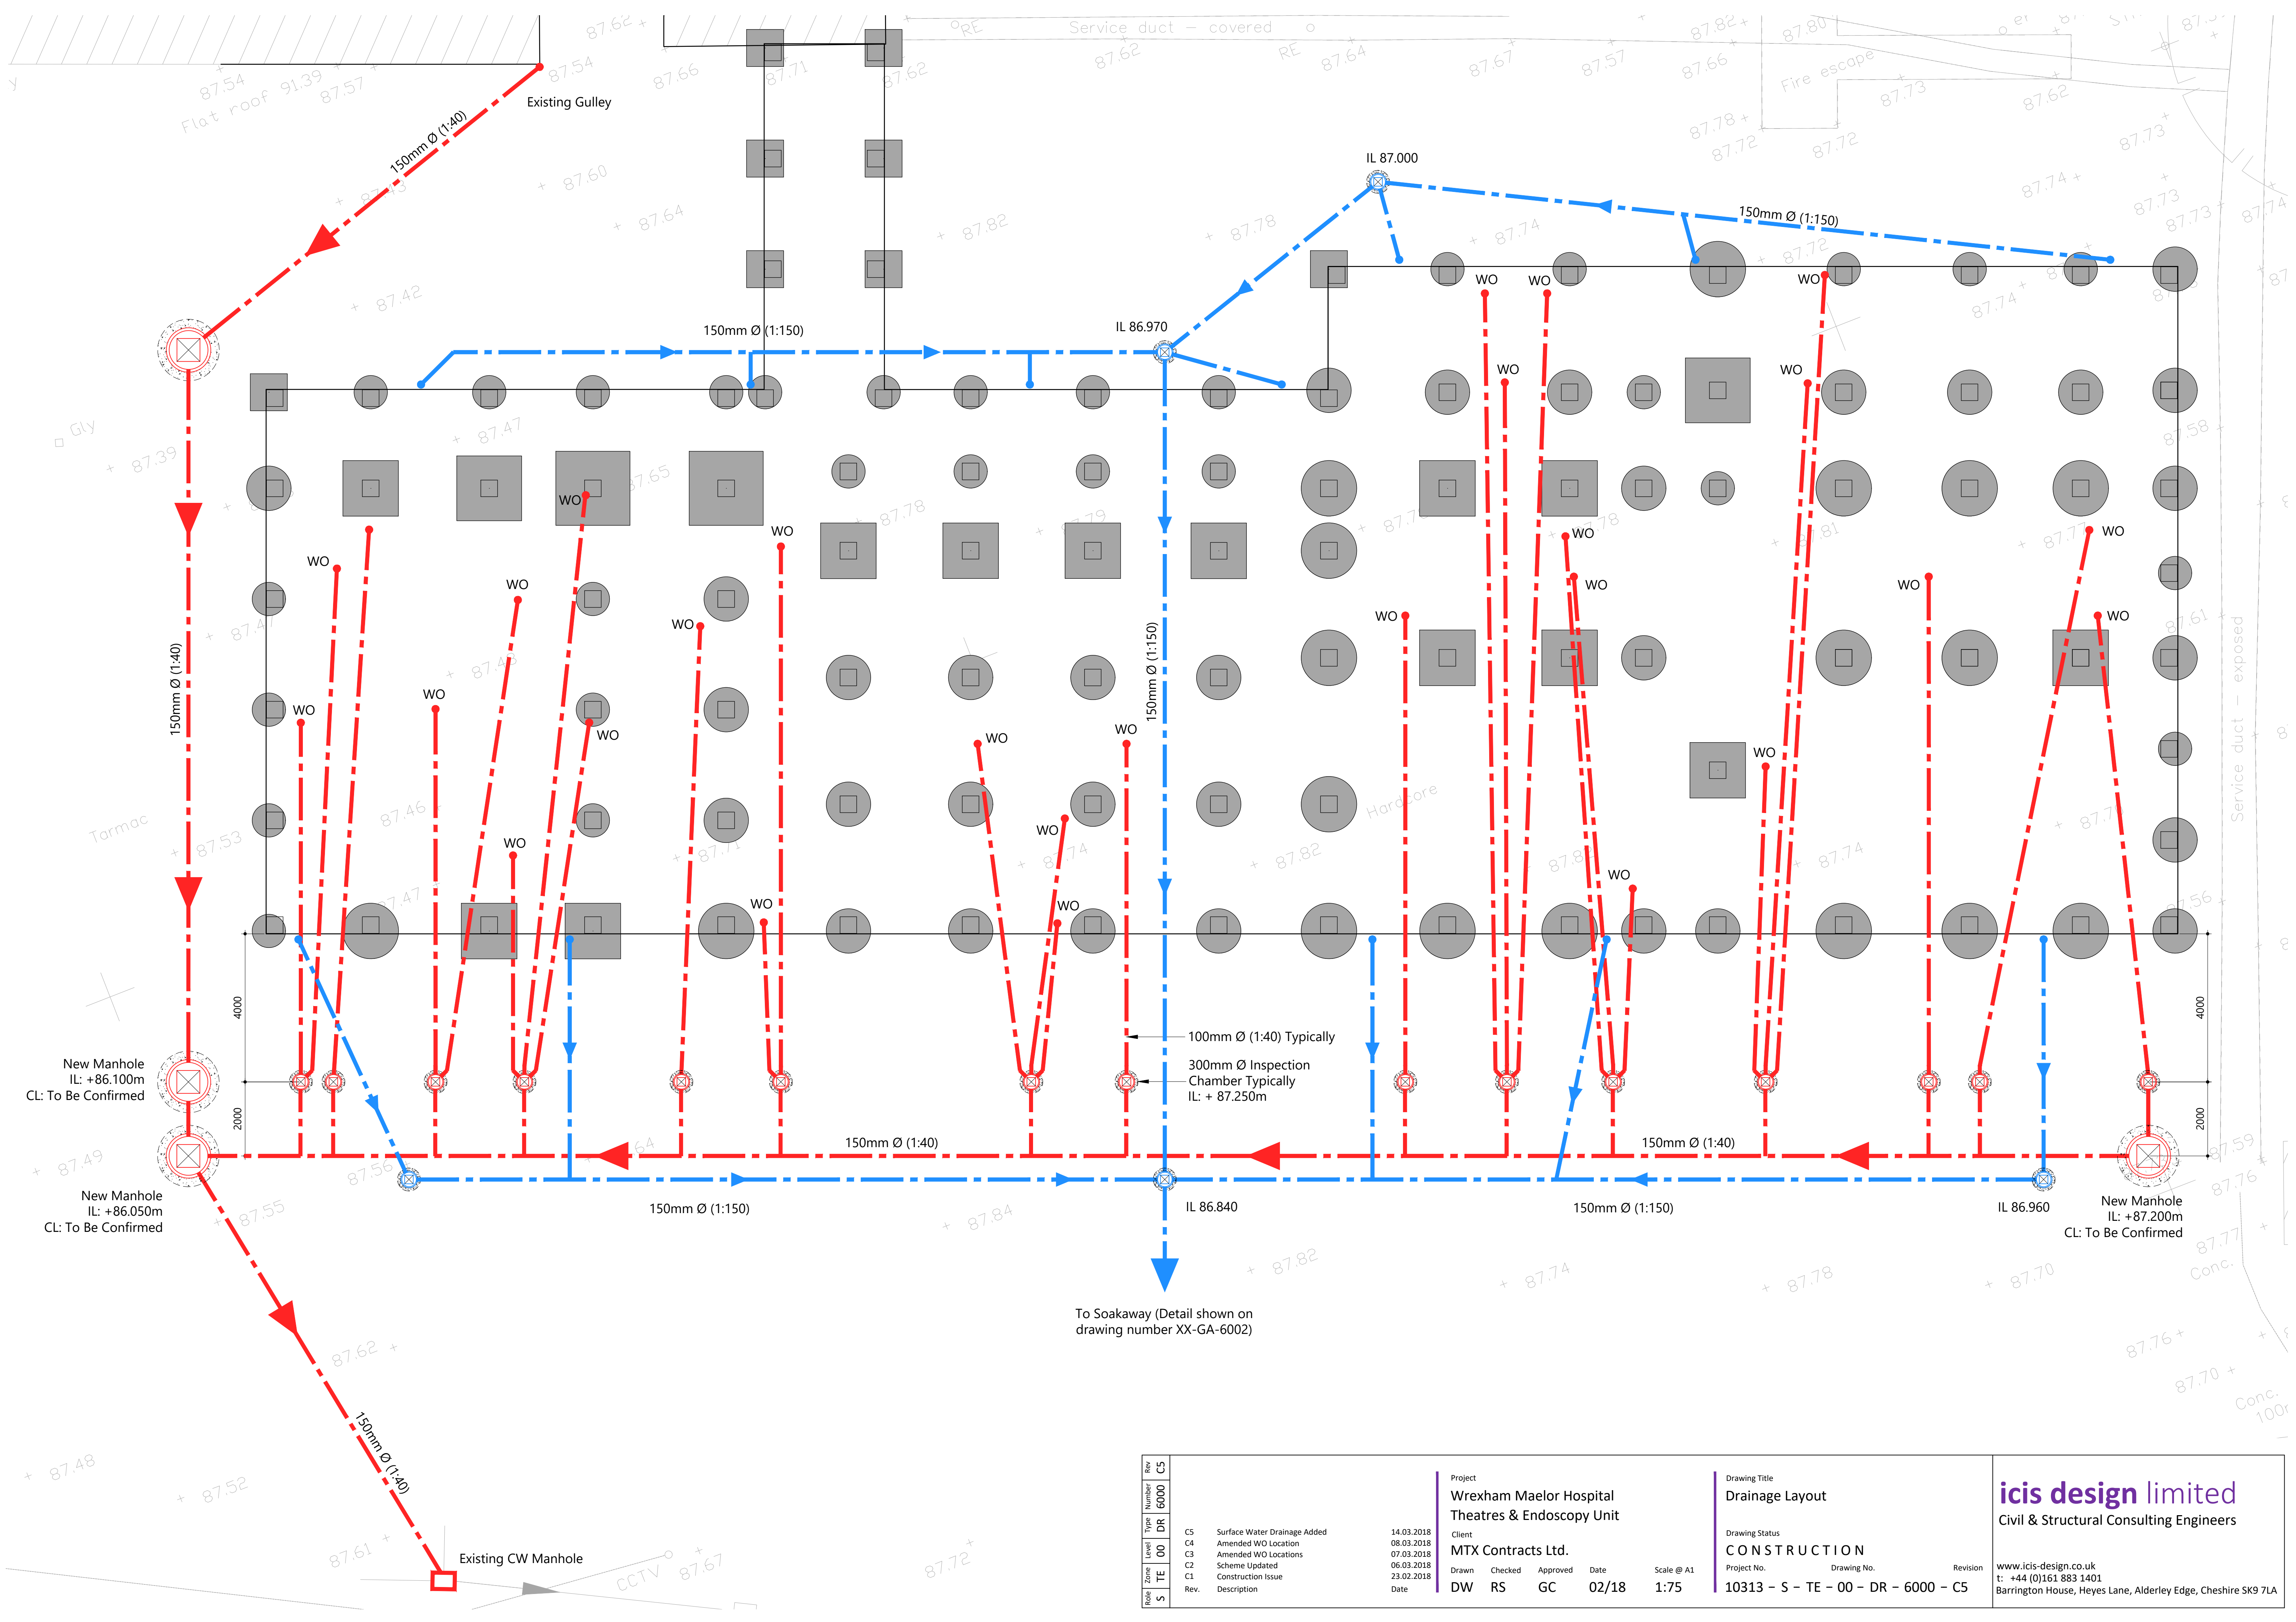

Revis	Zone	Level	Type	Number	Rev	Project				Drawing Title		icis design limited Civil & Structural Consulting Engineers	
						Wrexham Maelor Hospital Theatres & Endoscopy Unit				Drainage Layout			
						Client				Drawing Status		www.icis-design.co.uk t: +44 (0)161 883 1401 Barrington House, Heyes Lane, Alderley Edge, Cheshire SK9 7LA	
						MTX Contracts Ltd.				CONSTRUCTION			
						Drawn	Checked	Approved	Date	Scale @ A1	Project No.		
DW	RS	GC	02/18	1:75	10313 - S - TE - 00 - DR - 6000 - C5								

C5	Surface Water Drainage Added	14.03.2018
C4	Amended WO Location	08.03.2018
C3	Amended WO Locations	07.03.2018
C2	Scheme Updated	06.03.2018
C1	Construction Issue	23.02.2018
Rev.	Description	Date