 

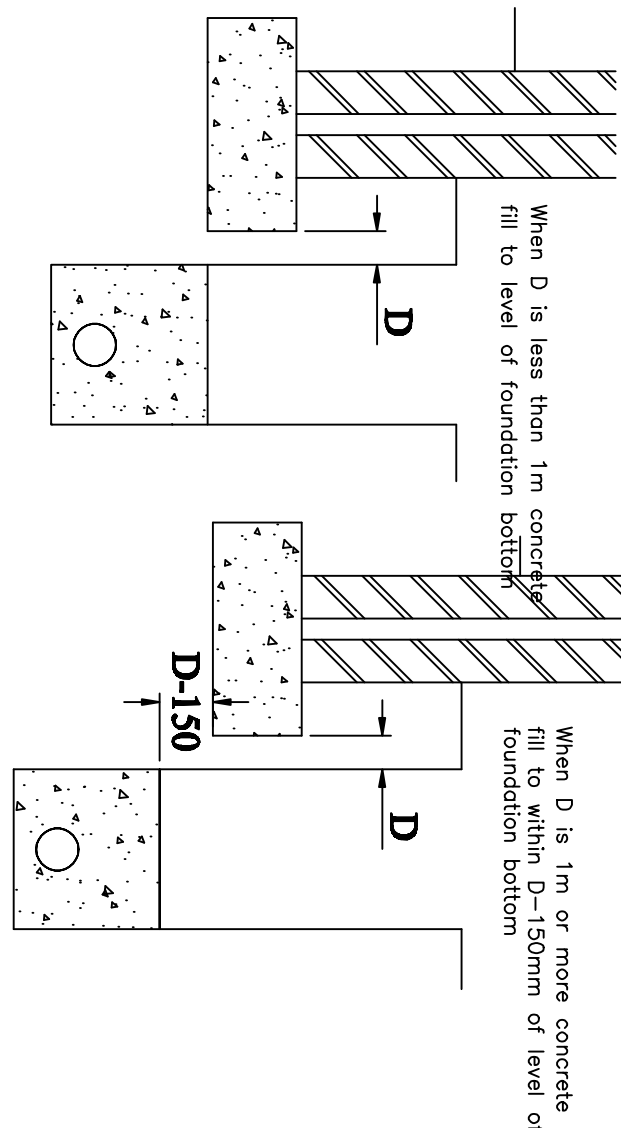
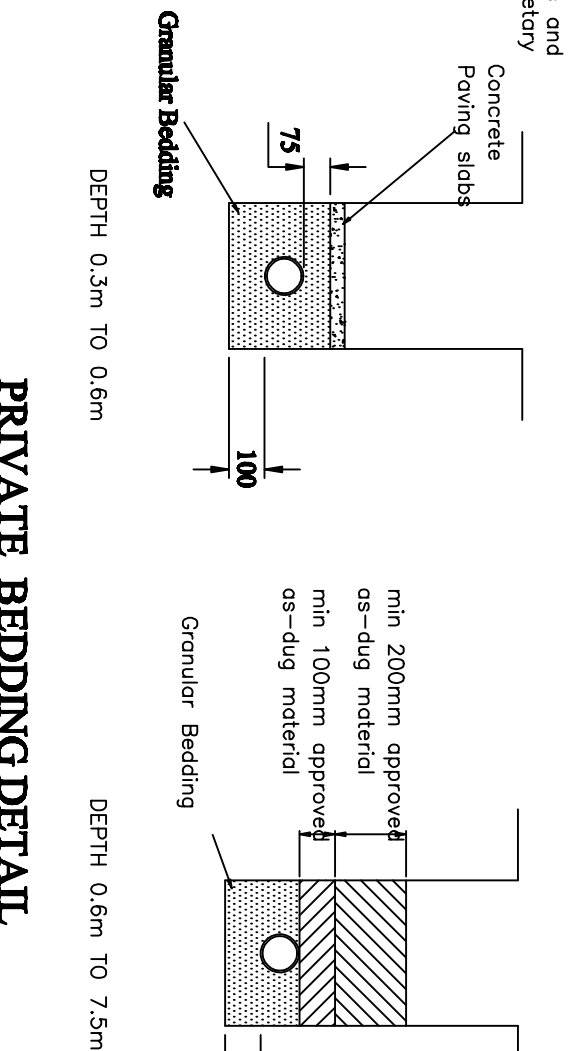
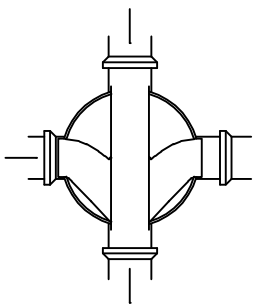
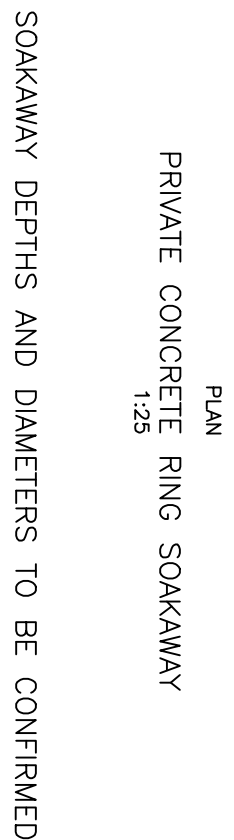


DO NOT SCALE	
--------------	--

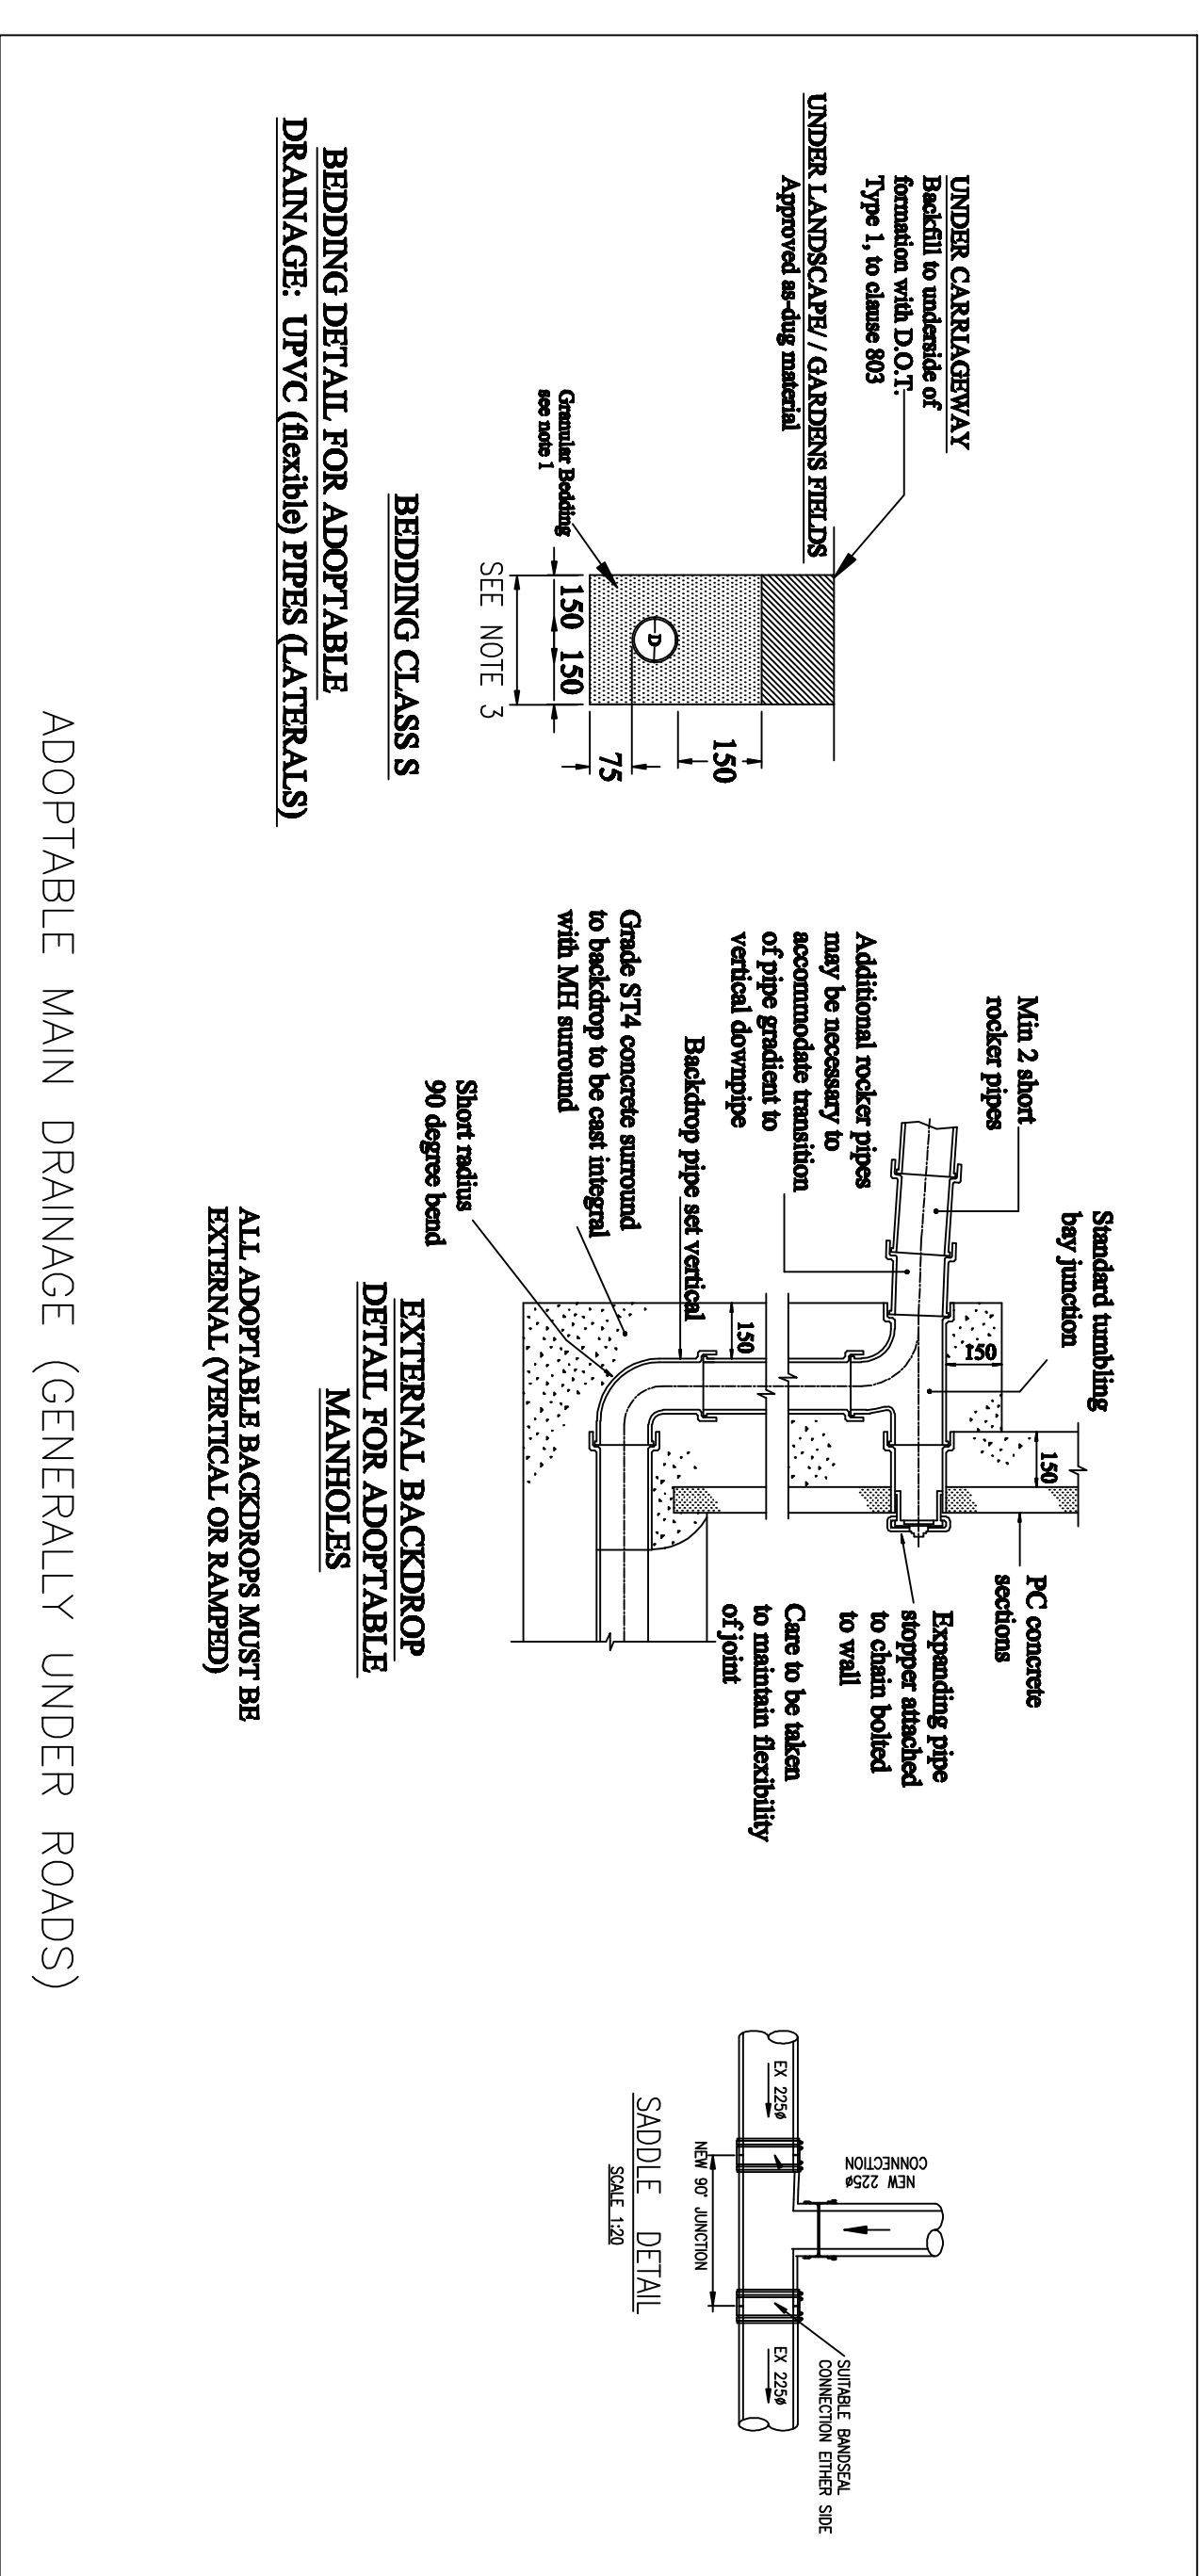

ADOPTABLE LATERALS	
TYPE 4	REFER TO "SEWERS FOR ADOPTION 7th" MAX DEPTH 2.0m
TYPE 3	REFER TO "SEWERS FOR ADOPTION 7th" MAX DEPTH 3.0m

DETAILS OF PIPE RUNS NEAR BUILDINGS / STRUCTURES

DRAINAGE LAYOUT

DRAWING NUMBER 1216/05	SCALE		1:250	@ 1'
	DATE	8.11.13	REVISION	
	DRAWN	AK		
	CHECKED	AK	A	