

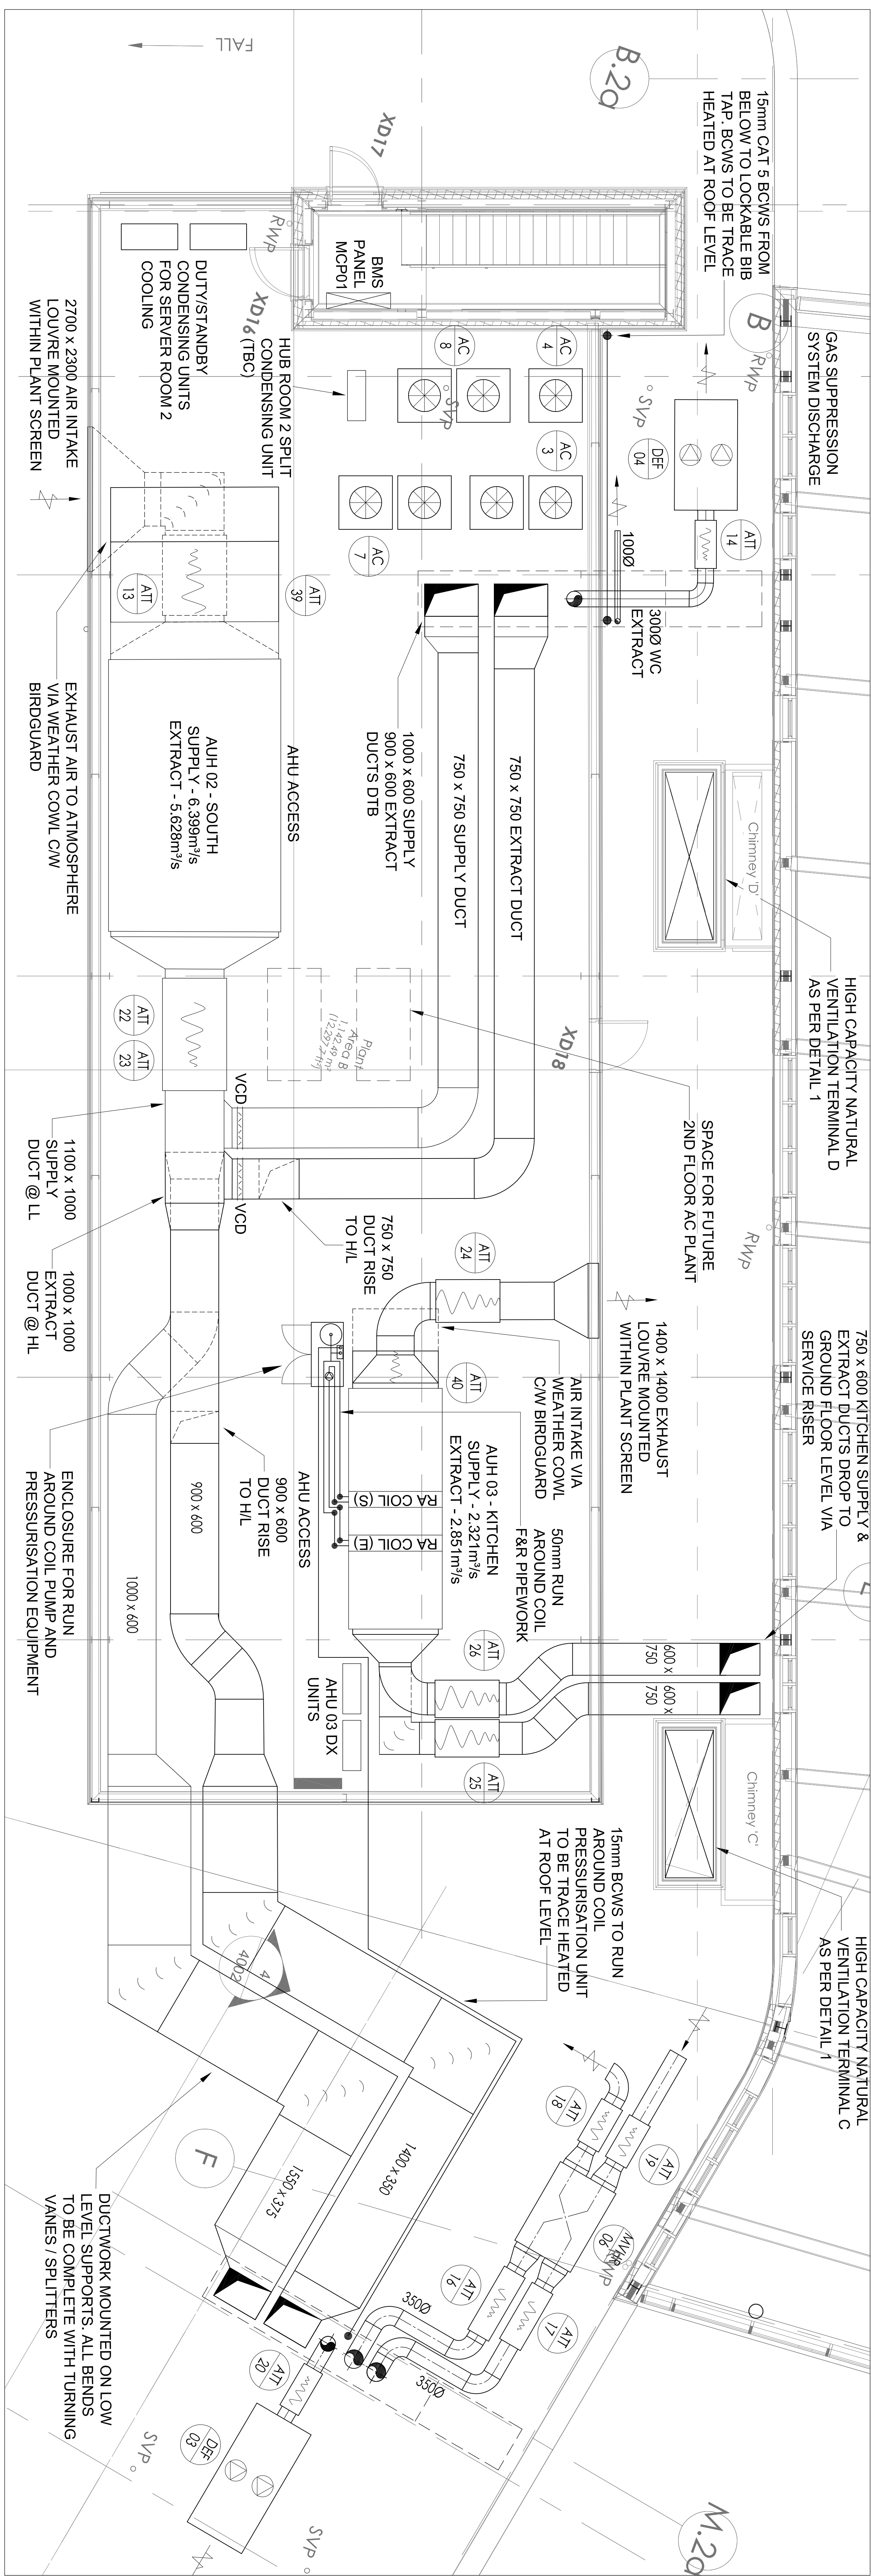
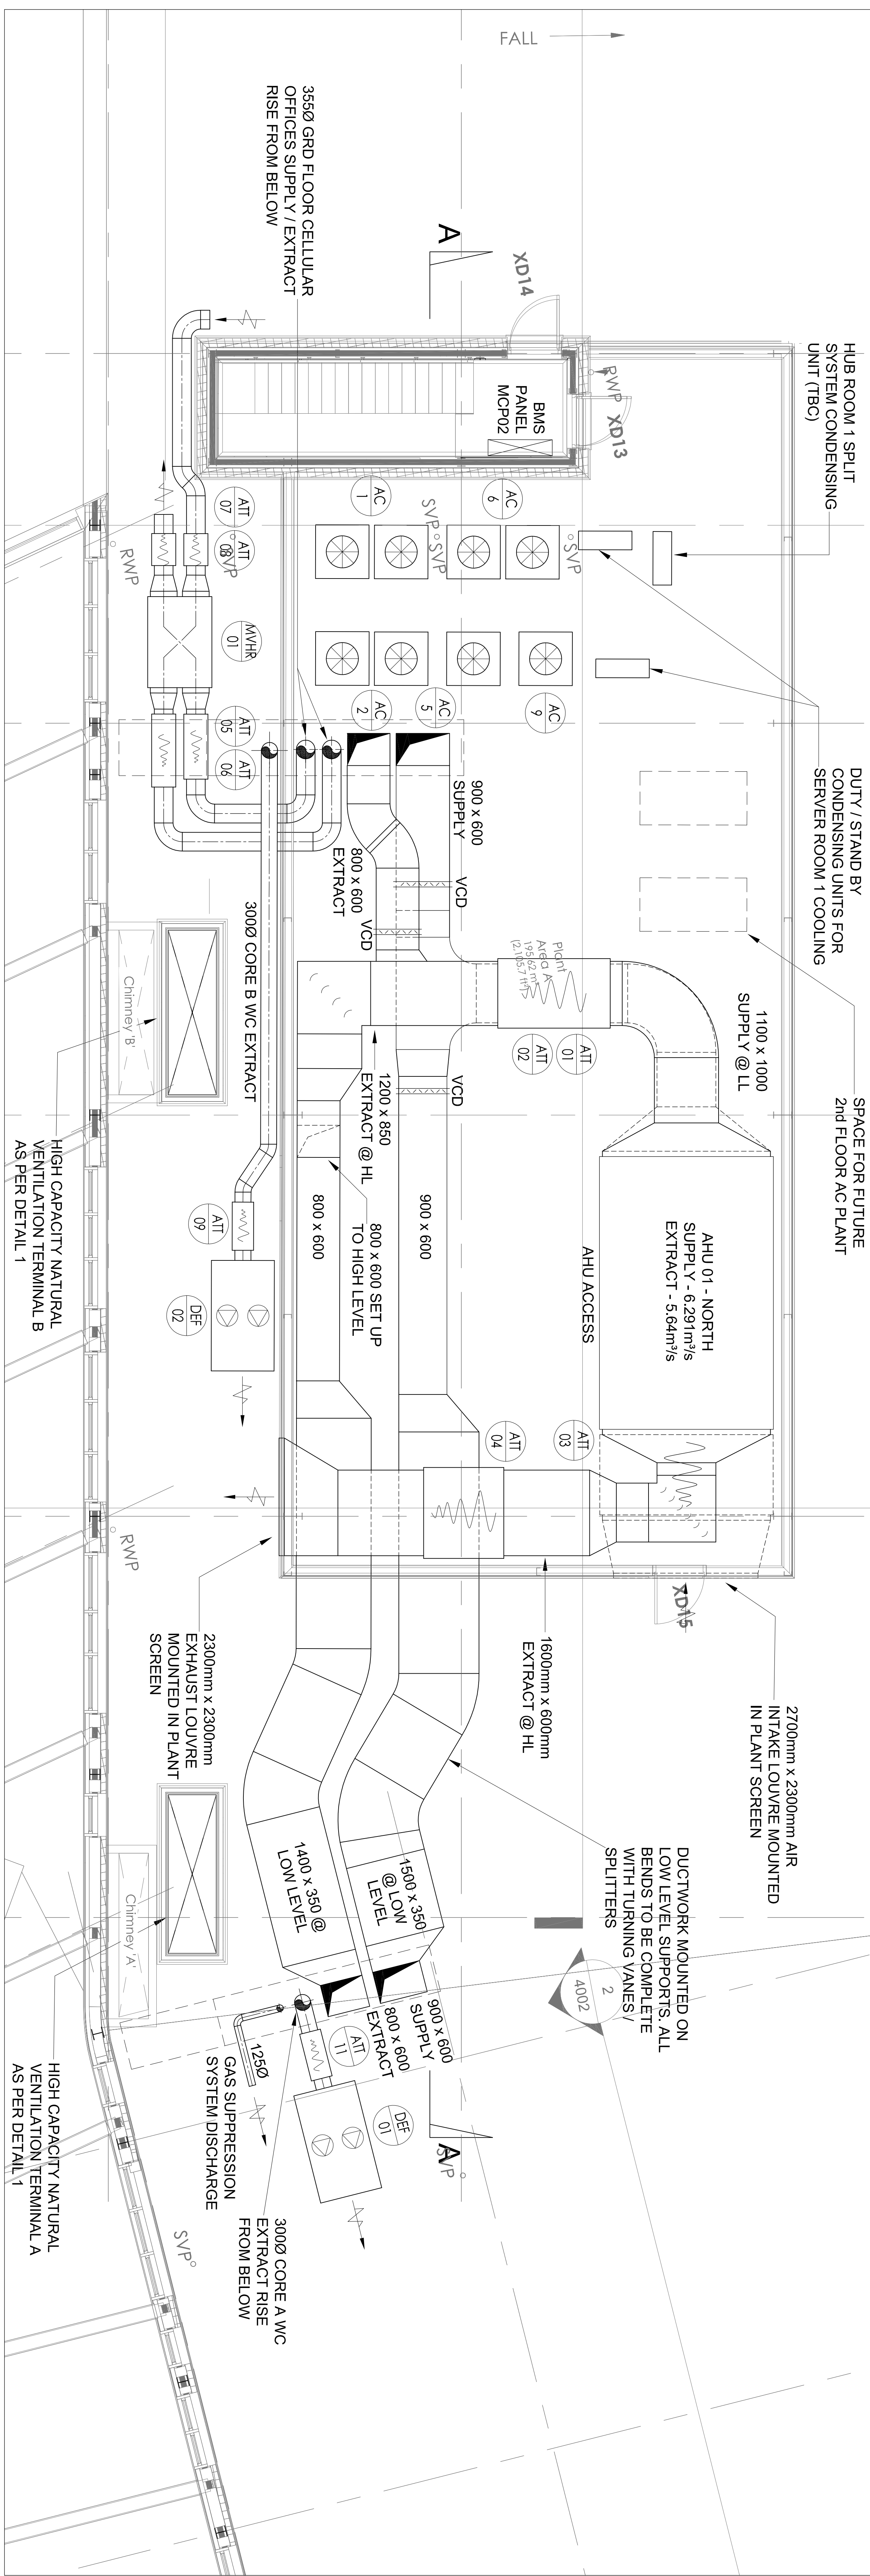
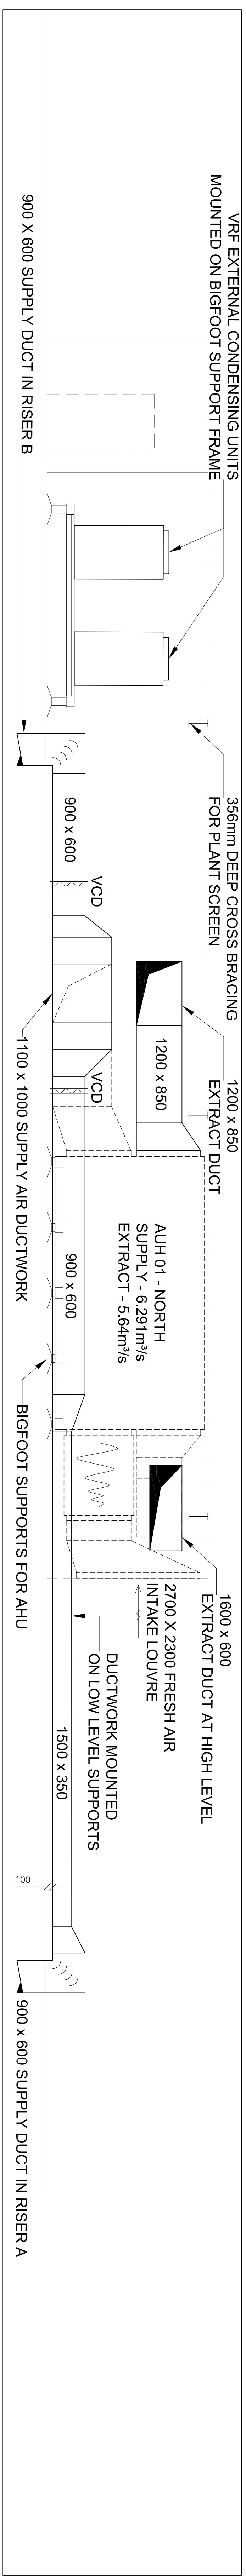


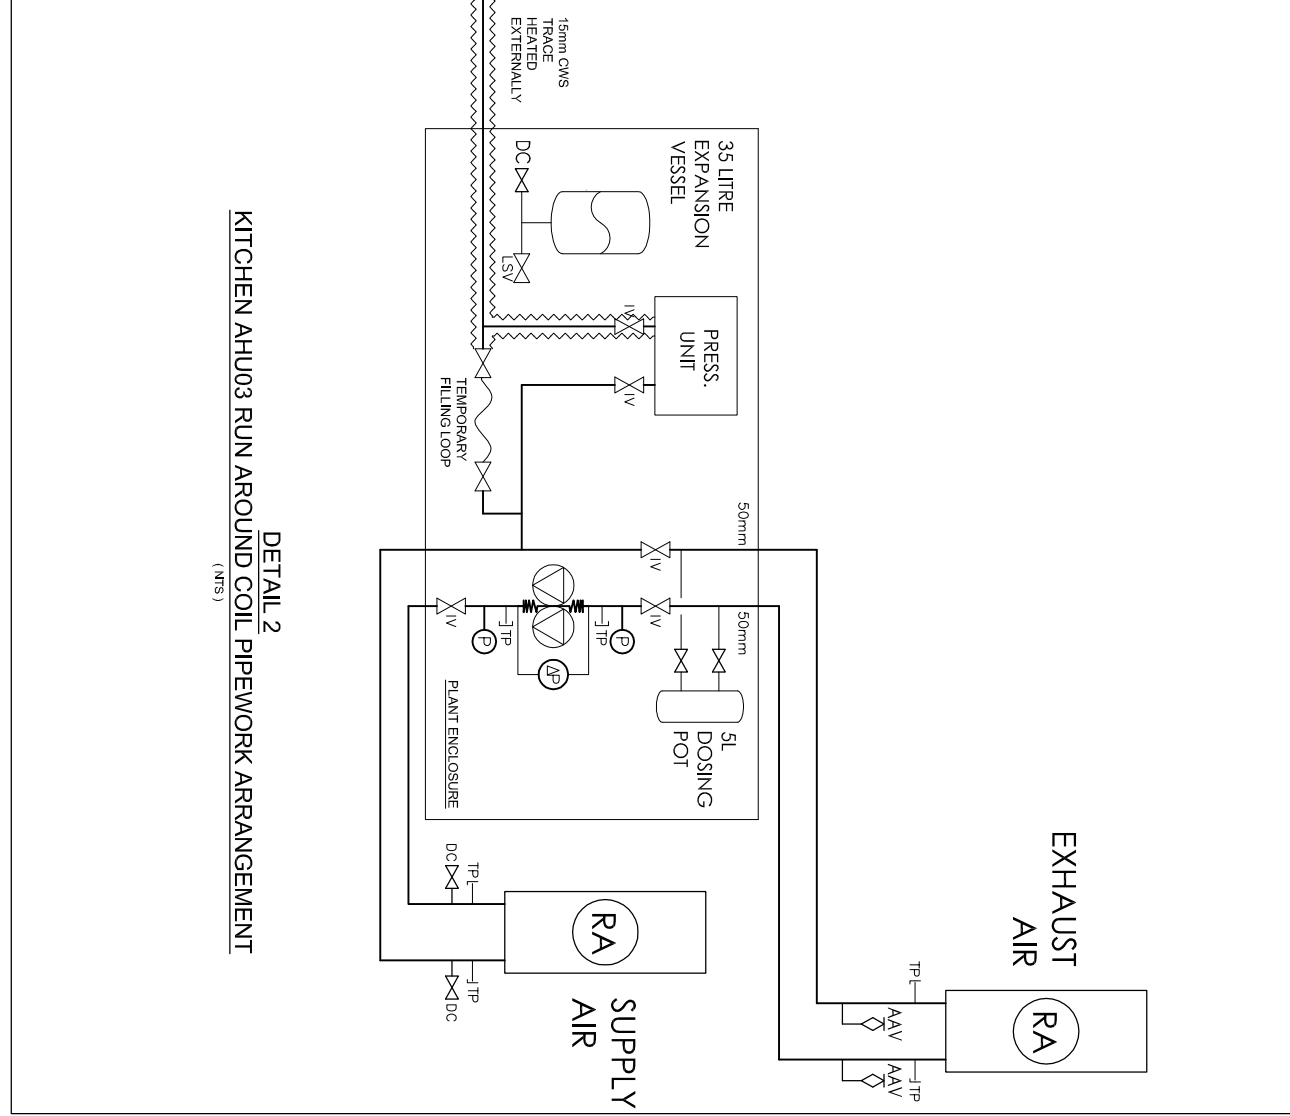

- NOTES
1. THIS DRAWING SHALL BE READ IN CONJUNCTION WITH ALL ARCHITECTURAL, STRUCTURAL AND CONSULTANT SPECIFICATIONS, DOCUMENTS AND DRAWINGS.
2. DIMENSIONS SHALL BE FIELD IN CONJUNCTION WITH THE SERVICES SPECIFICATIONS.
3. ALL DIMENSIONS STATED IN MM.
4. DUCTWORK SHALL BE INSTALLED IN GALVANIZED STEEL WITH GROUND PROTECTOR AND SPRAU BOLTS, SPACING WHERE POSSIBLE OR OTHERWISE STATED IN RECTANGULAR GALVANIZED STEEL. DUCTWORK SHALL BE INSTALLED IN ACCORDANCE WITH HICA DIV. 14 AND IS IS 1905.
5. ALL RECTANGULAR DUCTWORK SHALL BE FIELD SIZED FOR 60 MINUTES FIRE RESISTANCE AND STABILITY.
6. ALL DUCTWORK FOR INSPECTION, MAINTENANCE AND COMMISSIONING IN ACCORDANCE WITH HICA DIV. 45 AND HICA TR19.
7. VOLUME CONTROL DAMPERS IN ACCORDANCE WITH HICA DIV. 14 ARE TO BE INSTALLED IN ALL DUCTWORK BRANCHES.
8. DUCTWORK SHALL BE SIZED TO THE FURNITURE AREA TO COMPLY WITH HICA DIV. 112.
9. ALL FINAL DUCTWORK CONNECTIONS TO GRATES SHALL BE VIA FLEXIBLE DUCTWORK WITH A MAXIMUM LENGTH OF 300MM.
10. ALL DUCTWORK SHALL BE FIELD SIZED TO ALLOW FOR THE PASSAGE OF MORE UP AND INTO THE ROOMS.
11. ALL FRESH AIR INLET/LEAKS TO BE COMPLETE WITH REMOVABLE INSECT MESH.
12. THE CONTRACTOR IS TO ENSURE ALL DUCTWORK ASSIGNED THROUGH THE ROOMS IS PROVIDED WITH A FIRE DAMPER SUIT TO THE MEETING OF THE REQUIREMENTS.
13. WHERE FURNITURE ARE SHOWN THESE ARE TO BE SIZED TO MEET THE REQUIREMENT IN VALUES OUTLINED WITH THE ACoustIC CONSULTANTS DOCUMENTATION.

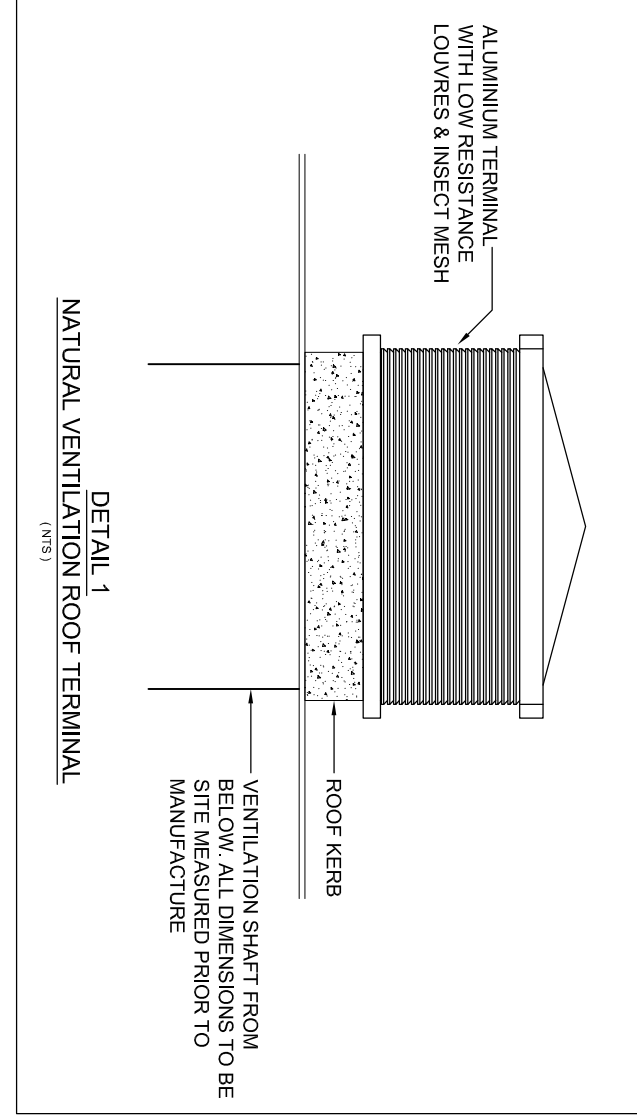

Revision	Description	Date
----------	-------------	------

 **Larewood**
Complete building services

Client:	Poohin Construction Limited
	Buy Business Centre, Gyle Street, Bury, B19 4BL, t: 0161 744 3071, e: info@browwood.co.uk
Project:	Monoramp
Address:	Wrexham
Drawing:	Roof Ventilation Layout
Position:	665_1329 M18
Drawn by:	JJ
Scale:	1:50
Revision:	1
Construction:	