
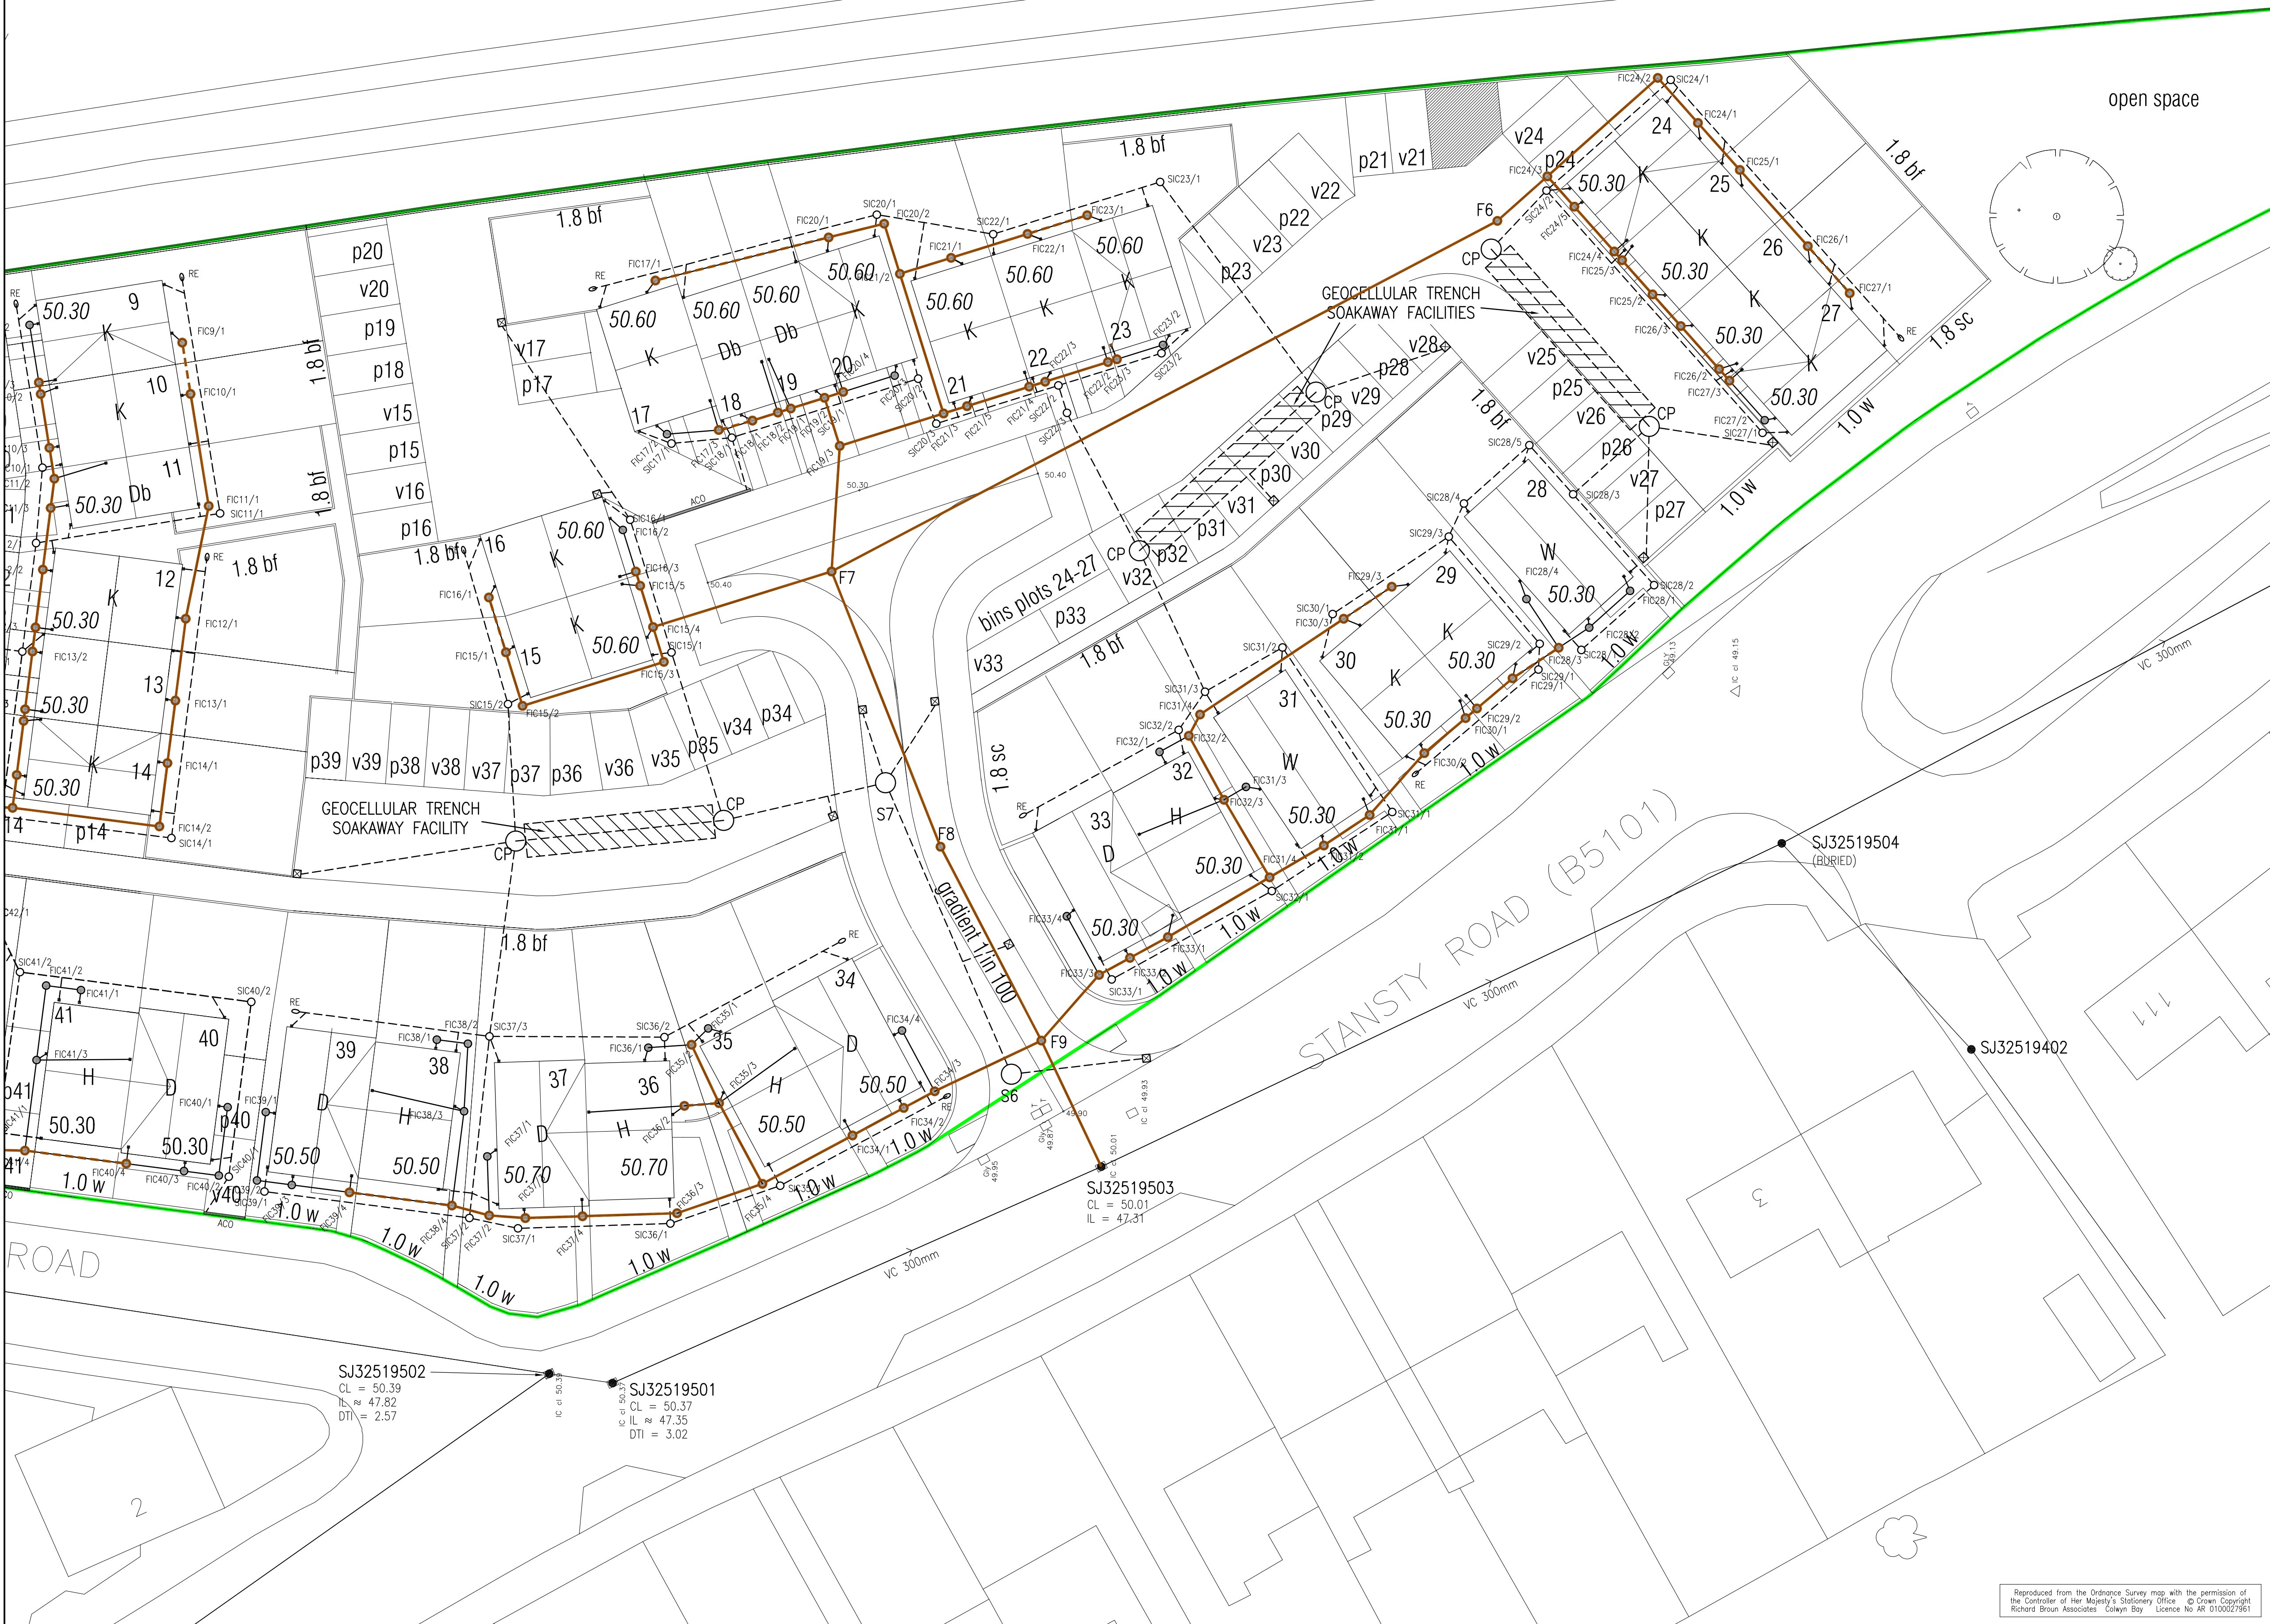
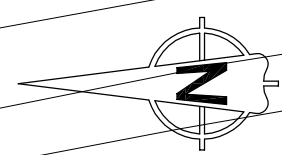


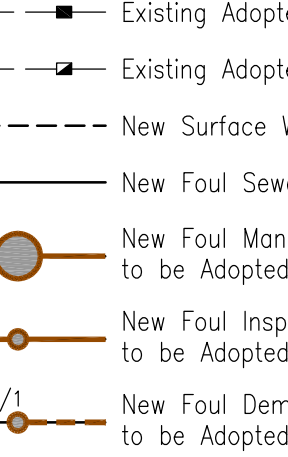

LEGEND

- 
- Legend for Sanitary Sewer Symbols:
- Development Boundary
 - Existing Adopted Foul/Combined Sewer
 - Existing Adopted Foul Manhole
 - Existing Adopted Combined Manhole
 - New Surface Water Sewer
 - New Foul Sewer
 - F1 New Foul Manhole and Reference to be Adopted
 - F1 New Foul Inspection Chamber and Reference to be Adopted
 - FIC1/1 New Foul Demarcation Chamber and Reference to be Adopted
 - FIC1/1 New Foul Inspection Chamber and Reference Private
 - S1 New Surface Water Manhole and Reference to be Adopted (Highway Authority)
 - S1 New Surface Water Inspection Chamber and Reference
 - RE Private SW Rodding Eye & Reference
 - G1 Road Gully
 - YG Private Yard Gully
 - ACO ACO Drain
 - Backdrop

NOTES

1. All dimensions in metres unless stated otherwise
2. All levels in metres relative to Local Datum as topographical survey by others
3. This drawing to be read in conjunction with all other drawings referred to on the document and drawing issue sheet
4. The Developer must self-verify and certify that the design criteria, material standards and workmanship specifications for the proposed adoptable sewers are in accordance with those set out in Sewers for Adoption 7th Edition and the requirements of DCWW as the Statutory Sewerage Undertaker, and the Welsh Ministers' Standards
5. Foul and surface water drainage layout subject to detailed approval by Dwr Cymru/Welsh Water
6. Highway drainage and soakaways subject to the approval of Wrexham County Borough Council Highways and Drainage Departments. To be adopted under Section 38 agreement (Highway Authority).
7. All proposed levels to be checked and confirmed on site by the contractor prior to commencement of works. Any discrepancies to be reported to the engineer immediately. All downstream levels to be checked and confirmed by the contractor prior to construction of any upstream drainage.
8. Refer to architects drawings for all domestic foul & sw drainage connection positions around and within buildings
9. Refer to Sewers for Adoption 7th Edition and Welsh Ministers' Standards Design and Construction of New Gravity Foul sewers and Latent Drains (July 2012) for MH construction details
10. The plastic pipes approved by Dwr Cymru Welsh Water for Gravity sewers, for diameters of 150mm – 300mm, are as follows:
 - Marley Twinwall system
 - Uponor Ultrarib system
 - Osma Ultrarib system
 - Polysewer Twinwall system
 - Pipelines – Rigisever (400mm–600mm and 750mm–900mm)
11. The installer of UPVC pipework to adoptable sewers must be accredited with the British Plastics Federation (BPF), plastic pipes group. A copy of the Accreditation Certificate to be issued before any work on site is commenced

PRELIMINARY

REV	DATE	NATURE OF REVISION	BY	CHECKED

DO NOT SCALE THIS DRAWING. THIS DRAWING IS COPYRIGHT. CONTRACTORS MUST CHECK ALL DIMENSIONS ON SITE. ARCHITECT / ENGINEER TO BE NOTIFIED OF ANY DISCREPANCIES.

Chartered Engineers & Architects

26 Mostyn Road Colwyn Bay Conwy LL29 8PB
T: (01492) 533117 F: (01492) 530895 E: broun@rba.ltd.uk

CLIENT | GOWER HOMES

PROPOSED RESIDENTIAL DEVELOPMENT
THE SIDINGS
RAILWAY ROAD, WREXHAM

DRAINAGE GENERAL ARRANGEMENT
SECTION 104 AGREEMENT: 2 OF 2

SCALE	1:200	SIZE	A1	DRAWN	CHKD	DATE	JOB No	3916	DWG No	05	REV	.
				RW		01.13						

Reproduced from the Ordnance Survey map with the permission of
the Controller of Her Majesty's Stationery Office © Crown Copyright
Richard Brown Associates Colwyn Bay Licence No AR 0100027961