





EXISTING OUTDOOR UNITS

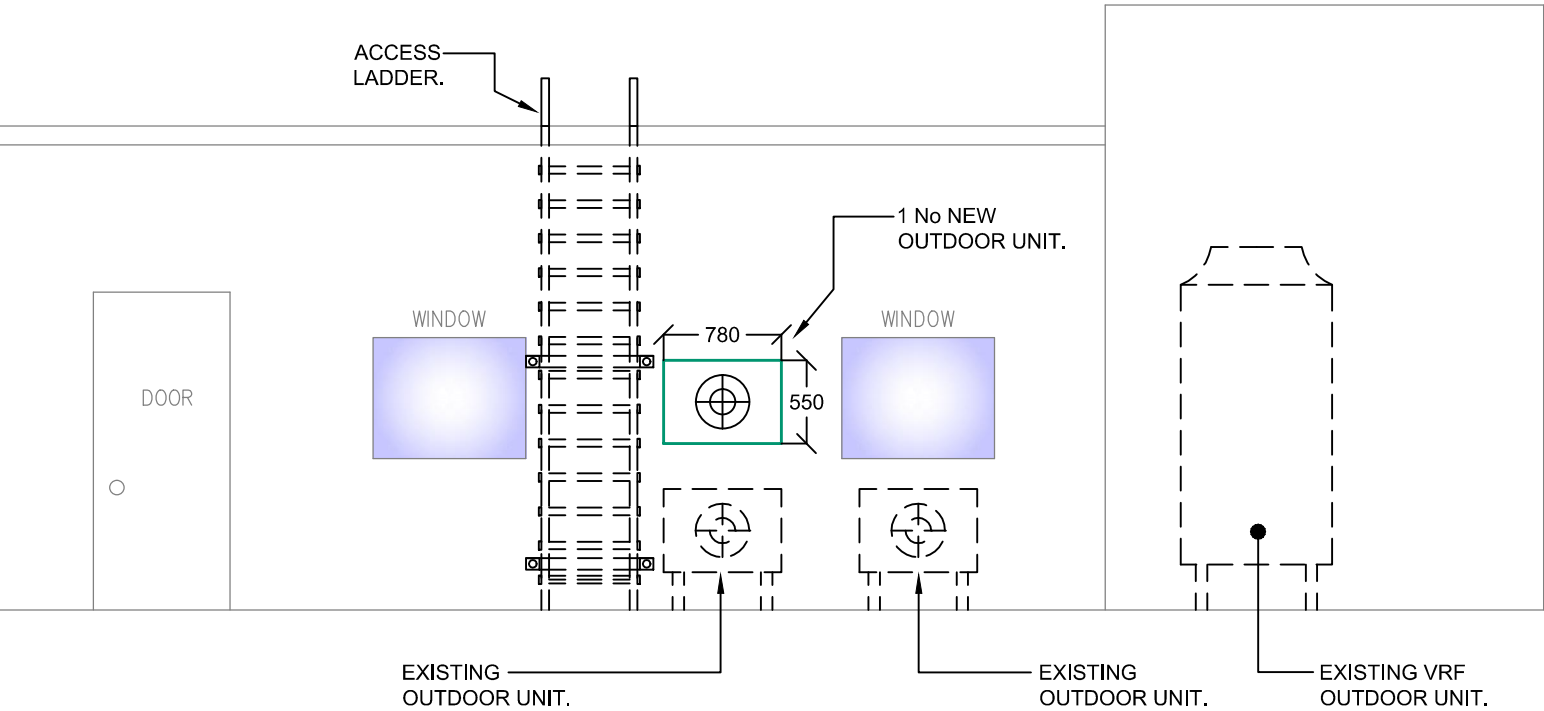

SECTION 'A-A' - SCALE 1:50

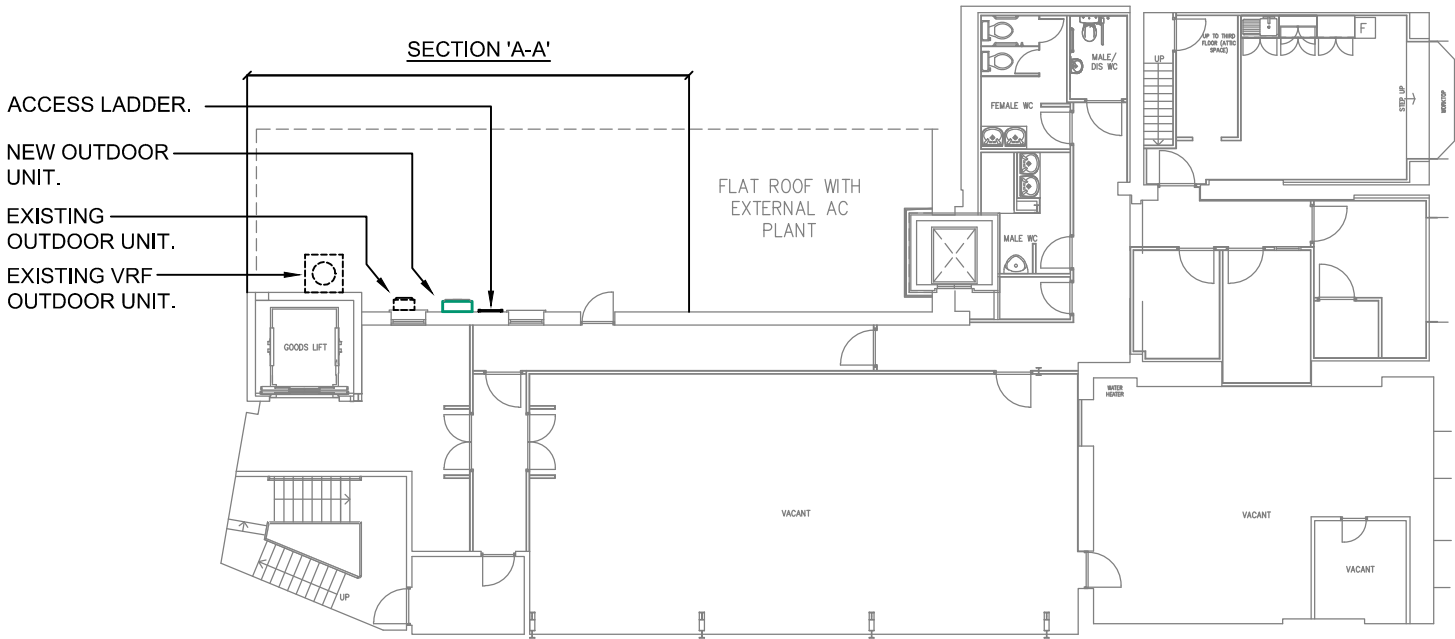

SECOND FLOOR - SCALE 1:200

NEW AIR-CONDITIONING SYSTEMS

REF	Description	Location	Make	Model	Duty [cooling/heating]	Size [H x W x D] mm	Weight	Sound Pressure	Control	Electrical
AC1	Wall mounted type indoor unit	ASD Room	Toshiba	RAVSM566KRT-E	5.0kW / 5.6kW	298 x 998 x 208	21Kg	36 dBA	Local controller	FROM OUTDOOR
OU1	Heat pump type outdoor unit	Roof	Toshiba	RAVSM564ATP-E	5.0kW / 5.6kW	550 x 780 x 290	38Kg	46dBA	Indoor unit	230/1/16 AMP

MECHANICAL PLANT SCHEDULE

BASED ON LAYOUT
113.

CONSTRUCTION ISSUE

PROJECT
BARCLAYS – WREXHAM
51–52 HOPE STREET,
WREXHAM
LL11 1BE.



TITLE
SECOND FLOOR
CONDENSER LOCATION LAYOUT



M&E BUILDING SERVICES LTD
DL M&E BUILDING SERVICES LTD
EMPIRE HOUSE
620A MANCHESTER ROAD
WESTHOUGHTON
BOLTON
BL5 3JD
TEL : 01942 842507
FAX : 01942 842502
E-MAIL : enquiries@dl-electrical.co.uk

THIS DRAWING IS THE PROPERTY OF DL M&E BUILDING SERVICES LIMITED.
AND MUST NOT BE COPIED OR REPRODUCED WITHOUT THE PERMISSION IN
WRITING OF DL M&E BUILDING SERVICES LIMITED.

DRAWN D LOWE CAD A.B CHECKED D LOWE

SCALE 1:200/1:50 AT A3 DATE MARCH 2014

DRAWING No C/14/137-M02 REV —

