


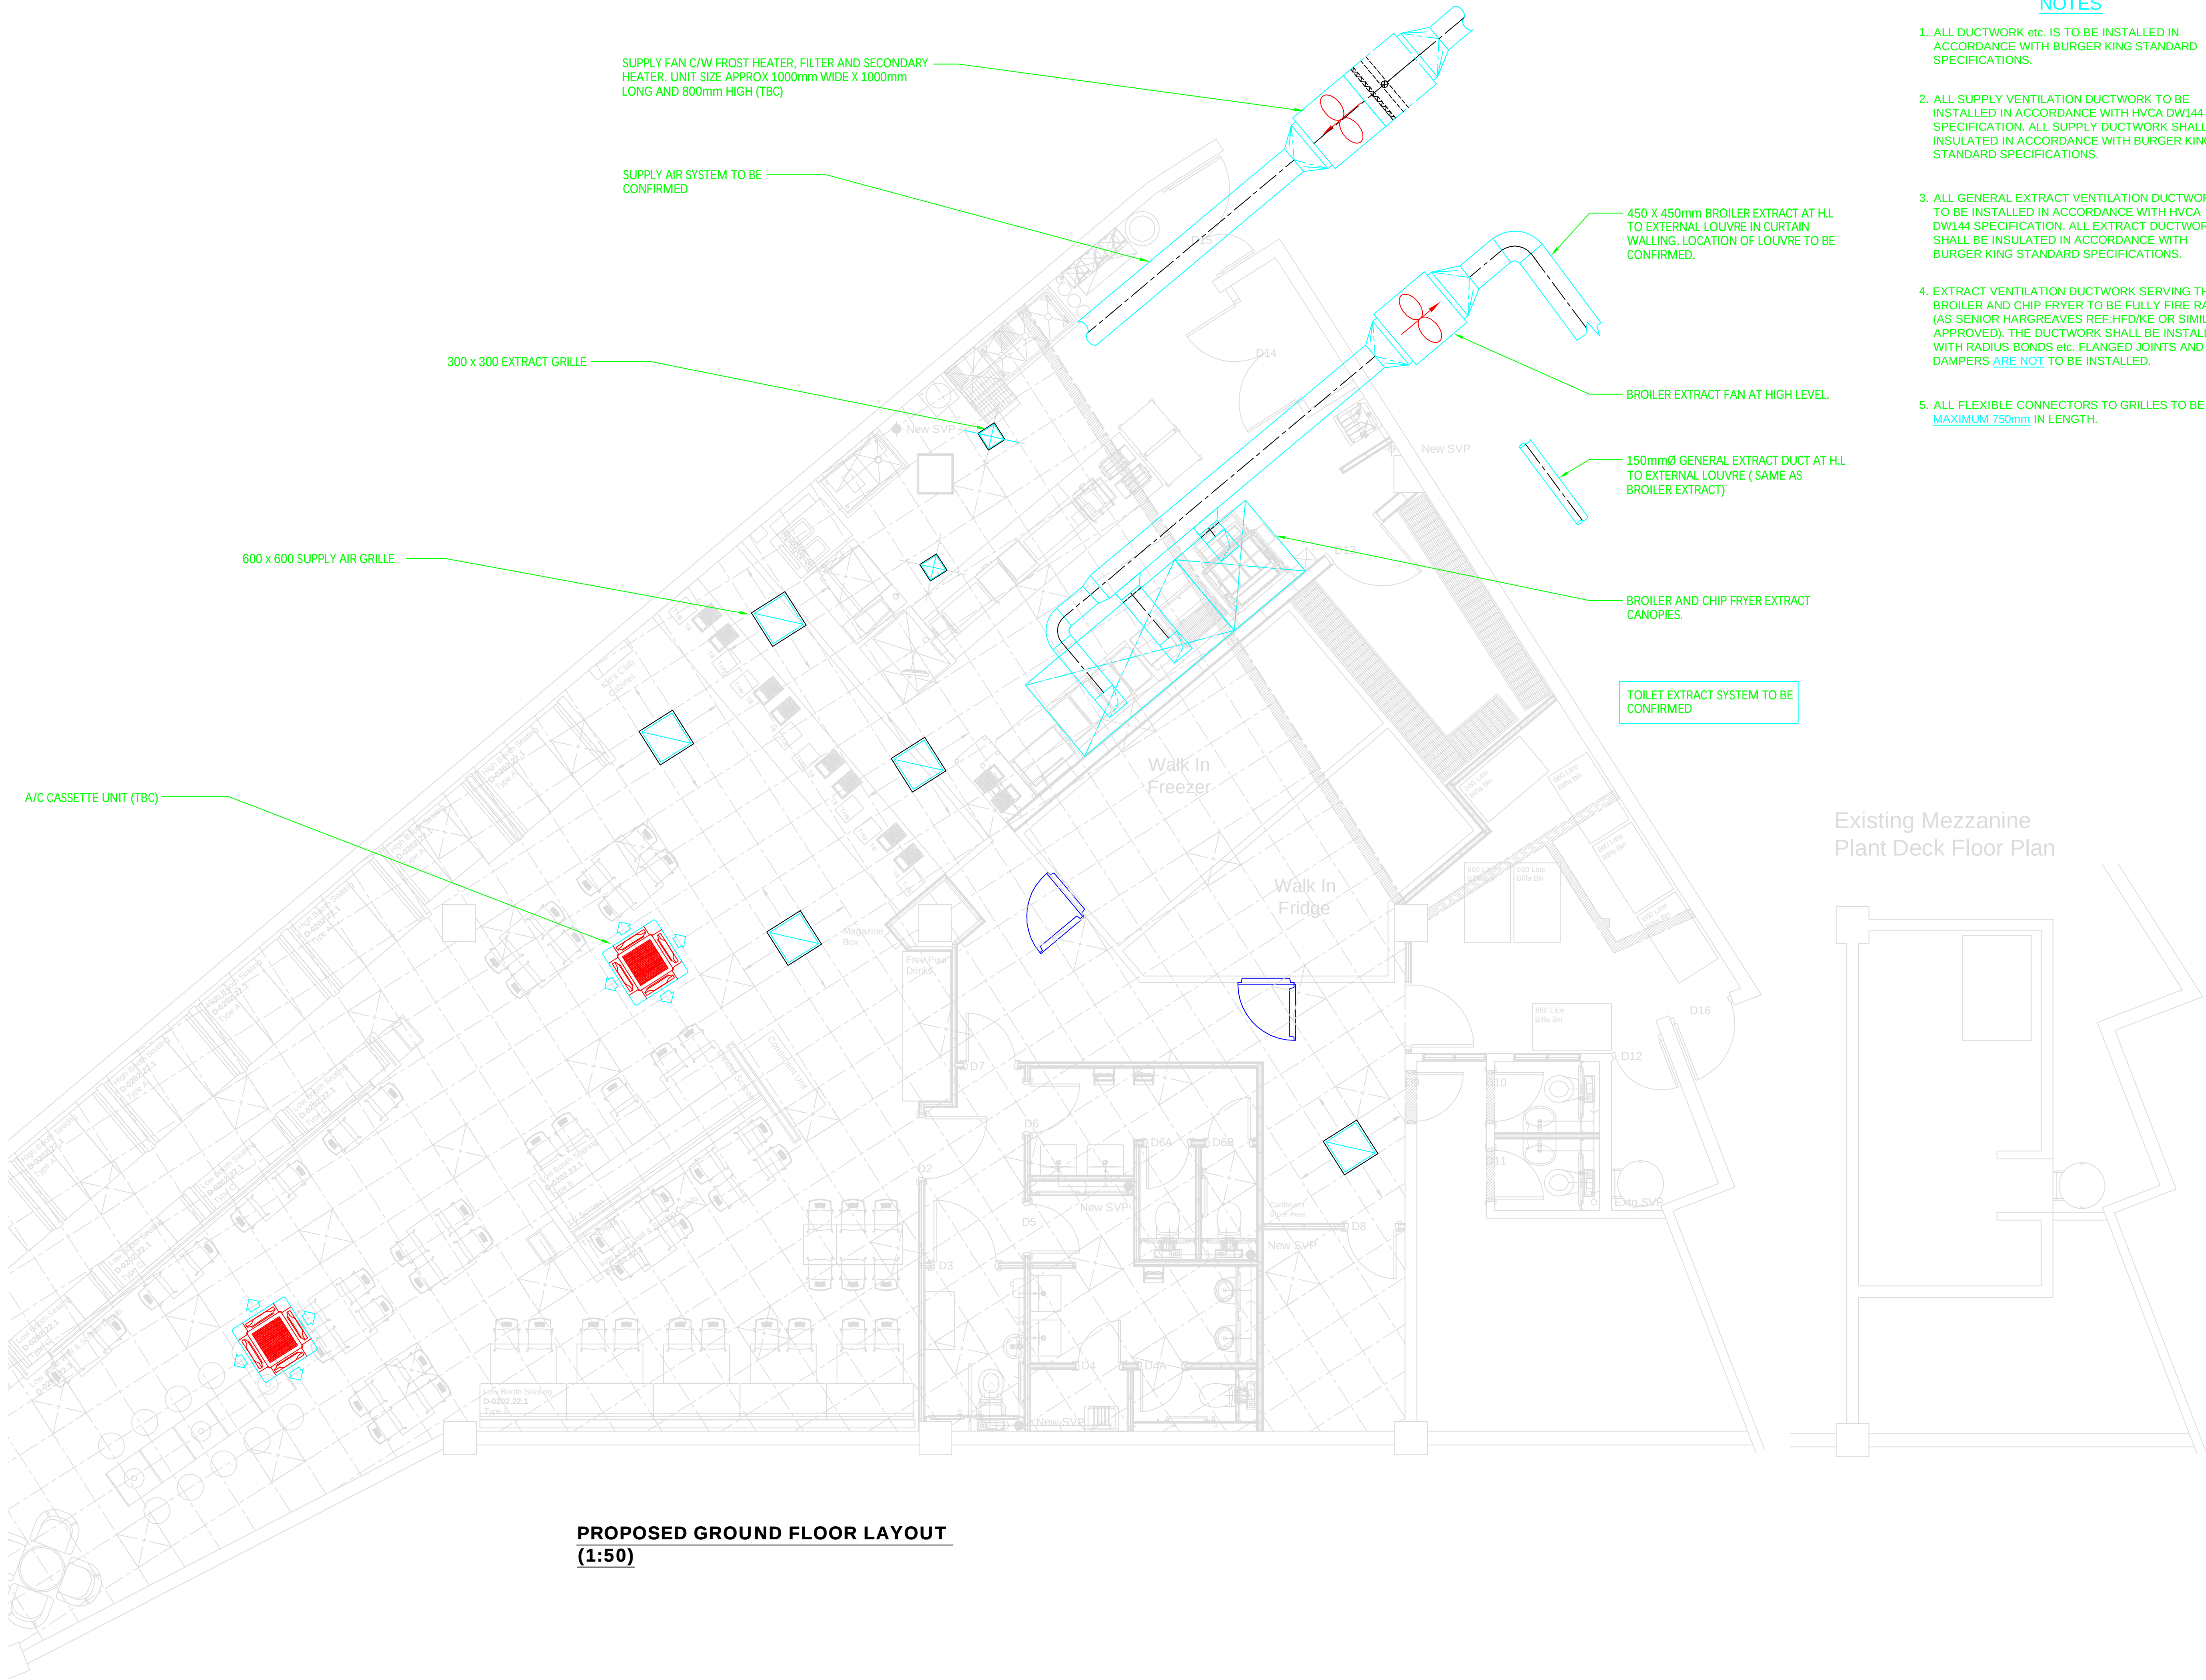

**PROPOSED GROUND FLOOR LAYOUT
(1:50)**

NOTES

1. ALL DUCTWORK etc. IS TO BE INSTALLED IN ACCORDANCE WITH BURGER KING STANDARD SPECIFICATIONS.
2. ALL SUPPLY VENTILATION DUCTWORK TO BE INSTALLED IN ACCORDANCE WITH HVCA DW144 SPECIFICATION. ALL SUPPLY DUCTWORK SHALL BE INSULATED IN ACCORDANCE WITH BURGER KING STANDARD SPECIFICATIONS.
3. ALL GENERAL EXTRACT VENTILATION DUCTWORK TO BE INSTALLED IN ACCORDANCE WITH HVCA DW144 SPECIFICATION. ALL EXTRACT DUCTWORK SHALL BE INSULATED IN ACCORDANCE WITH BURGER KING STANDARD SPECIFICATIONS.
4. EXTRACT VENTILATION DUCTWORK SERVING THE BROILER AND CHIP FRYER TO BE FULLY FIRE RATED (AS SENIOR HARGREAVES REF:HFD/KE OR SIMILAR APPROVED). THE DUCTWORK SHALL BE INSTALLED WITH RADIUS BONDS etc. FLANGED JOINTS AND DAMPERS ARE NOT TO BE INSTALLED.
5. ALL FLEXIBLE CONNECTORS TO GRILLES TO BE MAXIMUM 750mm IN LENGTH.

NOTES

This Drawing is the property of Yorkshire Building Services. It must not be reproduced in part or whole nor the design used without written consent. Do not scale from this drawing.

Rev	By	Date	Apr	Details
-----	----	------	-----	---------



YORKSHIRE BUILDING SERVICES LTD
ACCESS WORKS, MARTIN STREET,
BIRSTALL, BATLEY, WF17 9PJ
Tel: 01924 471955 - Fax: 01924 477508
Web: www.ybsltd.co.uk

Project
**BURGER KING
WREXHAM**

Drawing Title.
PROPOSED VENTILATION LAYOUT

Scale	1 : 50@A1	Date	18/10/13
Drawn	YBS/CT	Checked	

Drawing No.	4676/M01		
-------------	----------	--	--

