


NOTES.

Key

- ⊕ Ceiling bulk head light fitting
- ⚡ Light switch
- ⌂ Electrical control cupboard
- ⚡ Light automatic activation Device
- ⚡ Hand hot air dryers
- ⚡ Double 13 amp socket outlet
- ⚡ Thermostatically controlled electric wall heater
- ⚡ Disabled emergency alarm call point
- ⚡ Disabled emergency sounder
- ⚡ Extractor fan
- ⚡ Belfast Sink with hot & cold water
- ⚡ Free standing washing machine (single phase)
- ⚡ Form insitu concrete paving, with exposed aggregate finish

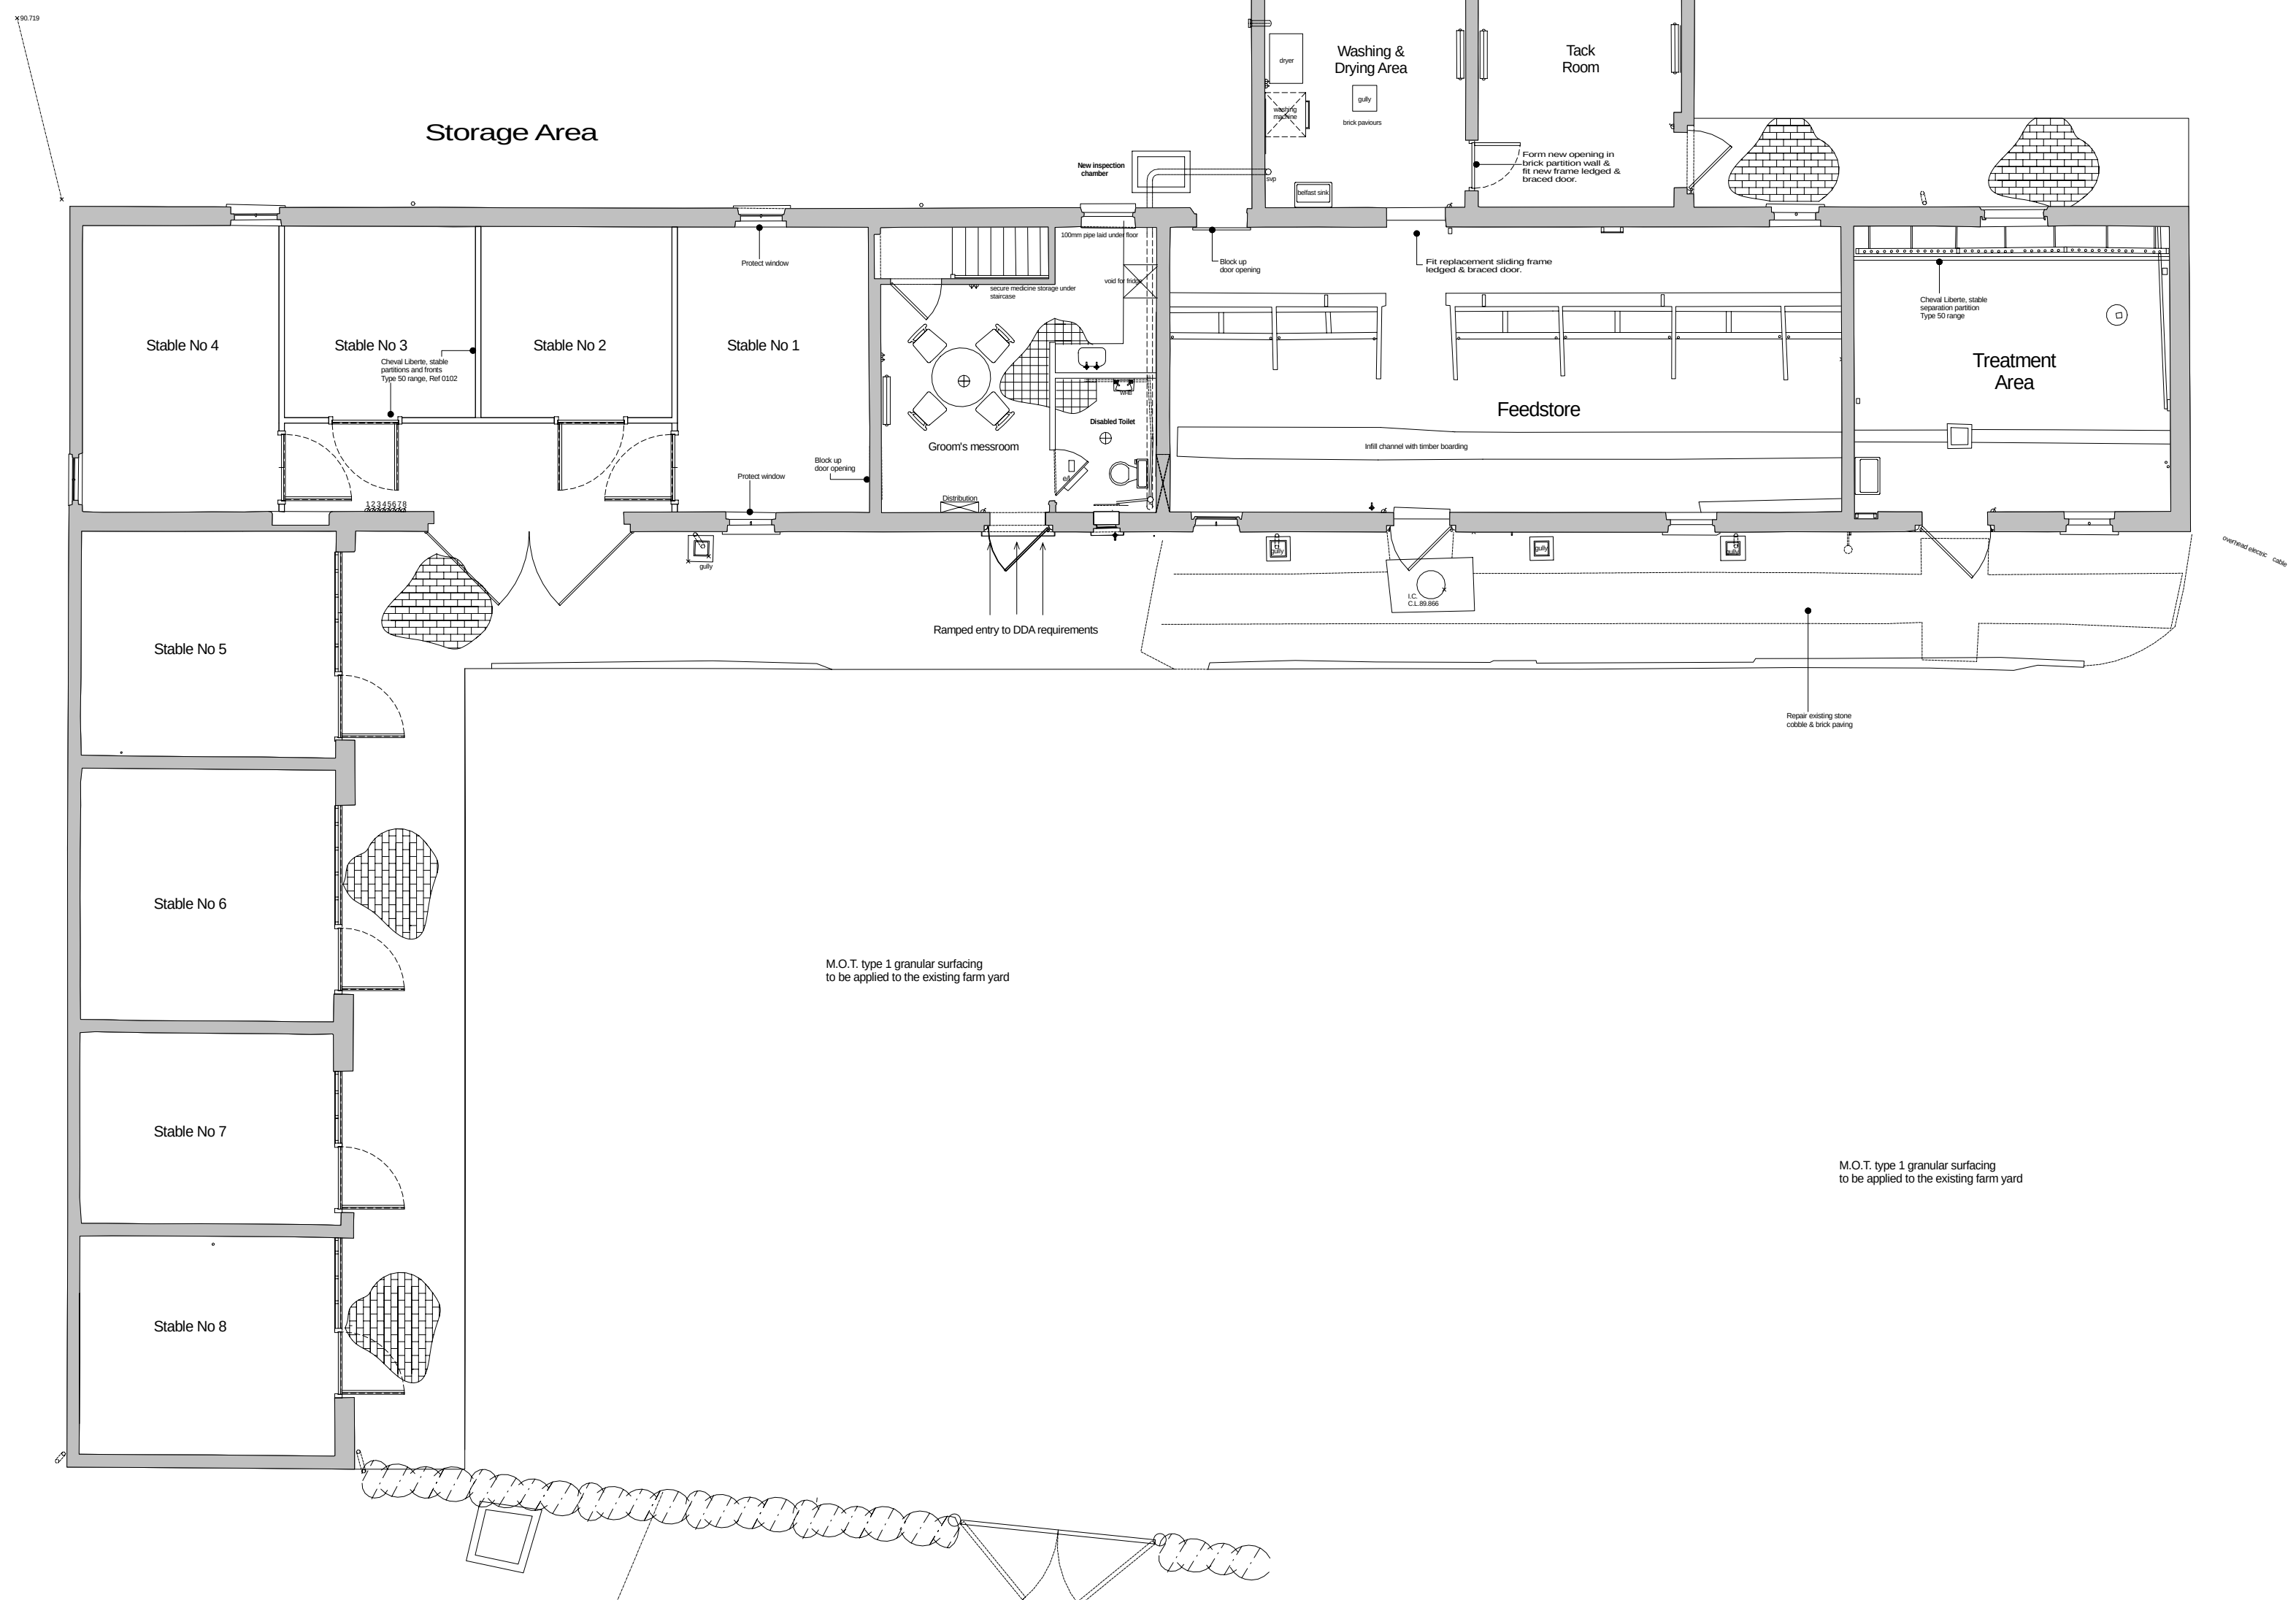

YR YMDDIRIEDOLAETH GENEDLAETHOL
THE NATIONAL TRUST

SWYDDFA CYMRU, LLANDUDNO
WALES OFFICE, LLANDUDNO
TRINITY SQUARE, LLANDUDNO, LL24 0HG
Ffon / Phone 01492 860123

DATE: Oct 2006	SCALE: 1:100	DRAWN: BEH
-------------------	-----------------	---------------

**As Proposed
Ground Floor Plan
Agricultural Building
Sontley Lodge Farm
Erddig, Wrexham**

DRWG. No. **ER05 - 0406**