


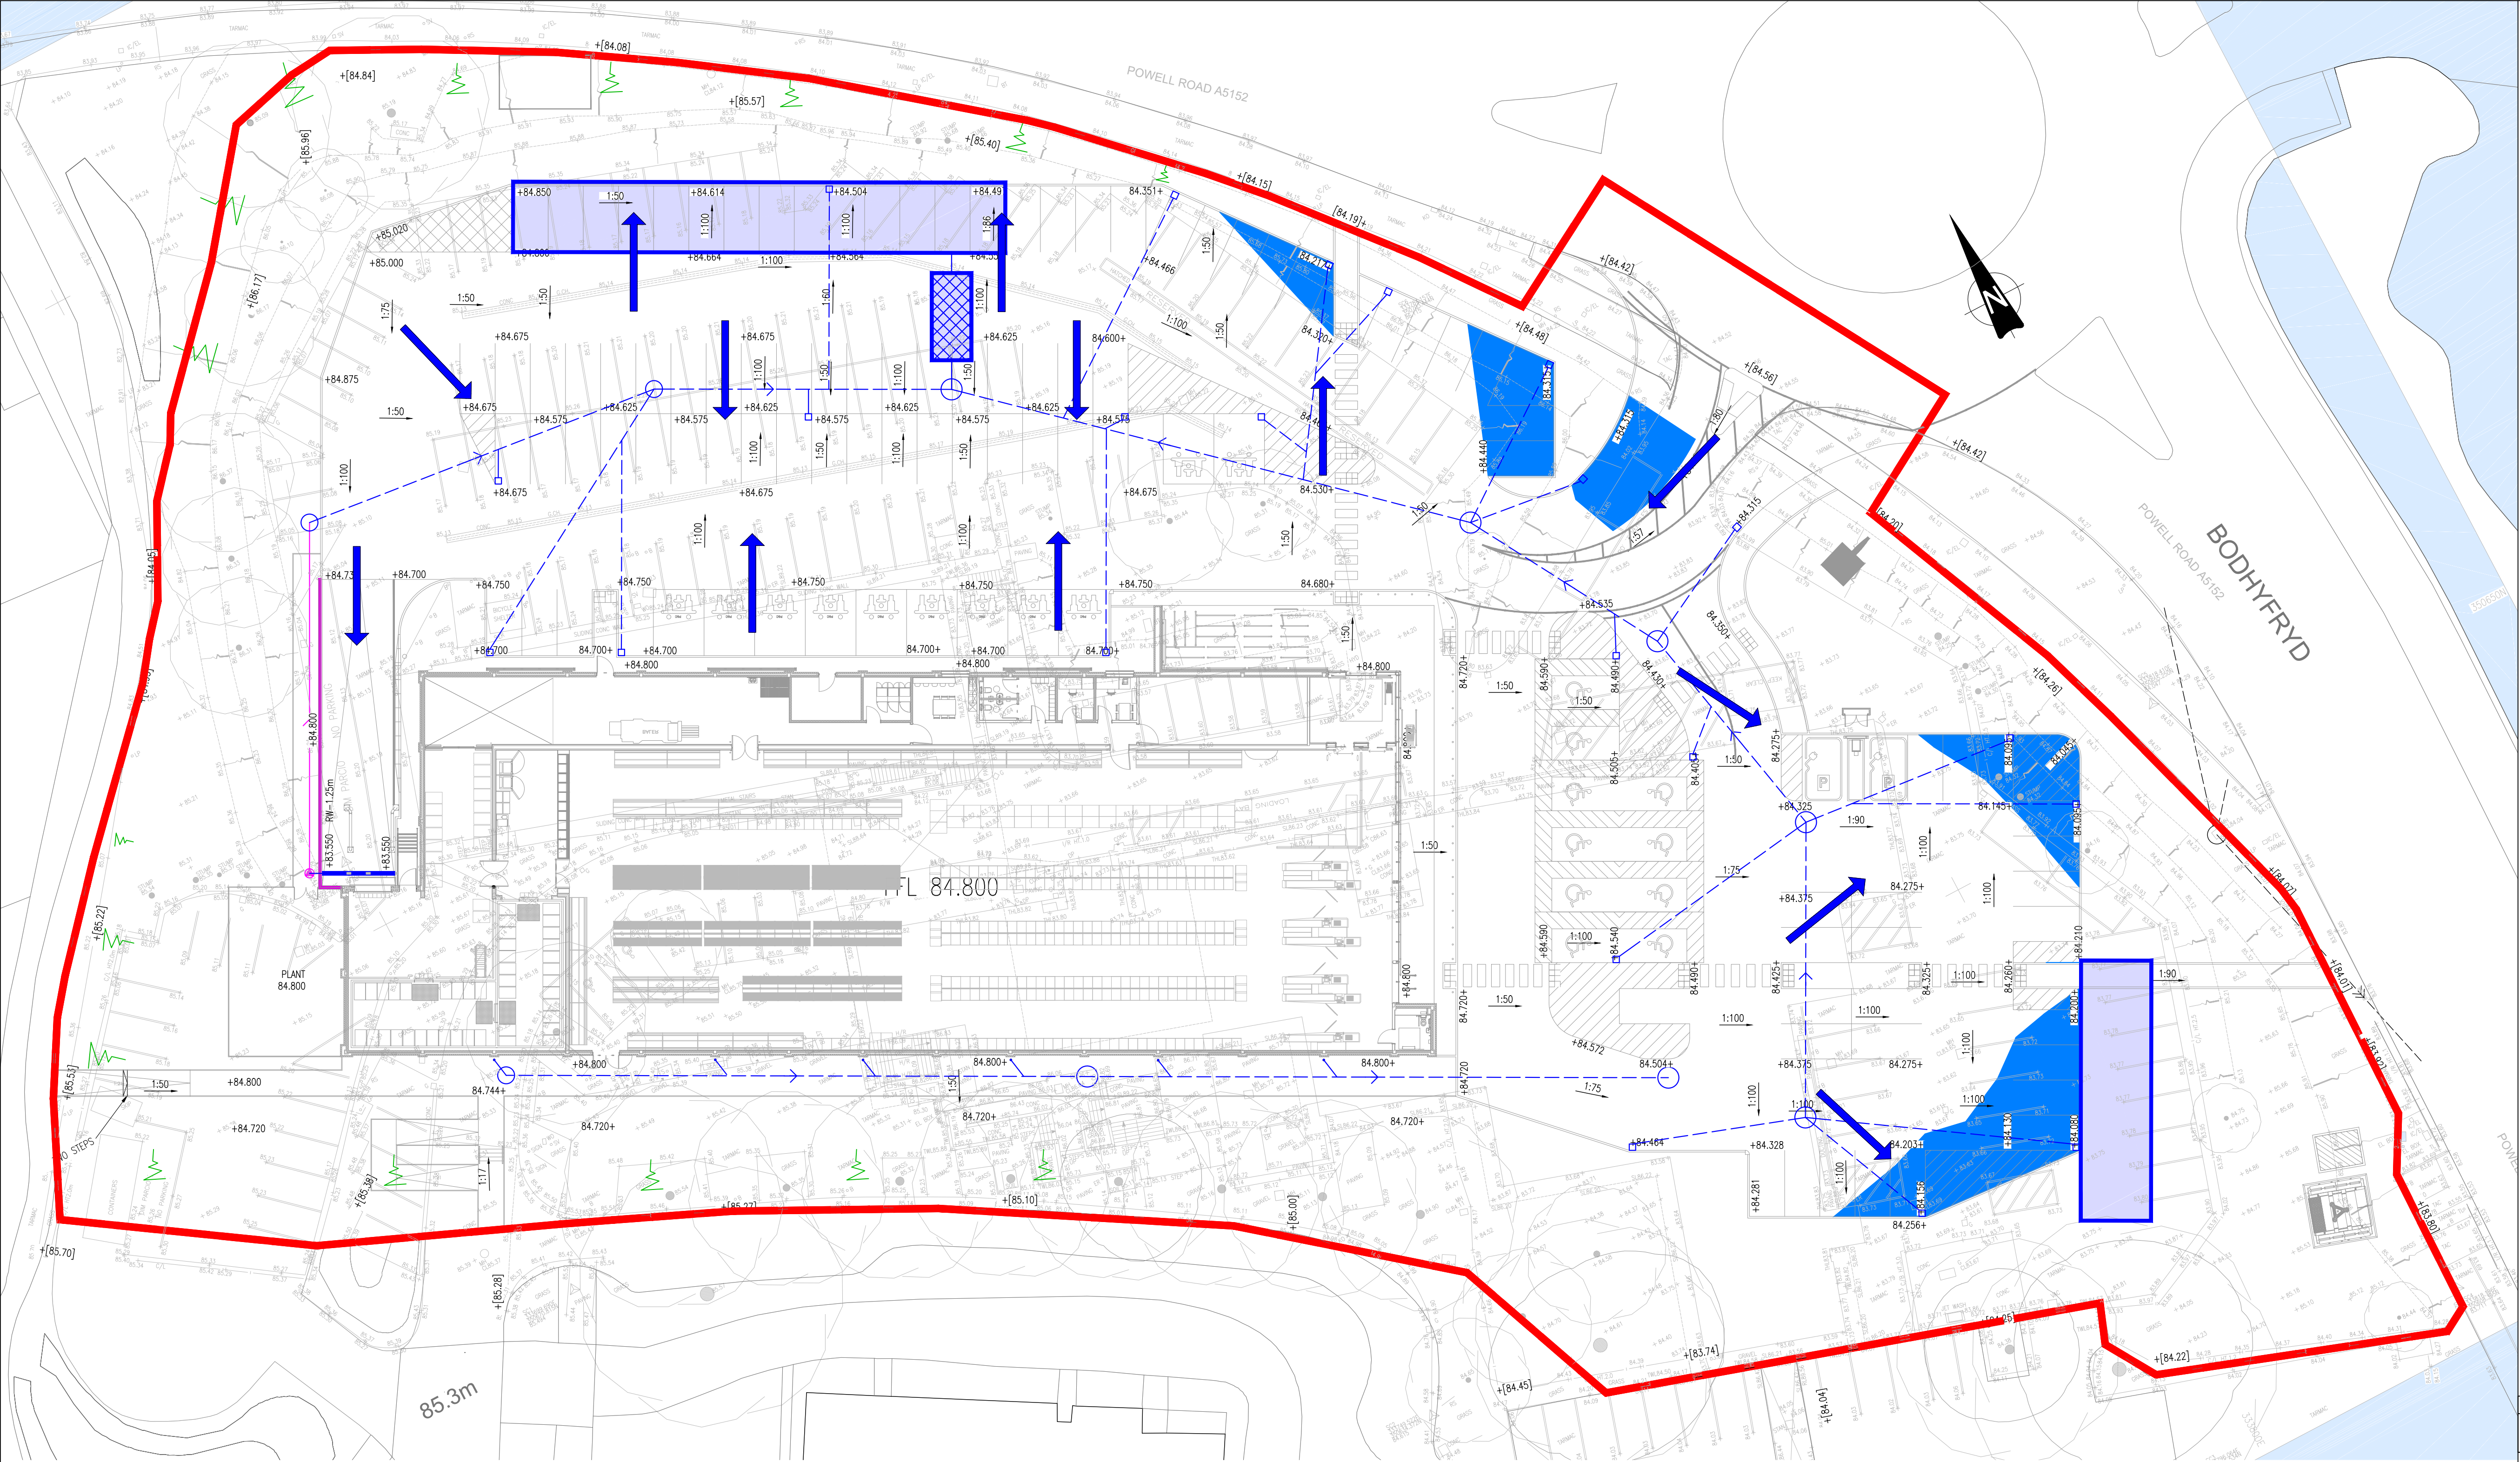

Flood Routing Plan
Scale 1:200

Key

- Direction of flow from MH Blockage
- Proposed Surface Water Drainage
- Water collection area

Site plan updated.	B	05/02/2021	KA	KGP
Existing topography & proposed levels added in-line with comments from Welsh Water.	A	27/01/2021	KA	KGP
DESCRIPTION	REV	DATE	CHK	APR

beamconsulting

Beam Consulting
14 Bond Street
Wakefield
WF1 2QP
Tel: 01924 361653
Fax: 01924 364631

PROJECT
**Lidl Store
Bodhydryd, Wrexham**

DRAWING TITLE
Flood Routing Plan

CLIENT
Lidl GmbH UK

STATUS
Information

DRAWN	JG	DATE	02/07/2020
CHECKED	KA	SCALE	AS SHOWN @ A1
APPROVED	KGP		
DRAWING NUMBER	09-124-512	REVISION	B