


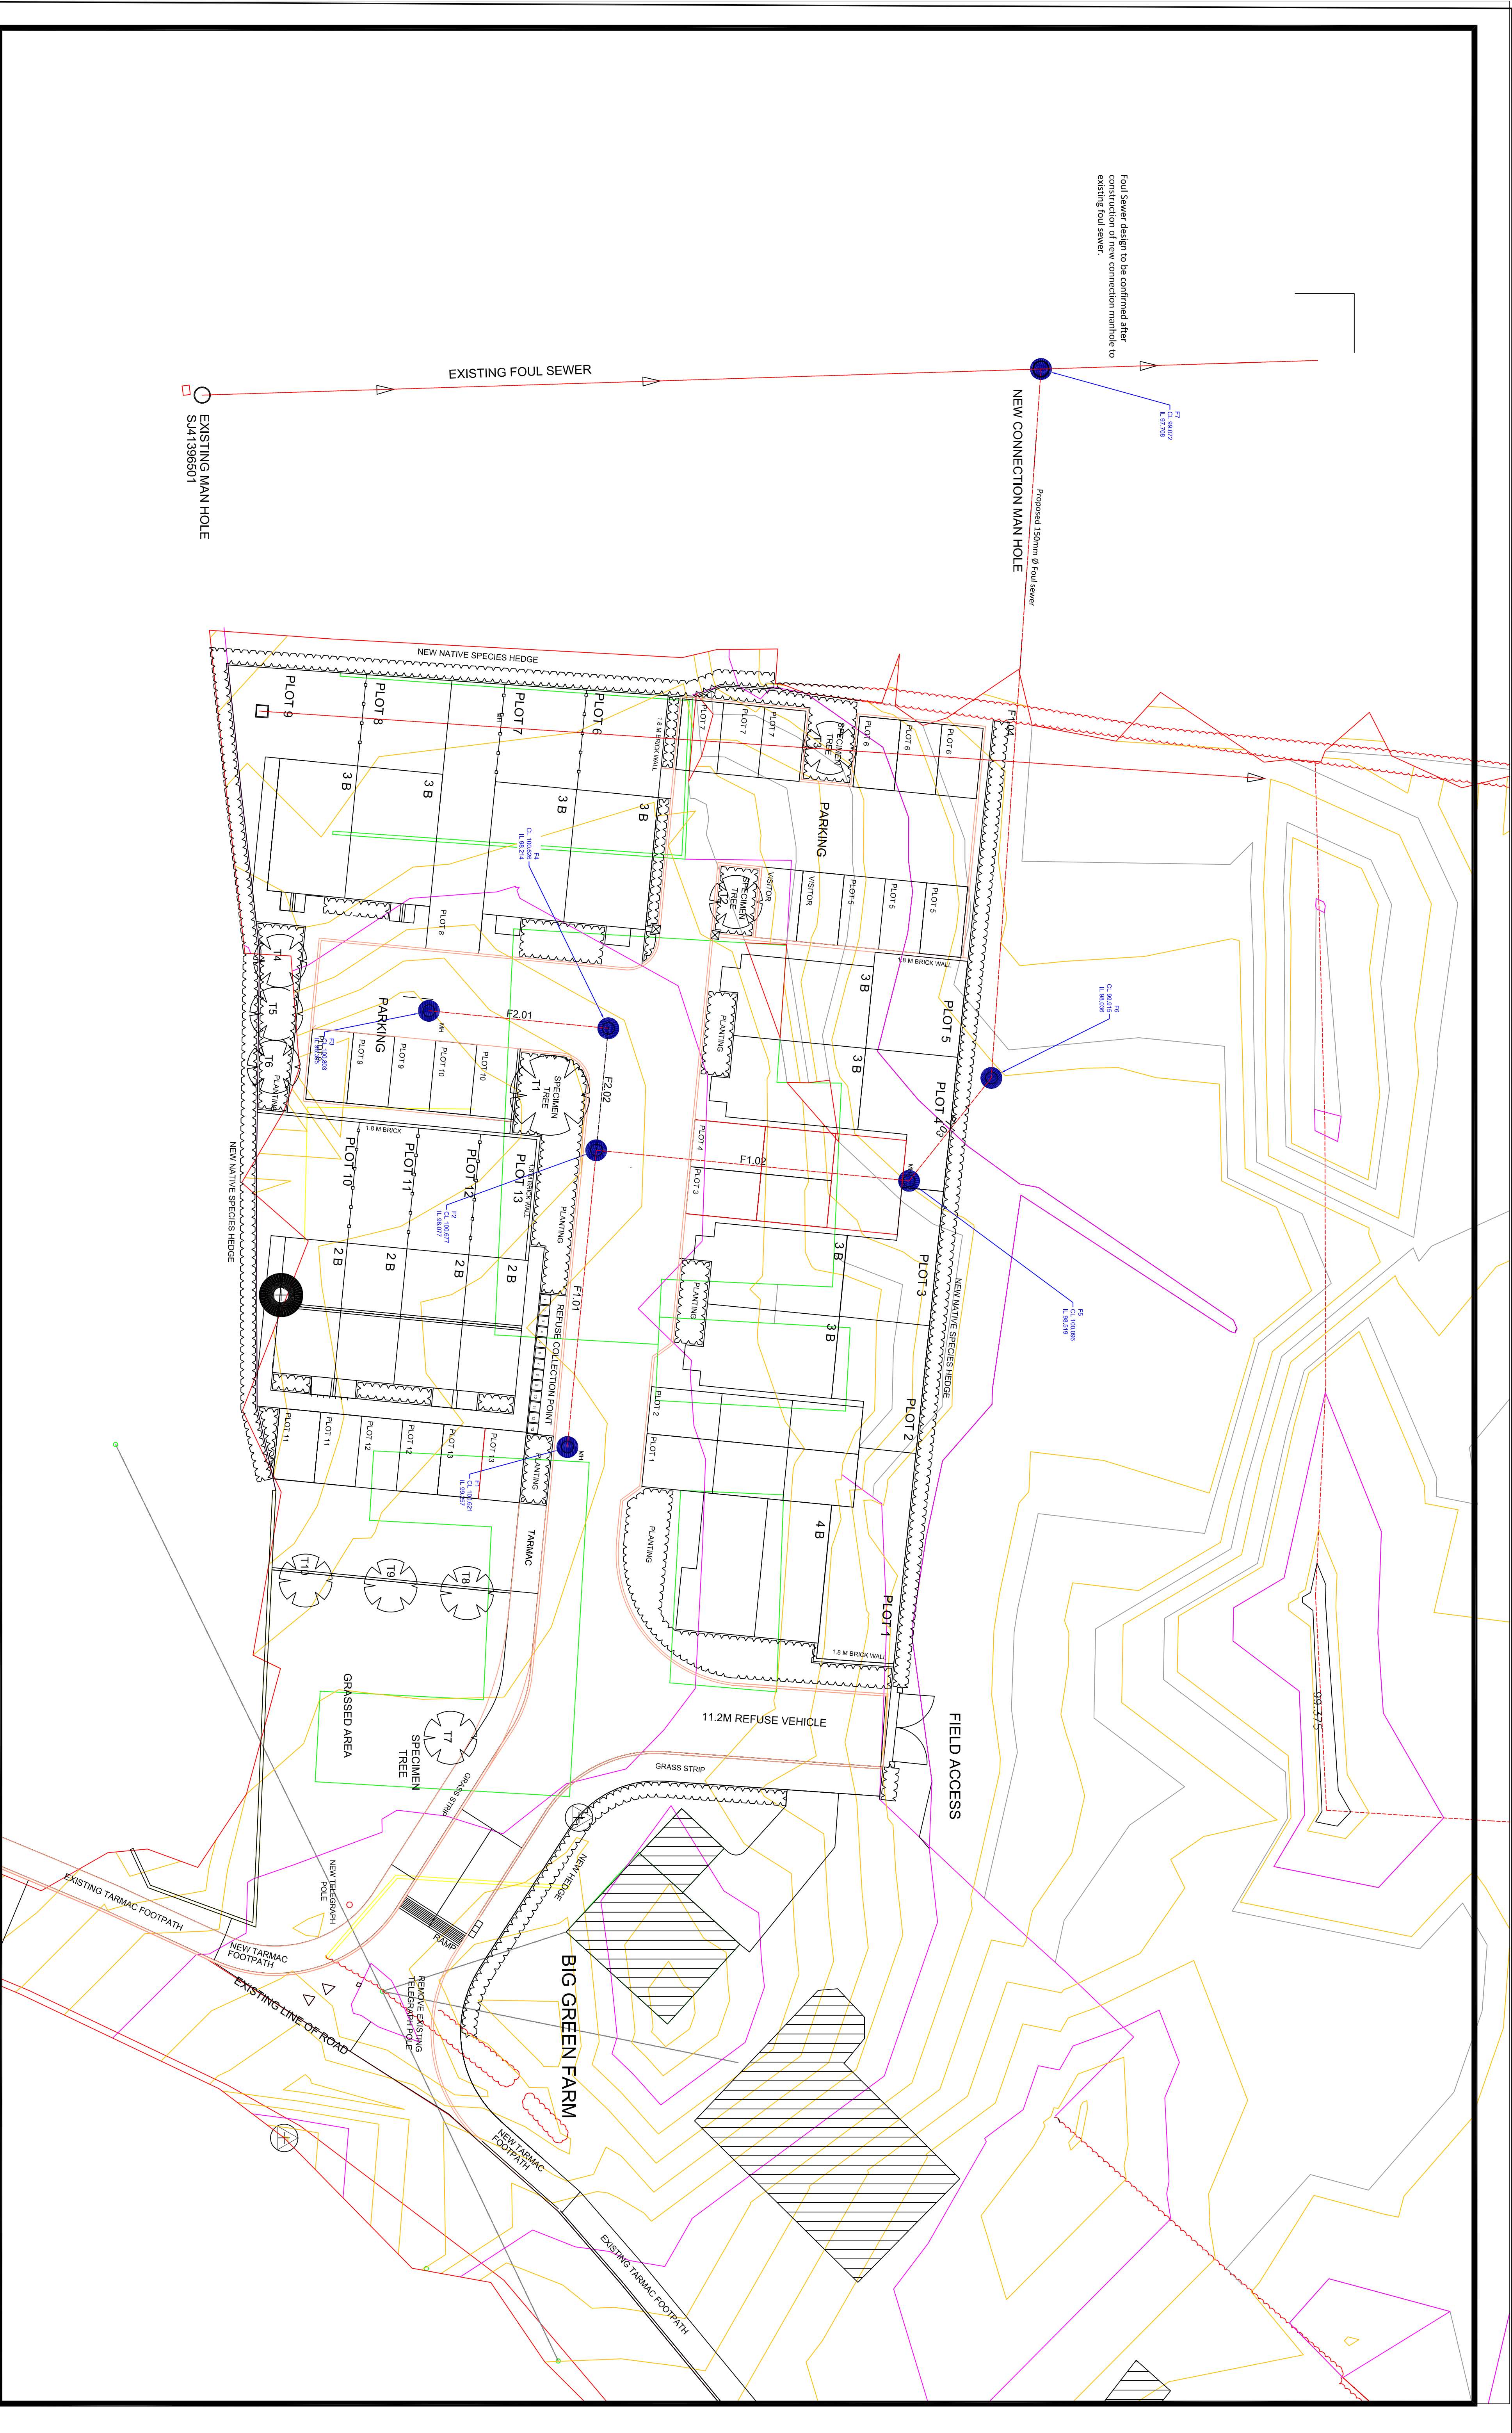

Foul Sewer design to be confirmed after construction of new connection manhole to existing foul sewer.

NEW CONNECTION MAN HOLE

Proposed 150mm Ø foul sewer

EXISTING FOUL SEWER

EXISTING MAN HOLE
SM41386501

REVISIONS

DATE	DESCRIPTION	REV	CHKD	APPRO
14-02-2020	ISSUED FOR COMMENTS	A		

Client :



Projects :
**PROPOSED 13 DWELLINGS AT BIG GREEN FARM
PENLEY**

Title :

**BIG GREEN FARM DEVELOPMENT
PENLEY
DRAINAGE LAYOUT**

Engineering Consultant :



Scale @ A1:

1:200

DATE :-

02/11/2020

Drawn By :-

SB

Checked :-

KB

Approved :-

KB

Rev:

RED-ERL-001 / PL-01

A