




100mm

 
50mm

10mm

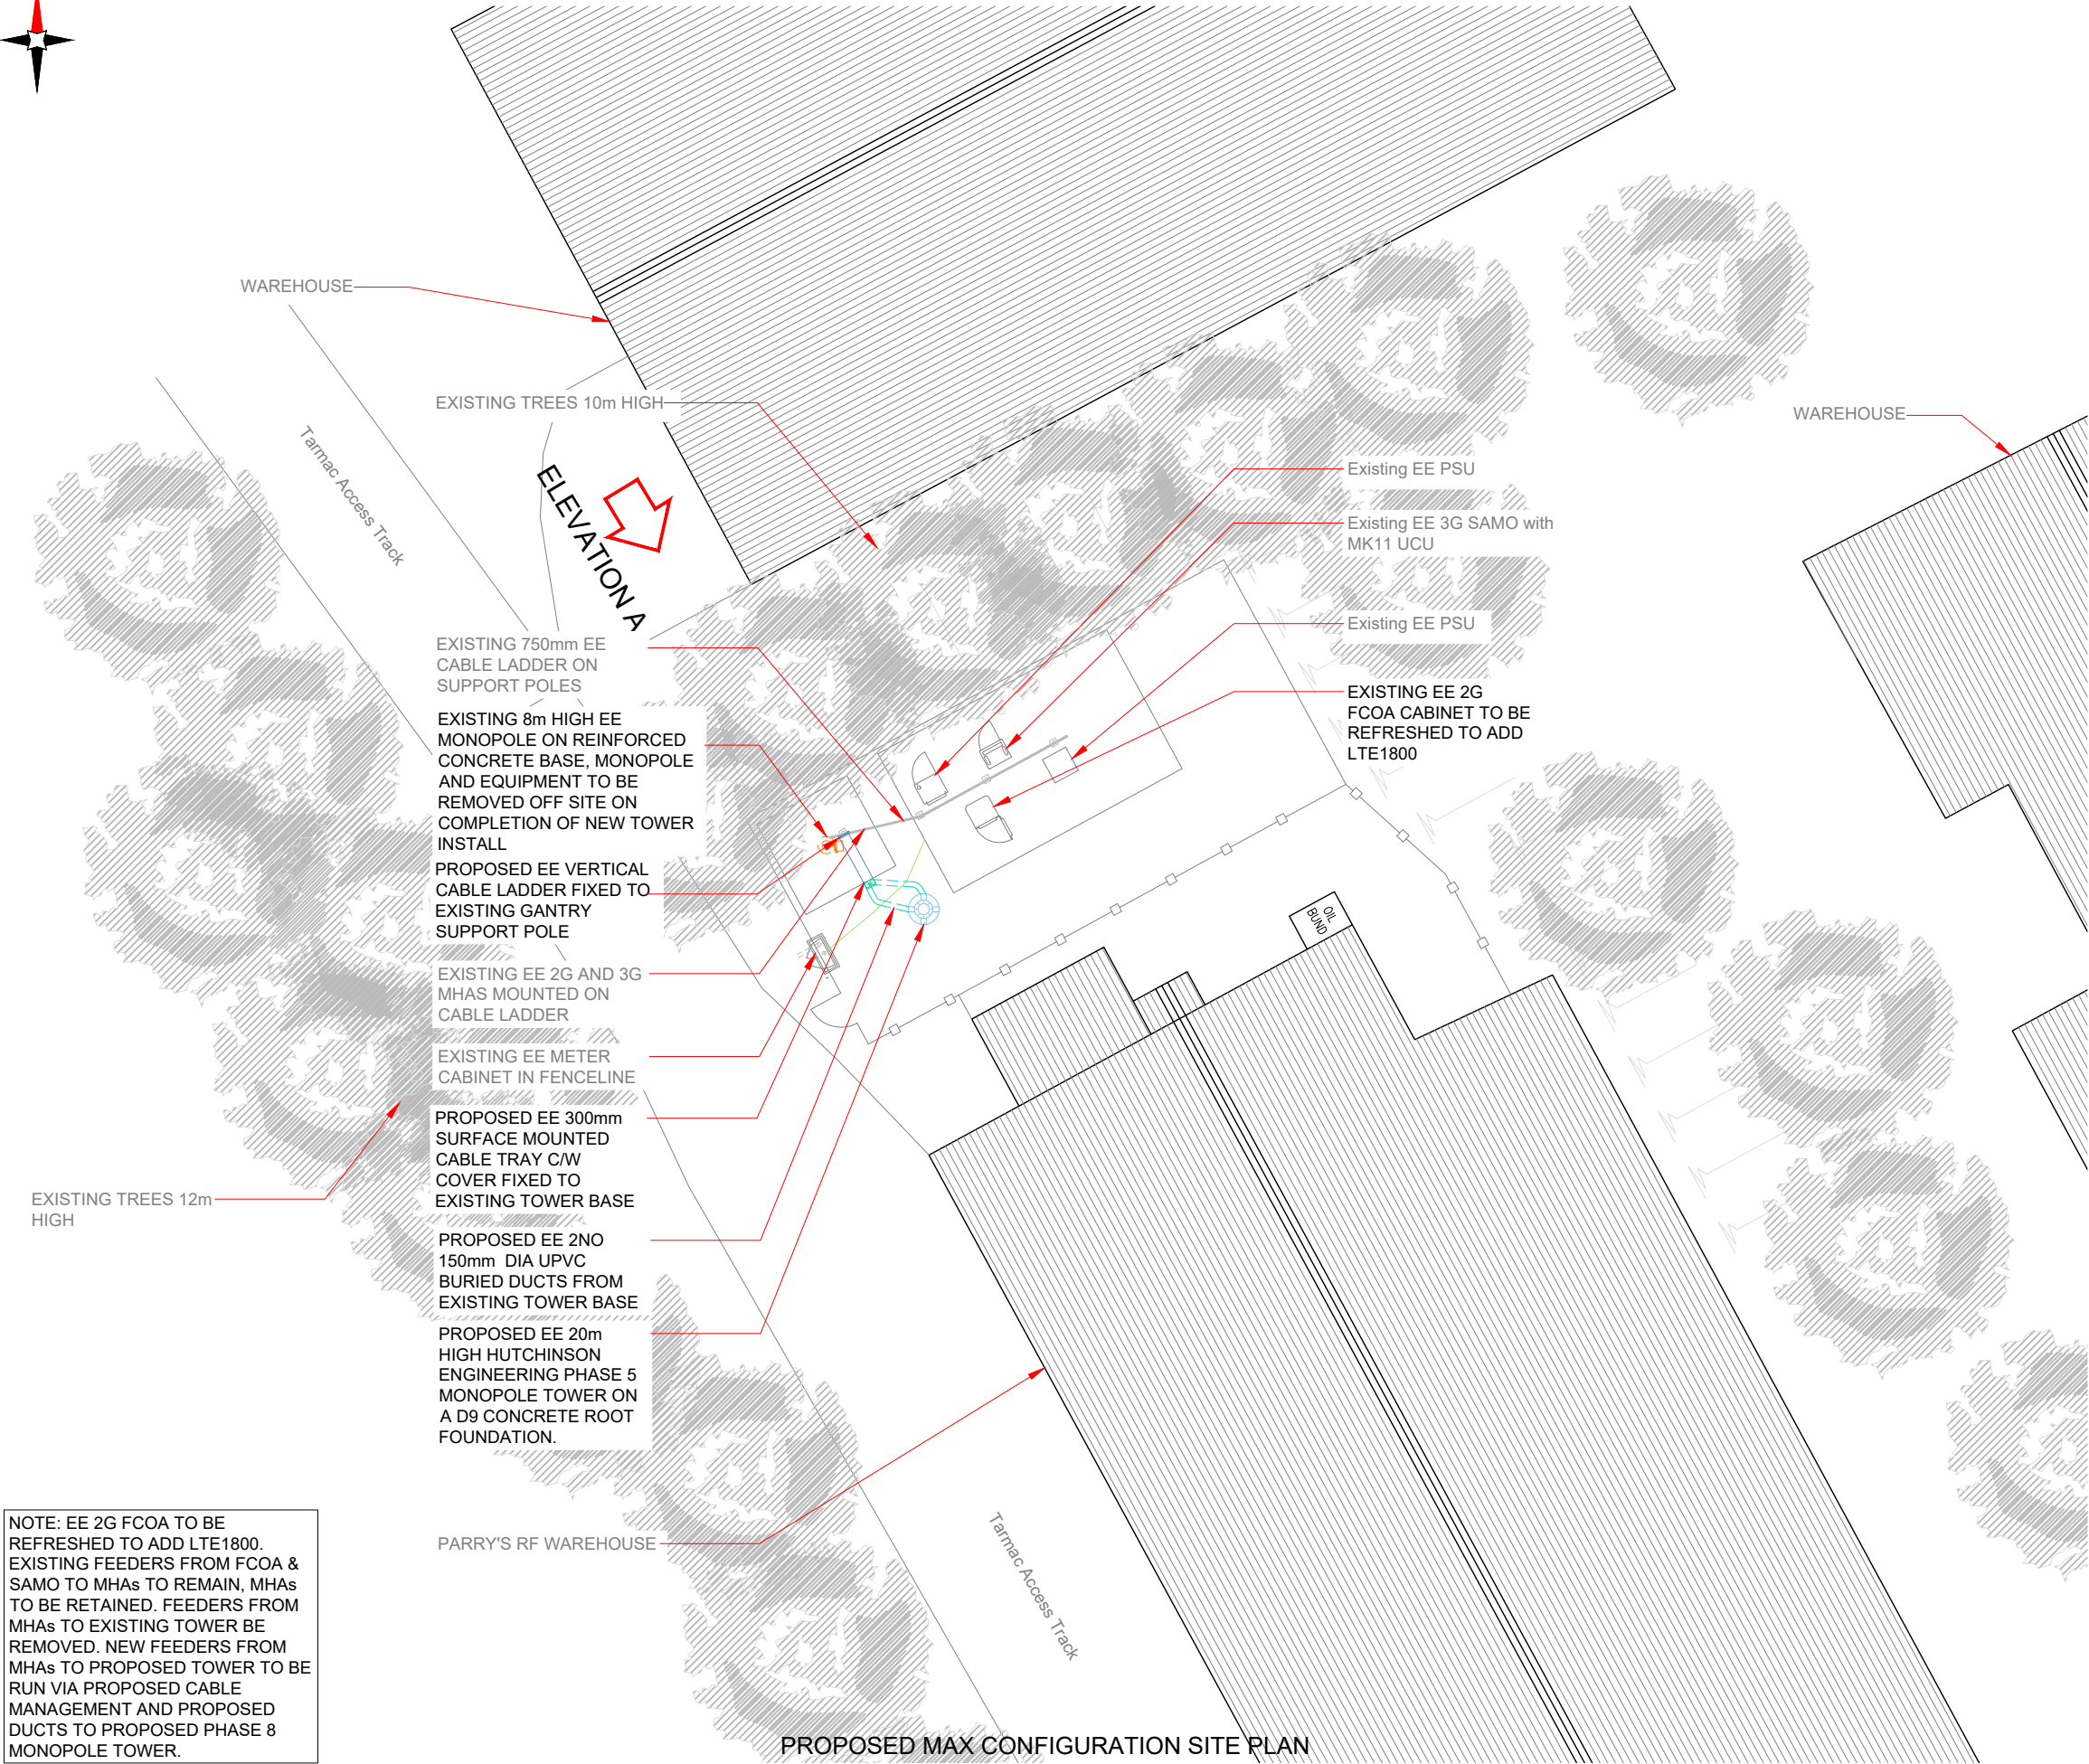

NOTE: EE 2G FCOA TO BE REFRESHED TO ADD LTE1800. EXISTING FEEDERS FROM FCOA & SAMO TO MHAs TO REMAIN, MHAs TO BE RETAINED. FEEDERS FROM MHAs TO EXISTING TOWER BE REMOVED. NEW FEEDERS FROM MHAs TO PROPOSED TOWER TO BE RUN VIA PROPOSED CABLE MANAGEMENT AND PROPOSED DUCTS TO PROPOSED PHASE 8 MONOPOLE TOWER.

PROPOSED MAX CONFIGURATION SITE PLAN



- NOTES:
- ALL DIMENSIONS IN MM UNLESS OTHERWISE NOTED.

Master:	MBNL / EE / H3G:	Project:	Purpose of Issue:	Issue:
M001	MBNL	NTQ	Planning	A
Date:	20/11/2020	Revision / Upgrade Description:		
Drawn:	J Wardlaw	First Issue - Site nomination dated: 11805_(2020-11-03)_R2		
Checked:	J. Wardlaw			
Approved:	J. Ladd			



Hatfield Business Park
Hatfield
Hertfordshire
AL10 9BW

Tel: 01707 315000
Fax: 01707 319001



HARLEQUIN GROUP
INNOVATION CENTRE
MAIDSTONE ROAD
CHATHAM
KENT, ME5 9FD
TEL: +44 (0) 1634 683635

HARLEQUIN GROUP
RUTLAND HOUSE
5 ALLEN ROAD
LIVINGSTON
WEST LOTHIAN, EH54 6TQ
TEL: +44 (0) 1506 462174

Site Name:
PARRYS RF WAREHOUSE

Site ID:
1198026

Address:
PARRYS RF WAREHOUSE
MOULD ROAD TRADING ESTATE
GWERSYLLT, NR WREXHAM
WREXHAM
CONWY, LL11 4AQ

Title:
215 MAX CONFIGURATION SITE PLAN

Project:
EE NTQ

Purpose of Issue:
PLANNING

EE Cell ID: 11805	MBNL Cell ID: WRX030	3UK Cell ID: LL0353
----------------------	-------------------------	------------------------

Master Drawing No: 1198026_WRX030_11805_LL0353__M001	Issue: A
---	-------------