



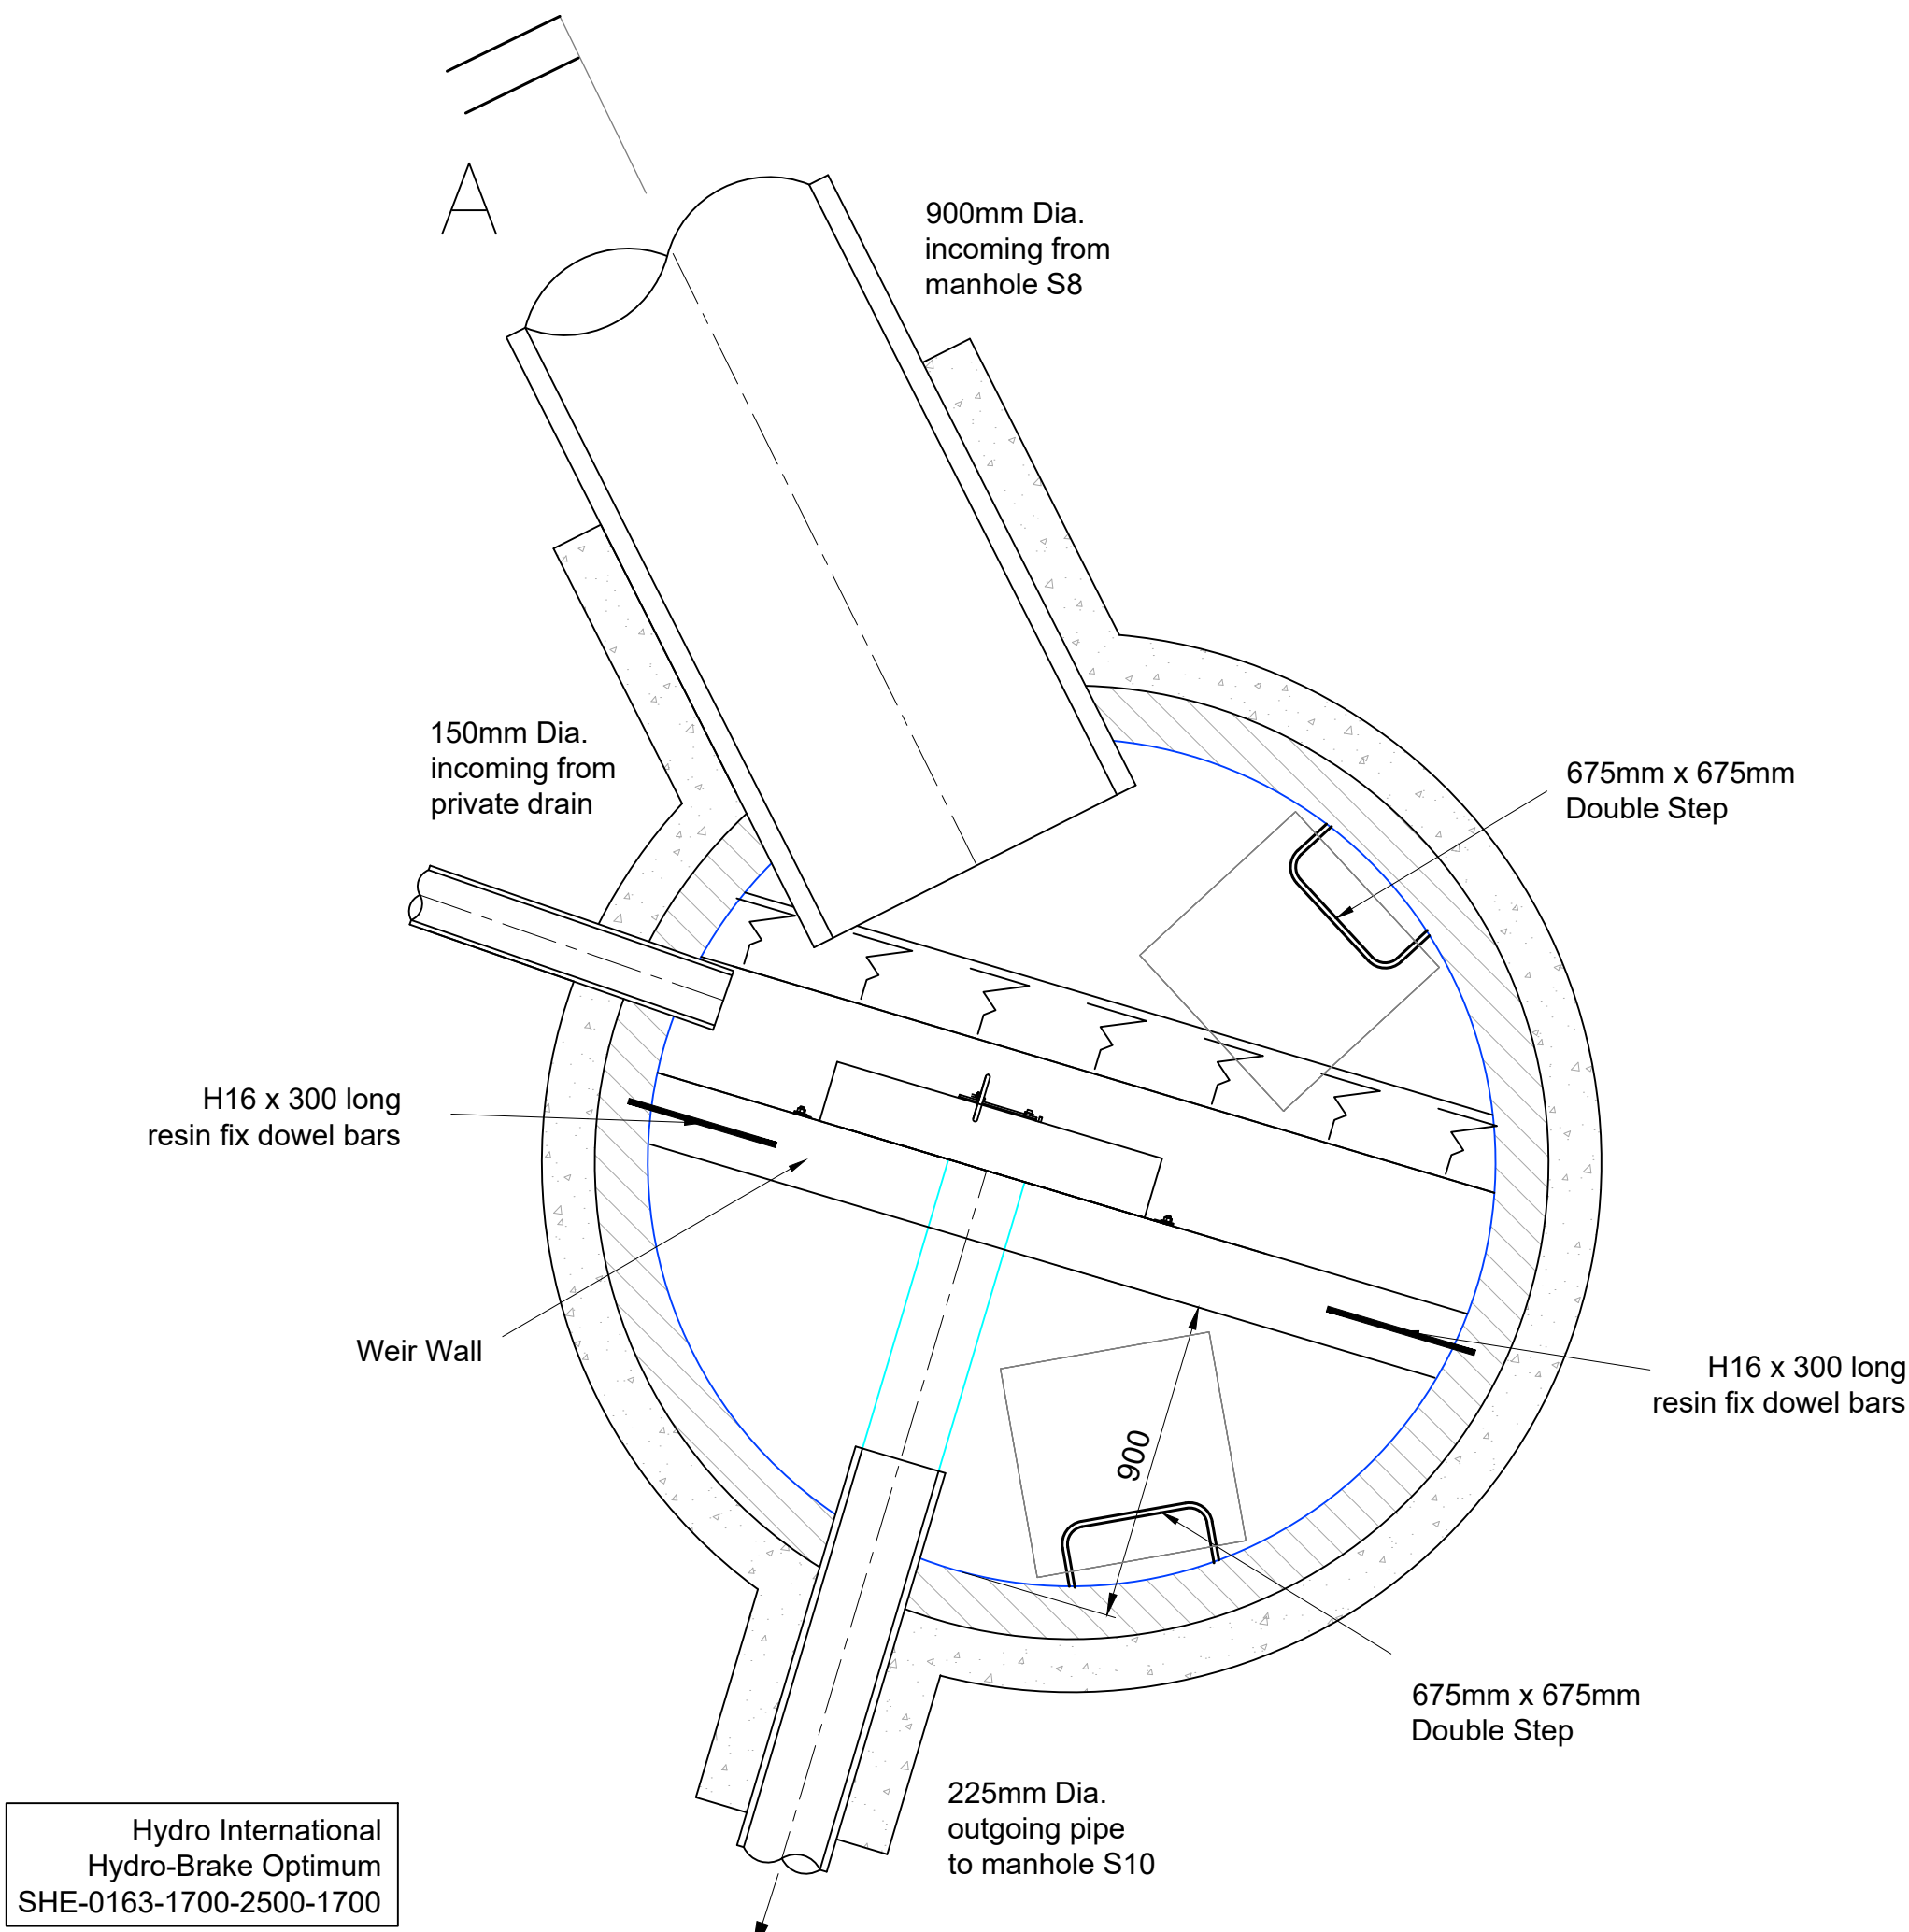

MH Diameter	2400mm
MH Type	Flow Control
Depth to Soffit	3.413 (150Ø)
Depth to Cut-Out Recess (SW storage MHs only)	N/A
Cover Size	675 x 675mm
Cover Depth	150mm
Cover Spec.	D400
Ladder or Double Steps?	Double step
Safety Chain	No
Safety Rails	No
Invert Access Steps	No
Hole Size in Cover Slab	675 x 675mm

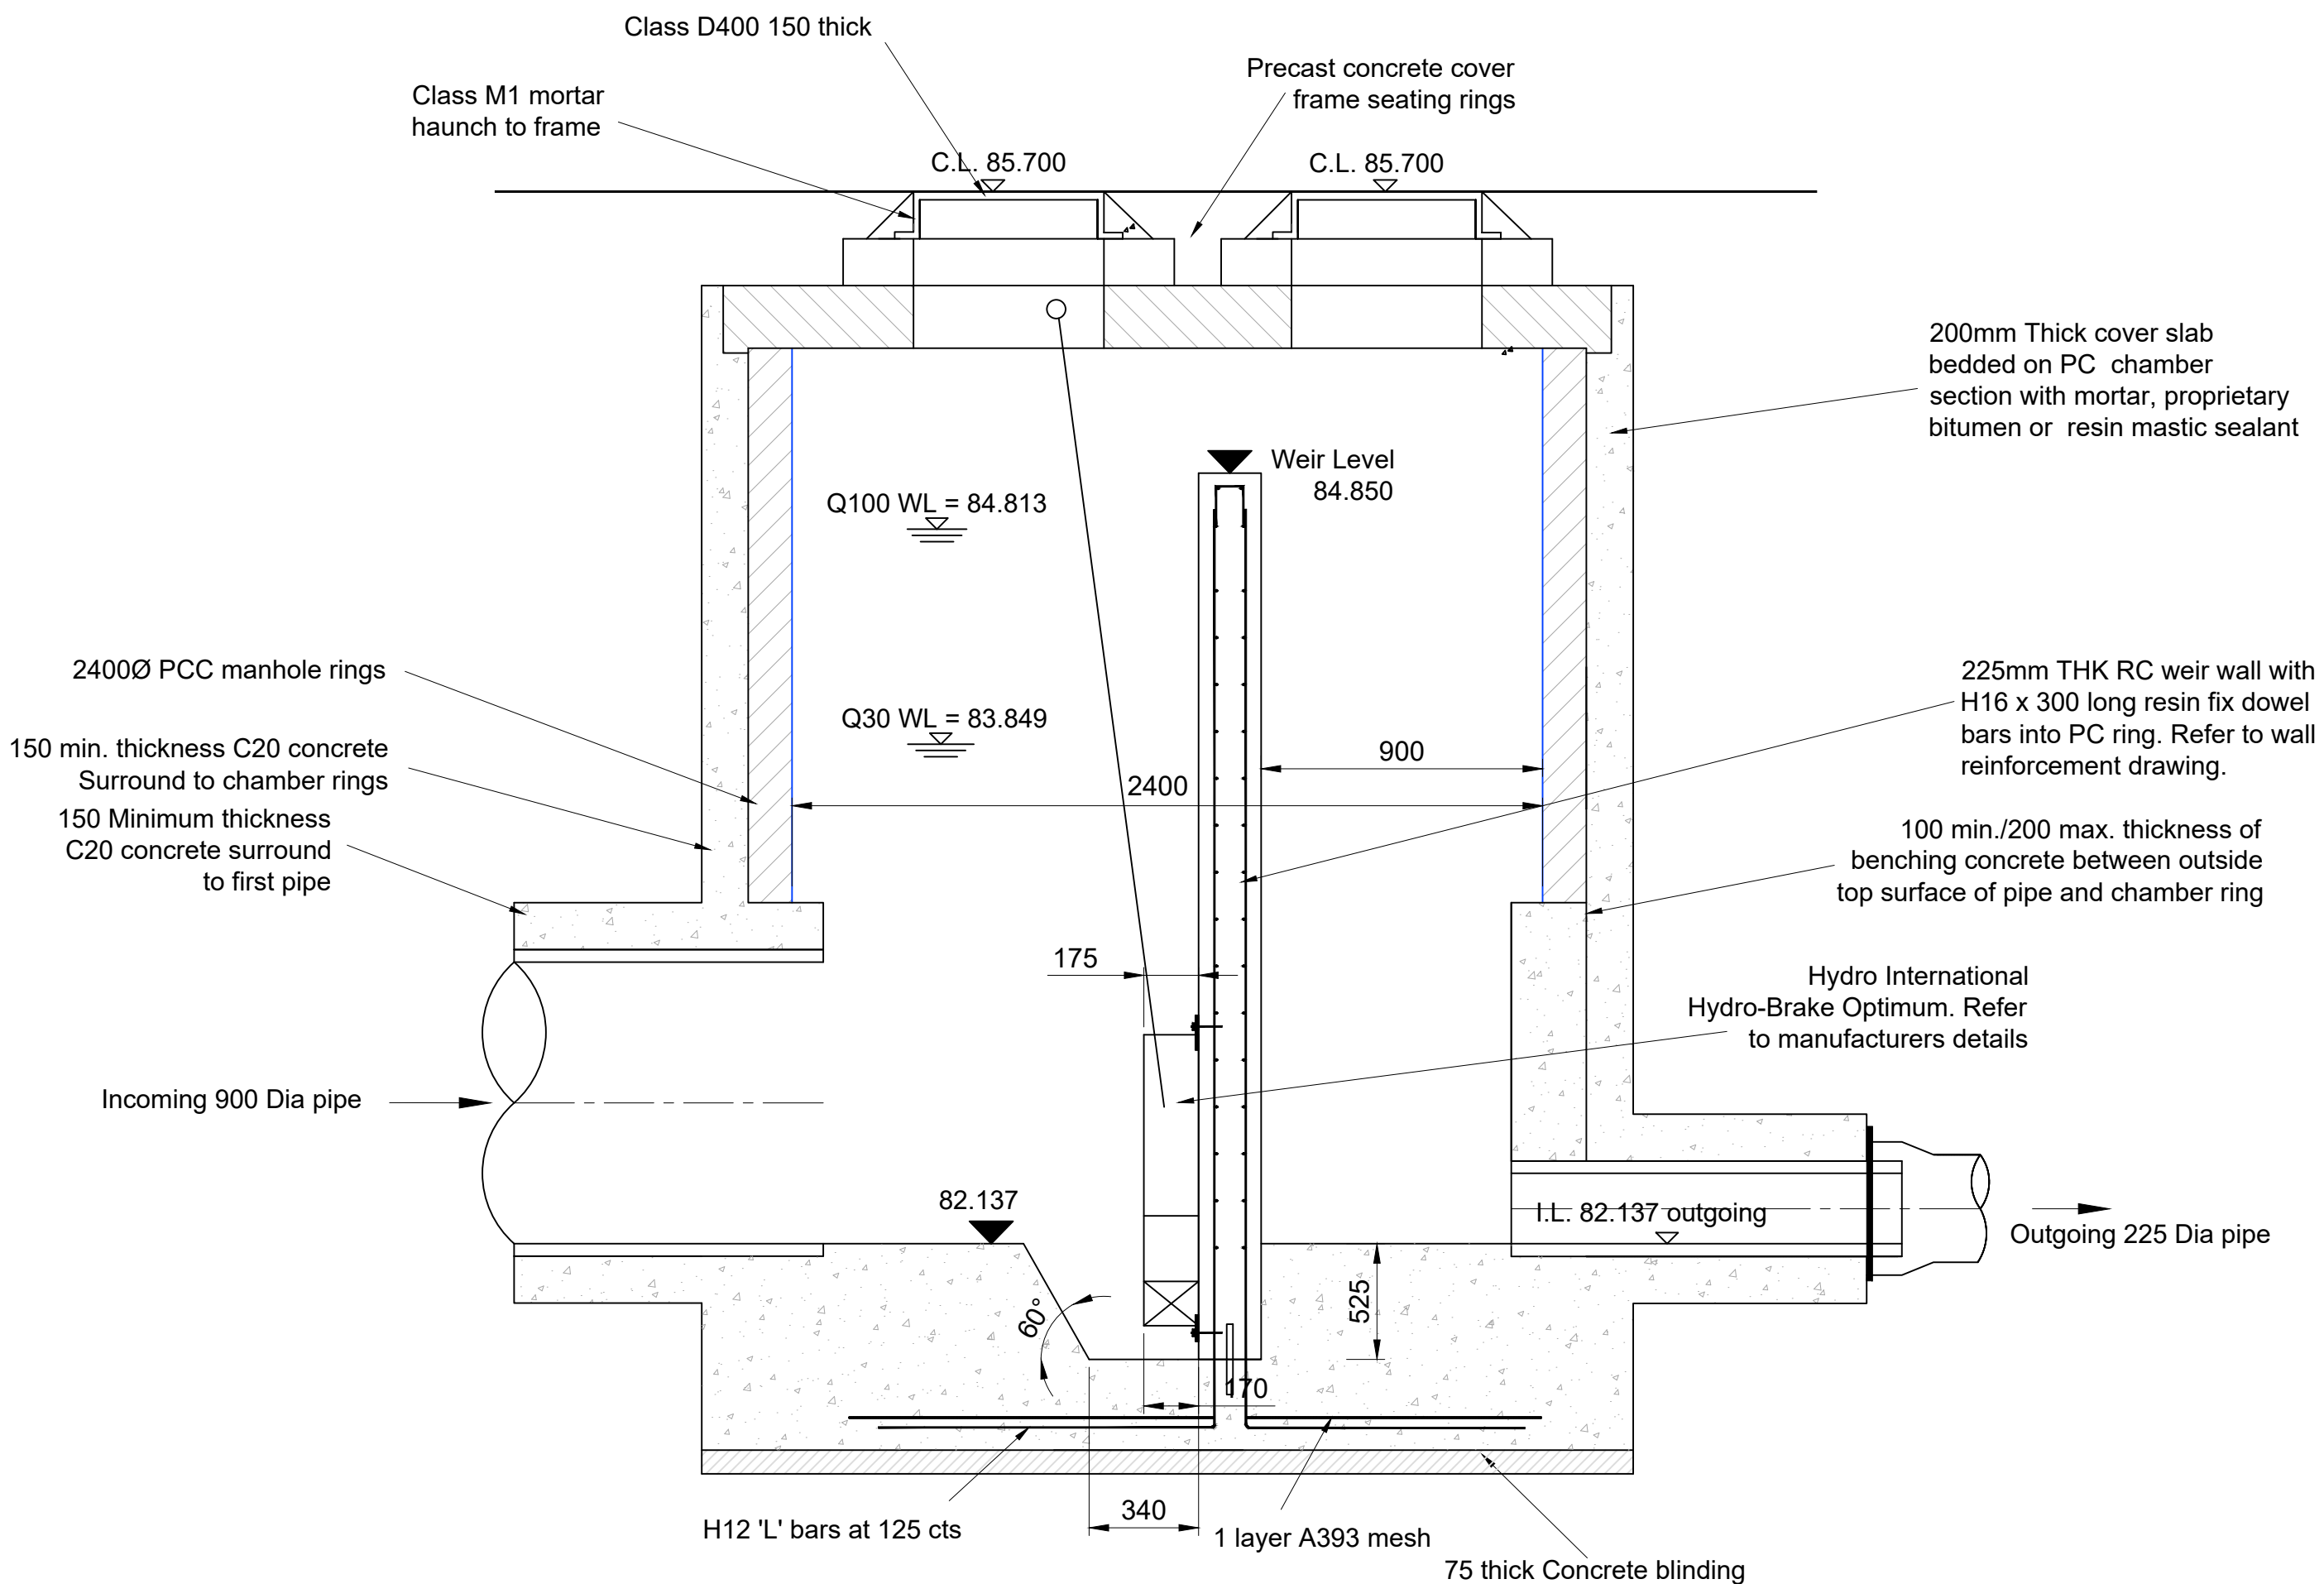

TYPICAL SECTION
Scale 1:20

Notes

- All dimensions are in millimetres unless otherwise shown.
- All adoptable drainage shall be constructed in accordance with 'Sewers for Adoption' 7th Edition, Welsh Ministers Standards and Welsh Water Details and Guidelines.
- All existing invert levels to be checked by the contractor at the start of works and any other discrepancies notified to the Engineer, prior to commencing works. All levels are based on topographical survey information provided by others.
- It is the responsibility of the Contractor to verify all information given with regards to existing services and drainage connections etc. prior to commencing the works.
- The Contractor shall adhere to the CDM Regulations at all times.
- Only trained personnel shall be permitted to enter confined spaces.
- All materials to bear the relevant B.S. Kitemark and comply fully with the Sewers for Adoption 7th Specification. All concrete & concrete products must use Sulphate resistant cement (unless the site investigation report proves that sulphate attack from soils and groundwater will not occur to withstand a class 3 condition).
- All opening notices etc. as required under Highways Acts etc. are to be obtained prior to commencement of works. All works are to be inspected by L.A., NHBC or Welsh Water as applicable.

DRAWING LIST

7387 / 01	Proposed Drainage Layout
7387 / 02	Highway Layout & Setting Out
7387 / 03	Drainage Construction Details
7387 / 04	Highway Construction Details
7387 / 05	External Works Layout
7387 / 06	Highway & Drainage Longsections
7387 / 07	S38 Agreement Plan
7387 / 08	Manhole Schedule
7387 / 09	Plot Manhole Schedules
7387 / 10	Surface Water Catchment Areas
7387 / 11	Flow Control Details
7387 / 12	Manhole Connection Plan

APPROVAL

A	02.04.20	Updated to suit revised site levels	By	Appd.
Rev.	Date	Revision	By	Appd.

coopers
chartered consulting engineers

Tel: 01244 684910
Fax: 01244 684911
Email: admin@coopers.co.uk
Web: http://coopers.co.uk

Park House
Sandpiper Court
Chester Business Park
Chester
CH4 9QU

Client	CASTLEMEAD GROUP LTD.		
Project	JACQUES WAY, WREXHAM		
Title	Flow Control Detail (S9)		
DRAWING NUMBER	7387 - 11		
SCALE at A1	1:20	REVISION	A
DATE	DEC 19	DRAWN	LW
CHECKED	AJ		