


DO NOT SCALE

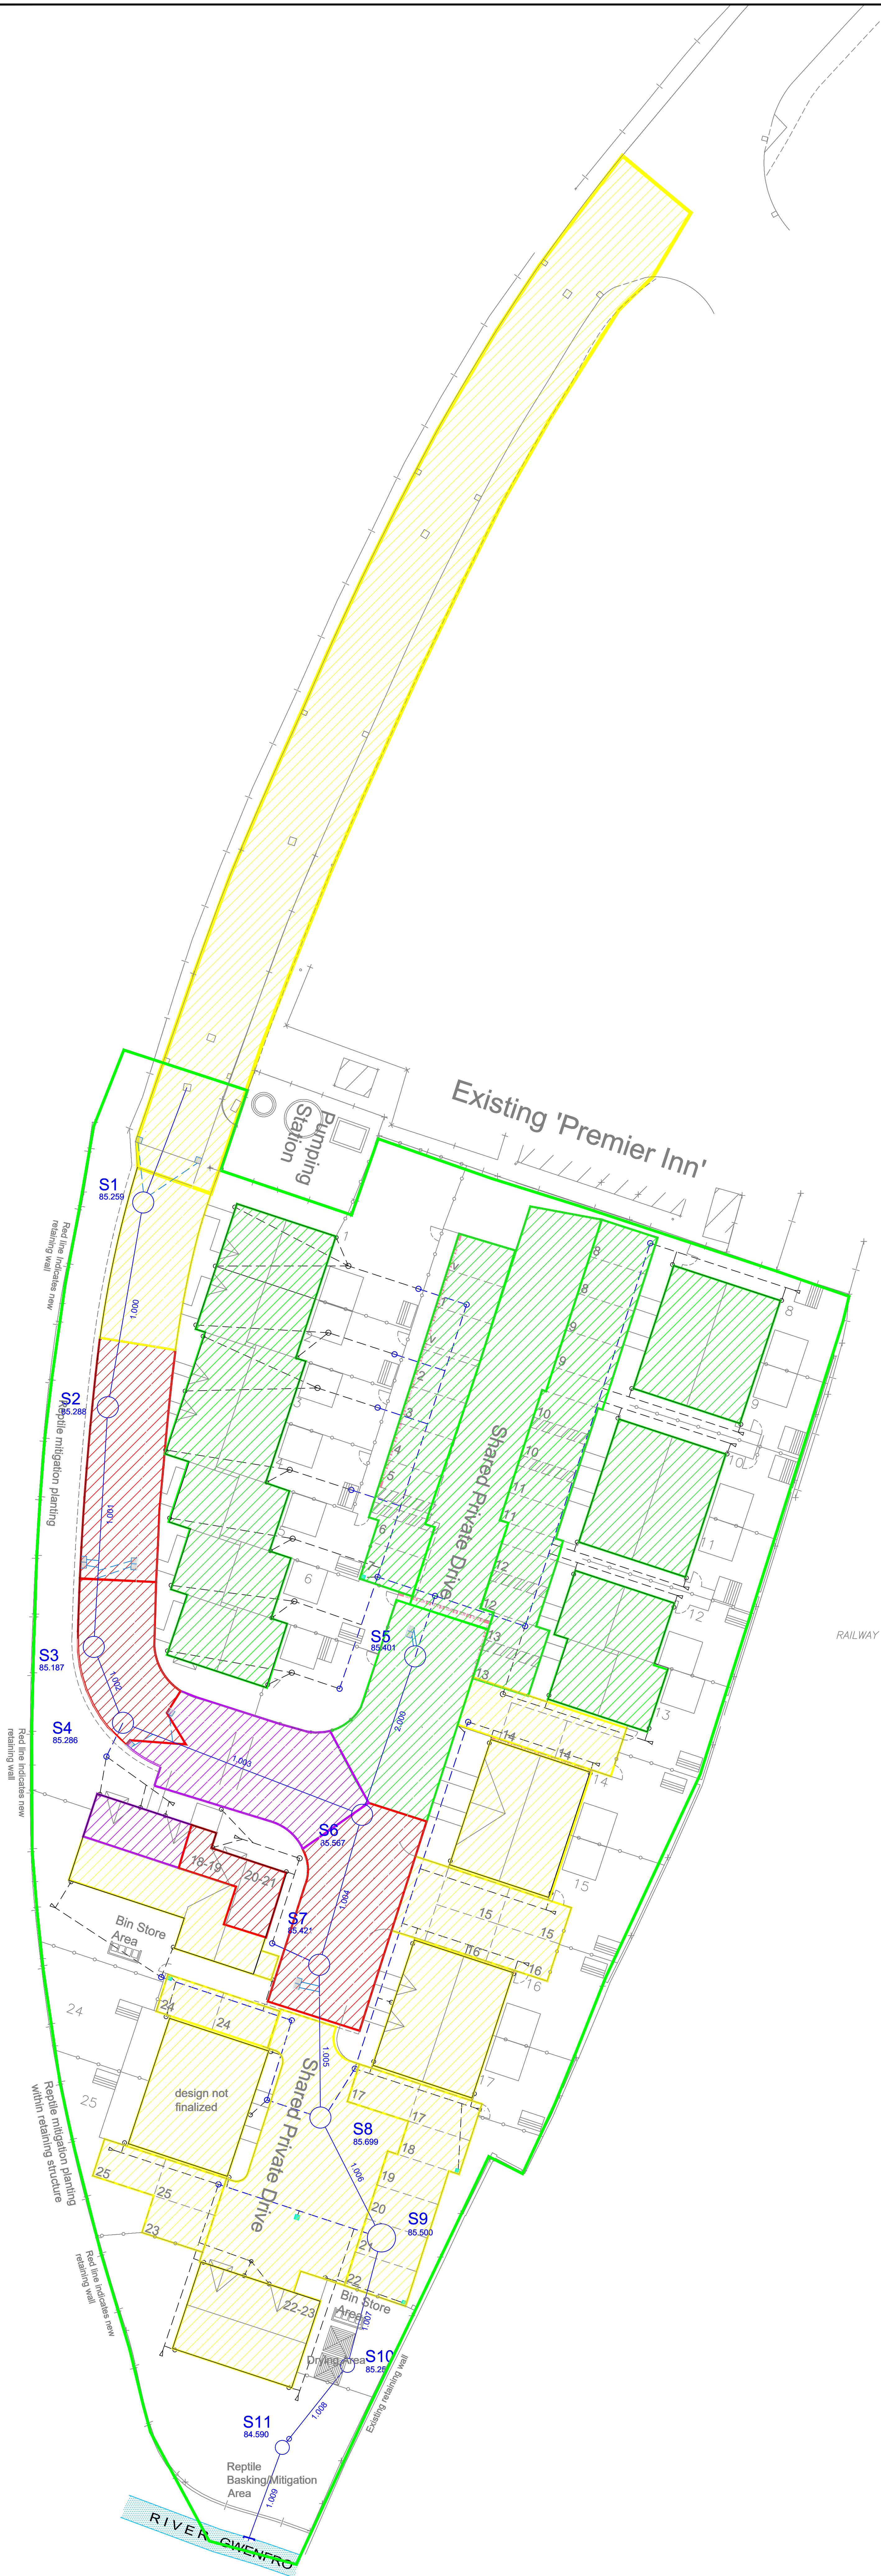

PIPE REF:	U/S MH REF:	IMPERMEABLE AREA
1.000	S1	830
1.001	S2	220
1.002	S3	-
1.003	S4	170
2.000	S5	1370
1.004	S6	-
1.005	S7	190
1.006	S8	1040
1.007	S9	-
1.008	S10	-
TOTAL AREA		= 3820m²

DRAWING LIST			
7387 / 01	Proposed Drainage Layout		
7387 / 02	Highway Layout & Setting Out		
7387 / 03	Drainage Construction Details		
7387 / 04	Highway Construction Details		
7387 / 05	External Works Layout		
7387 / 06	Highway & Drainage Longsections		
7387 / 07	S38 Agreement Plan		
7387 / 08	Manhole Schedule		
7387 / 09	Proposed Manhole Schedules		
7387 / 10	Surface Water Catchment Areas		
7387 / 11	Flow Control Details		
7387 / 12	Manhole Connection Plan		

APPROVAL

Rev.	Date	Revision	By	Appd.
A	04.02.20	Updated to suit revised design	LW	AJ


chartered consulting engineers
Tel: 01244 684910
Fax: 01244 684911
Email: admin@coopers.co.uk
Web: http://coopers.co.uk

Park House
Sandpiper Court
Chester Business Park
Chester
CH4 9QU

Client
CASTLEMEAD GROUP LTD.

Project
JACQUES WAY,
WREXHAM

Title
Surface Water Catchment Areas

DRAWING NUMBER	SCALE at A0	1:200	REVISION
7387 / 10	DATE	Oct 19	
	DRAWN	LW	
	CHECKED	AJ	A