 

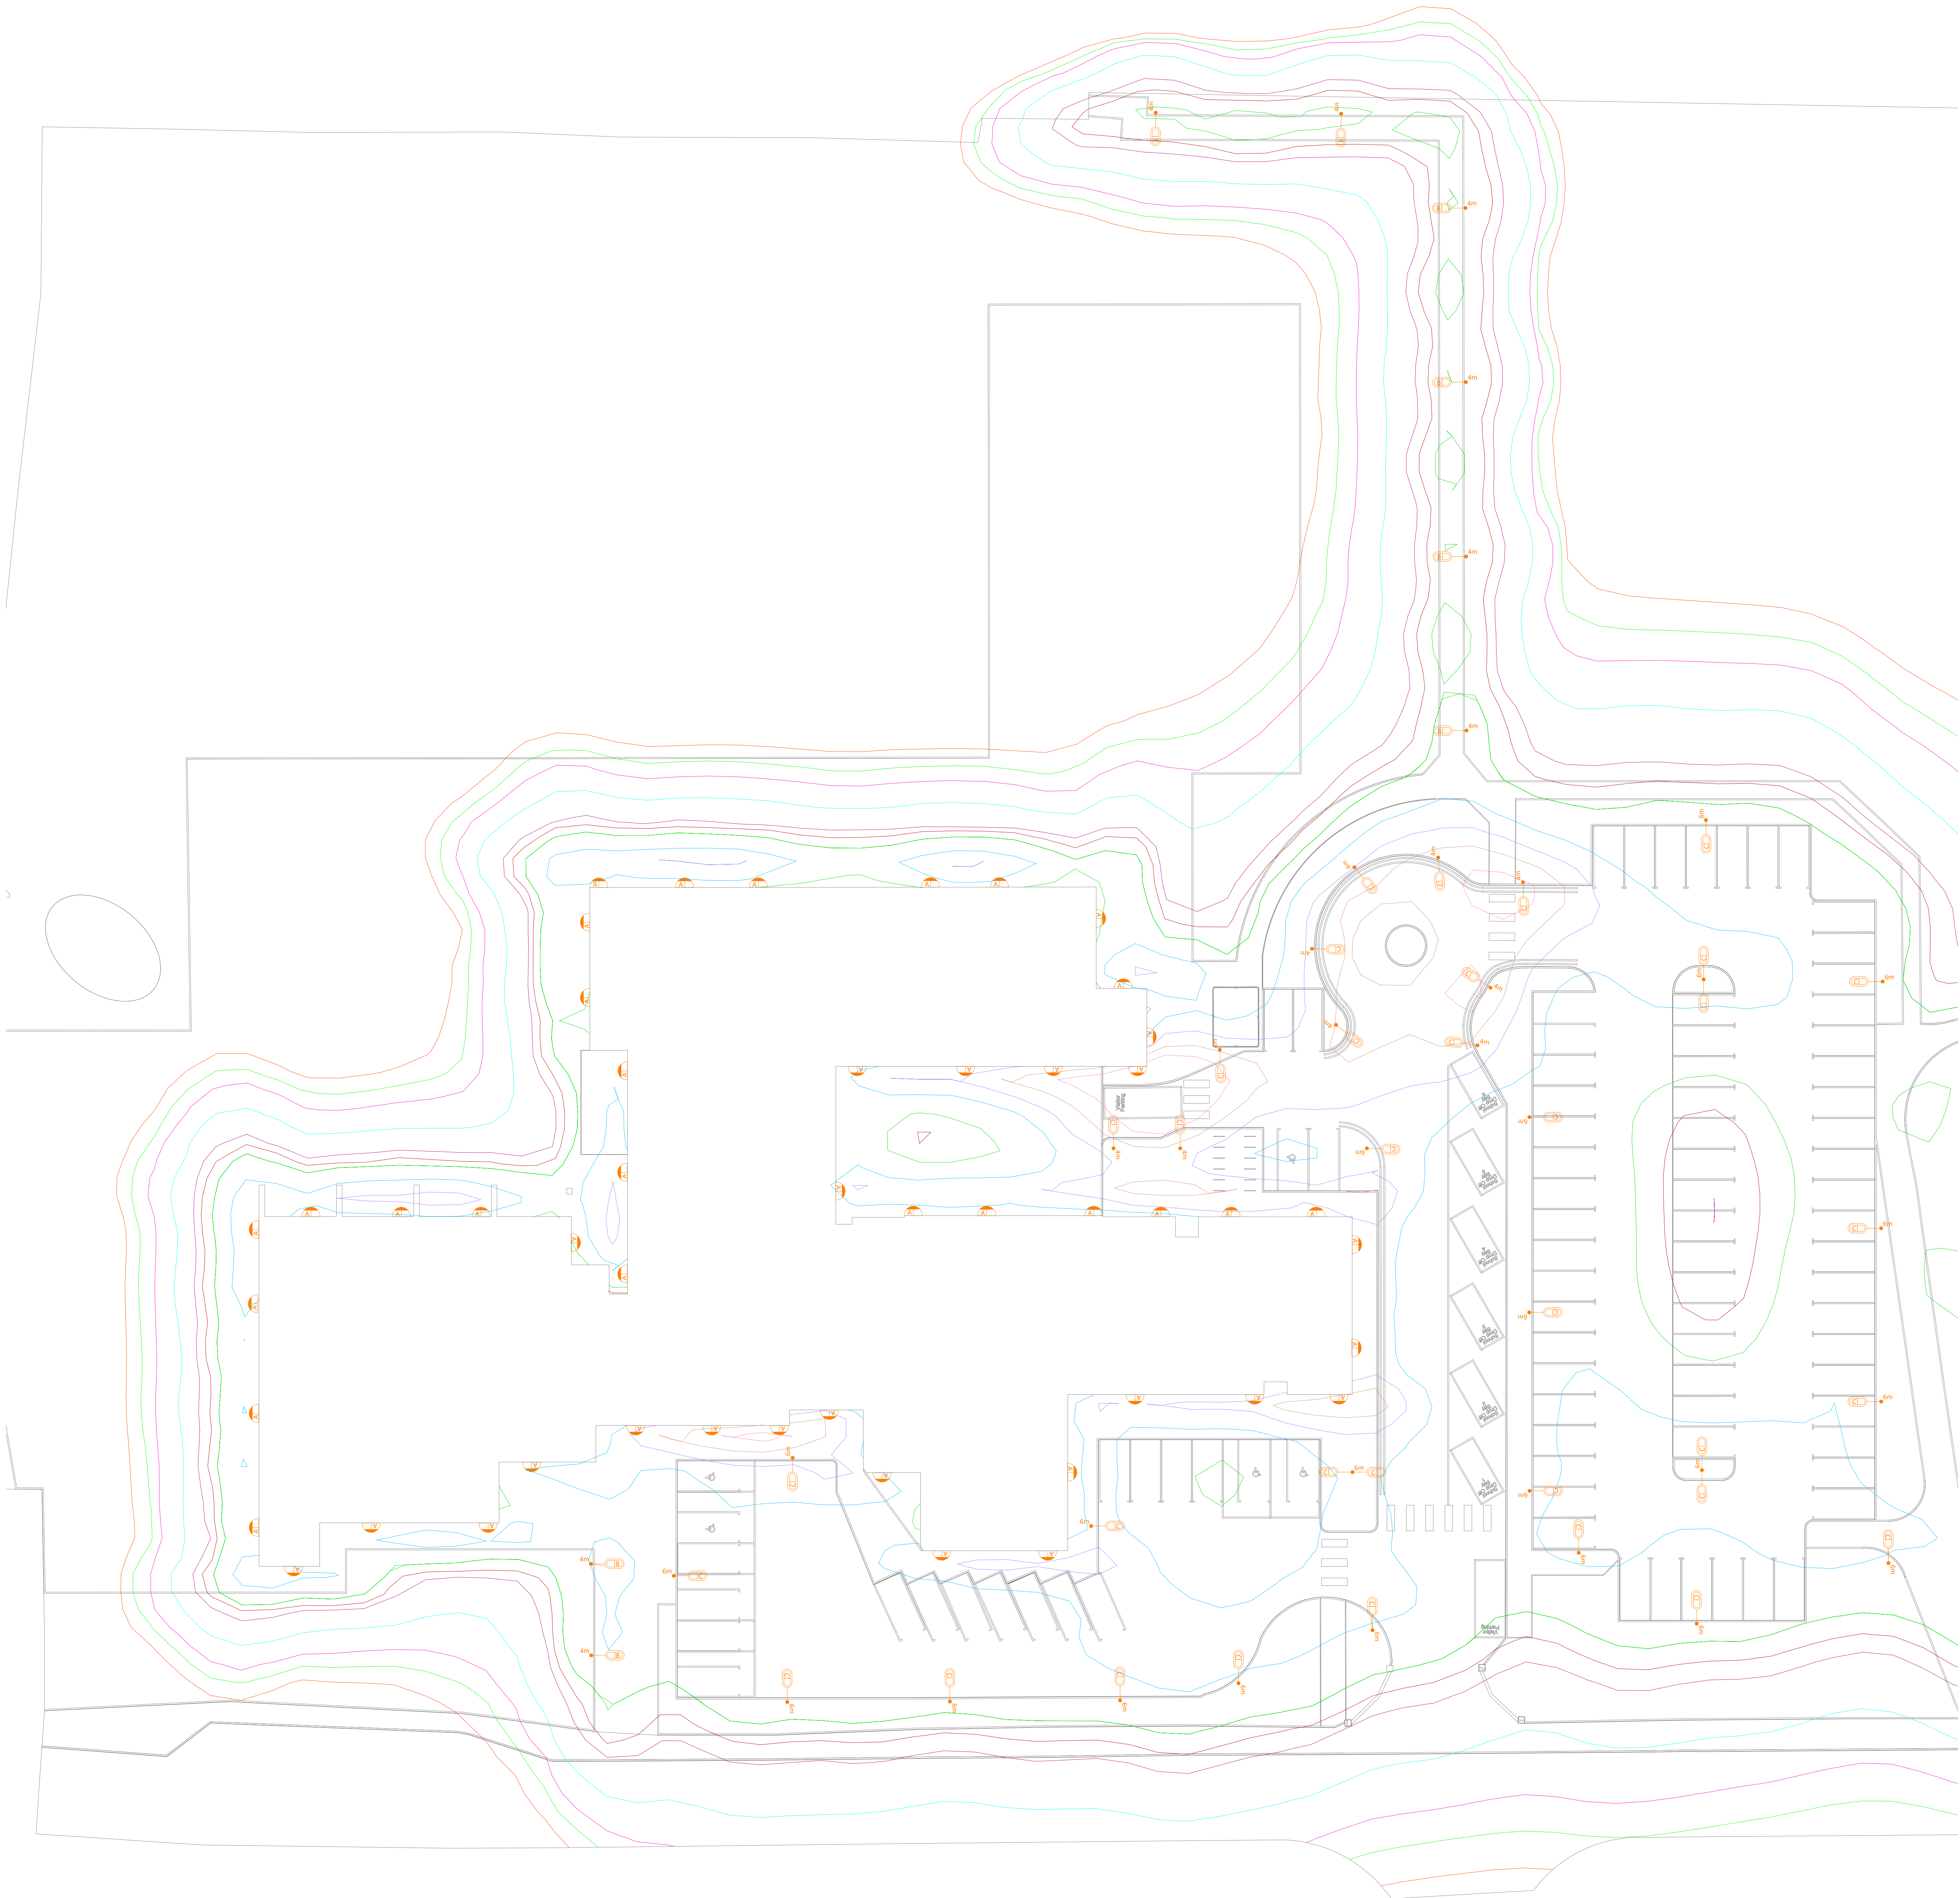


LUMINAIRE SCHEDULE / ATODLEN UNEDAU GOLEUO	
	LUMINAIRE REF / UNED OLEUO CYF - A MANUFACTURER / GWNEUTHURWR - THORLUX MODEL / MODEL - REALTA (WALL MOUNTED) SPECIFICATION / MANYLION - 8W, 3000K, POLYCARBONATE COVER, WIDE DISTRIBUTION, SMART, EMERGENCY.
	LUMINAIRE REF / UNED OLEUO CYF - B MANUFACTURER / GWNEUTHURWR - THORLUX MODEL / MODEL - REALTA (COLUMN MOUNTED 4m) SPECIFICATION / MANYLION - 8W, 3000K, POLYCARBONATE COVER, WIDE DISTRIBUTION, SMART.
	LUMINAIRE REF UNED OLEUO CYF - C MANUFACTURER / GWNEUTHURWR - THORLUX MODEL / MODEL - STARBEAM SPECIFICATION / MANYLION - 31W, 3000K, AREA DISTRIBUTION, SMART.
	SINGLE HEAD COLUMN MOUNTED LUMINAIRE / UNED OLEUO COLOFN UNIGOL "X" DENOTES LUMINAIRE REFERENCE / CYFEIRNOD UNED OLEUO "Nm" DENOTES COLUMN HEIGHT / UCHDER UNED OLEUO
	TWIN HEAD COLUMN MOUNTED LUMINAIRE / UNED OLEUO COLOFN GEFEILLIO "X" DENOTES LUMINAIRE REFERENCE / CYFEIRNOD UNED OLEUO "Nm" DENOTES COLUMN HEIGHT / UCHDER UNED OLEUO
	WALL MOUNTED LUMINAIRE / UNED OLEUO WAL "X" DENOTES LUMINAIRE REFERENCE / CYFEIRNOD UNED OLEUO

ISOLINES

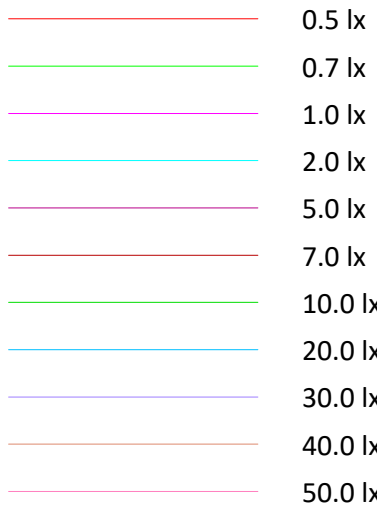


Rev.	Date	Description	Drawn	Check	Rev.
01	28/05/20	ISSUED FOR INFORMATION	MR	MR	MR
02	29/05/20	ISSUED FOR INFORMATION - SITE LAYOUT UPDATED	MR	MR	MR
03	29/05/20	NOIADAU CYMRAEG YCHWANGOL / WELSH ANNOTATION ADDED	MR	MR	MR
04	05/06/21	CYNLLUN SAFLE WEDD DIWEDDARU / SITE PLAN UPDATED	MR	MR	MR

Status	Purpose of Issue
S2	INFORMATION




Project
YSGOL GYNRADD GYMUNEDOL PARC BORRAS
/ BORRAS CP SCHOOL

Drawing Title
CYNLLUN GOLEUO ALLANOL /
EXTERNAL LIGHTING LAYOUT
CYNLLUN 1 OR 2 / SHEET 1 OF 2

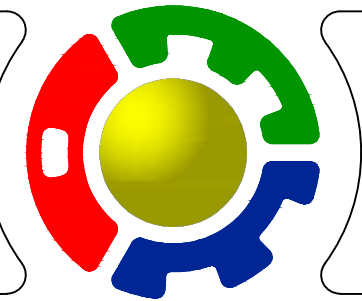

DAVIES PARTNERSHIP
BUILDING SERVICES CONSULTING ENGINEERS
ENVIRONMENTAL | DYNAMIC MODELLING | SUSTAINABLE DESIGN

Cestrian House, Lightfoot Street, Hoole, Chester, CH2 3AD.
Tel: 01244 315568
Email - cad@daviespartnership.co.uk
www.daviespartnership.co.uk

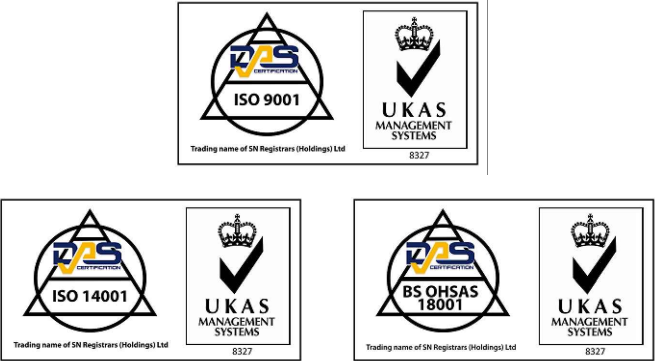

Date 10/05/20	Scale 1:200 @ A0	Eng MR
Drawn CAD	Check MR	Rev. P04

Drawn No.
BOR-DPL-A0-XX-DR-E-0003