


Legend:

- CFS
- PROPOSED COMBINED SEWER
- PROPOSED FOUL SEWER
- PROPOSED SURFACE WATER SEWER
- PROPOSED PUMP MAIN
- EXISTING SEWER TO BE GRUBBED UP
- LINEAR DRAINAGE CHANNEL
- PROPOSED ATTENUATION CRATES
- TRAPPED ROAD GULLY
- SITE BOUNDARY

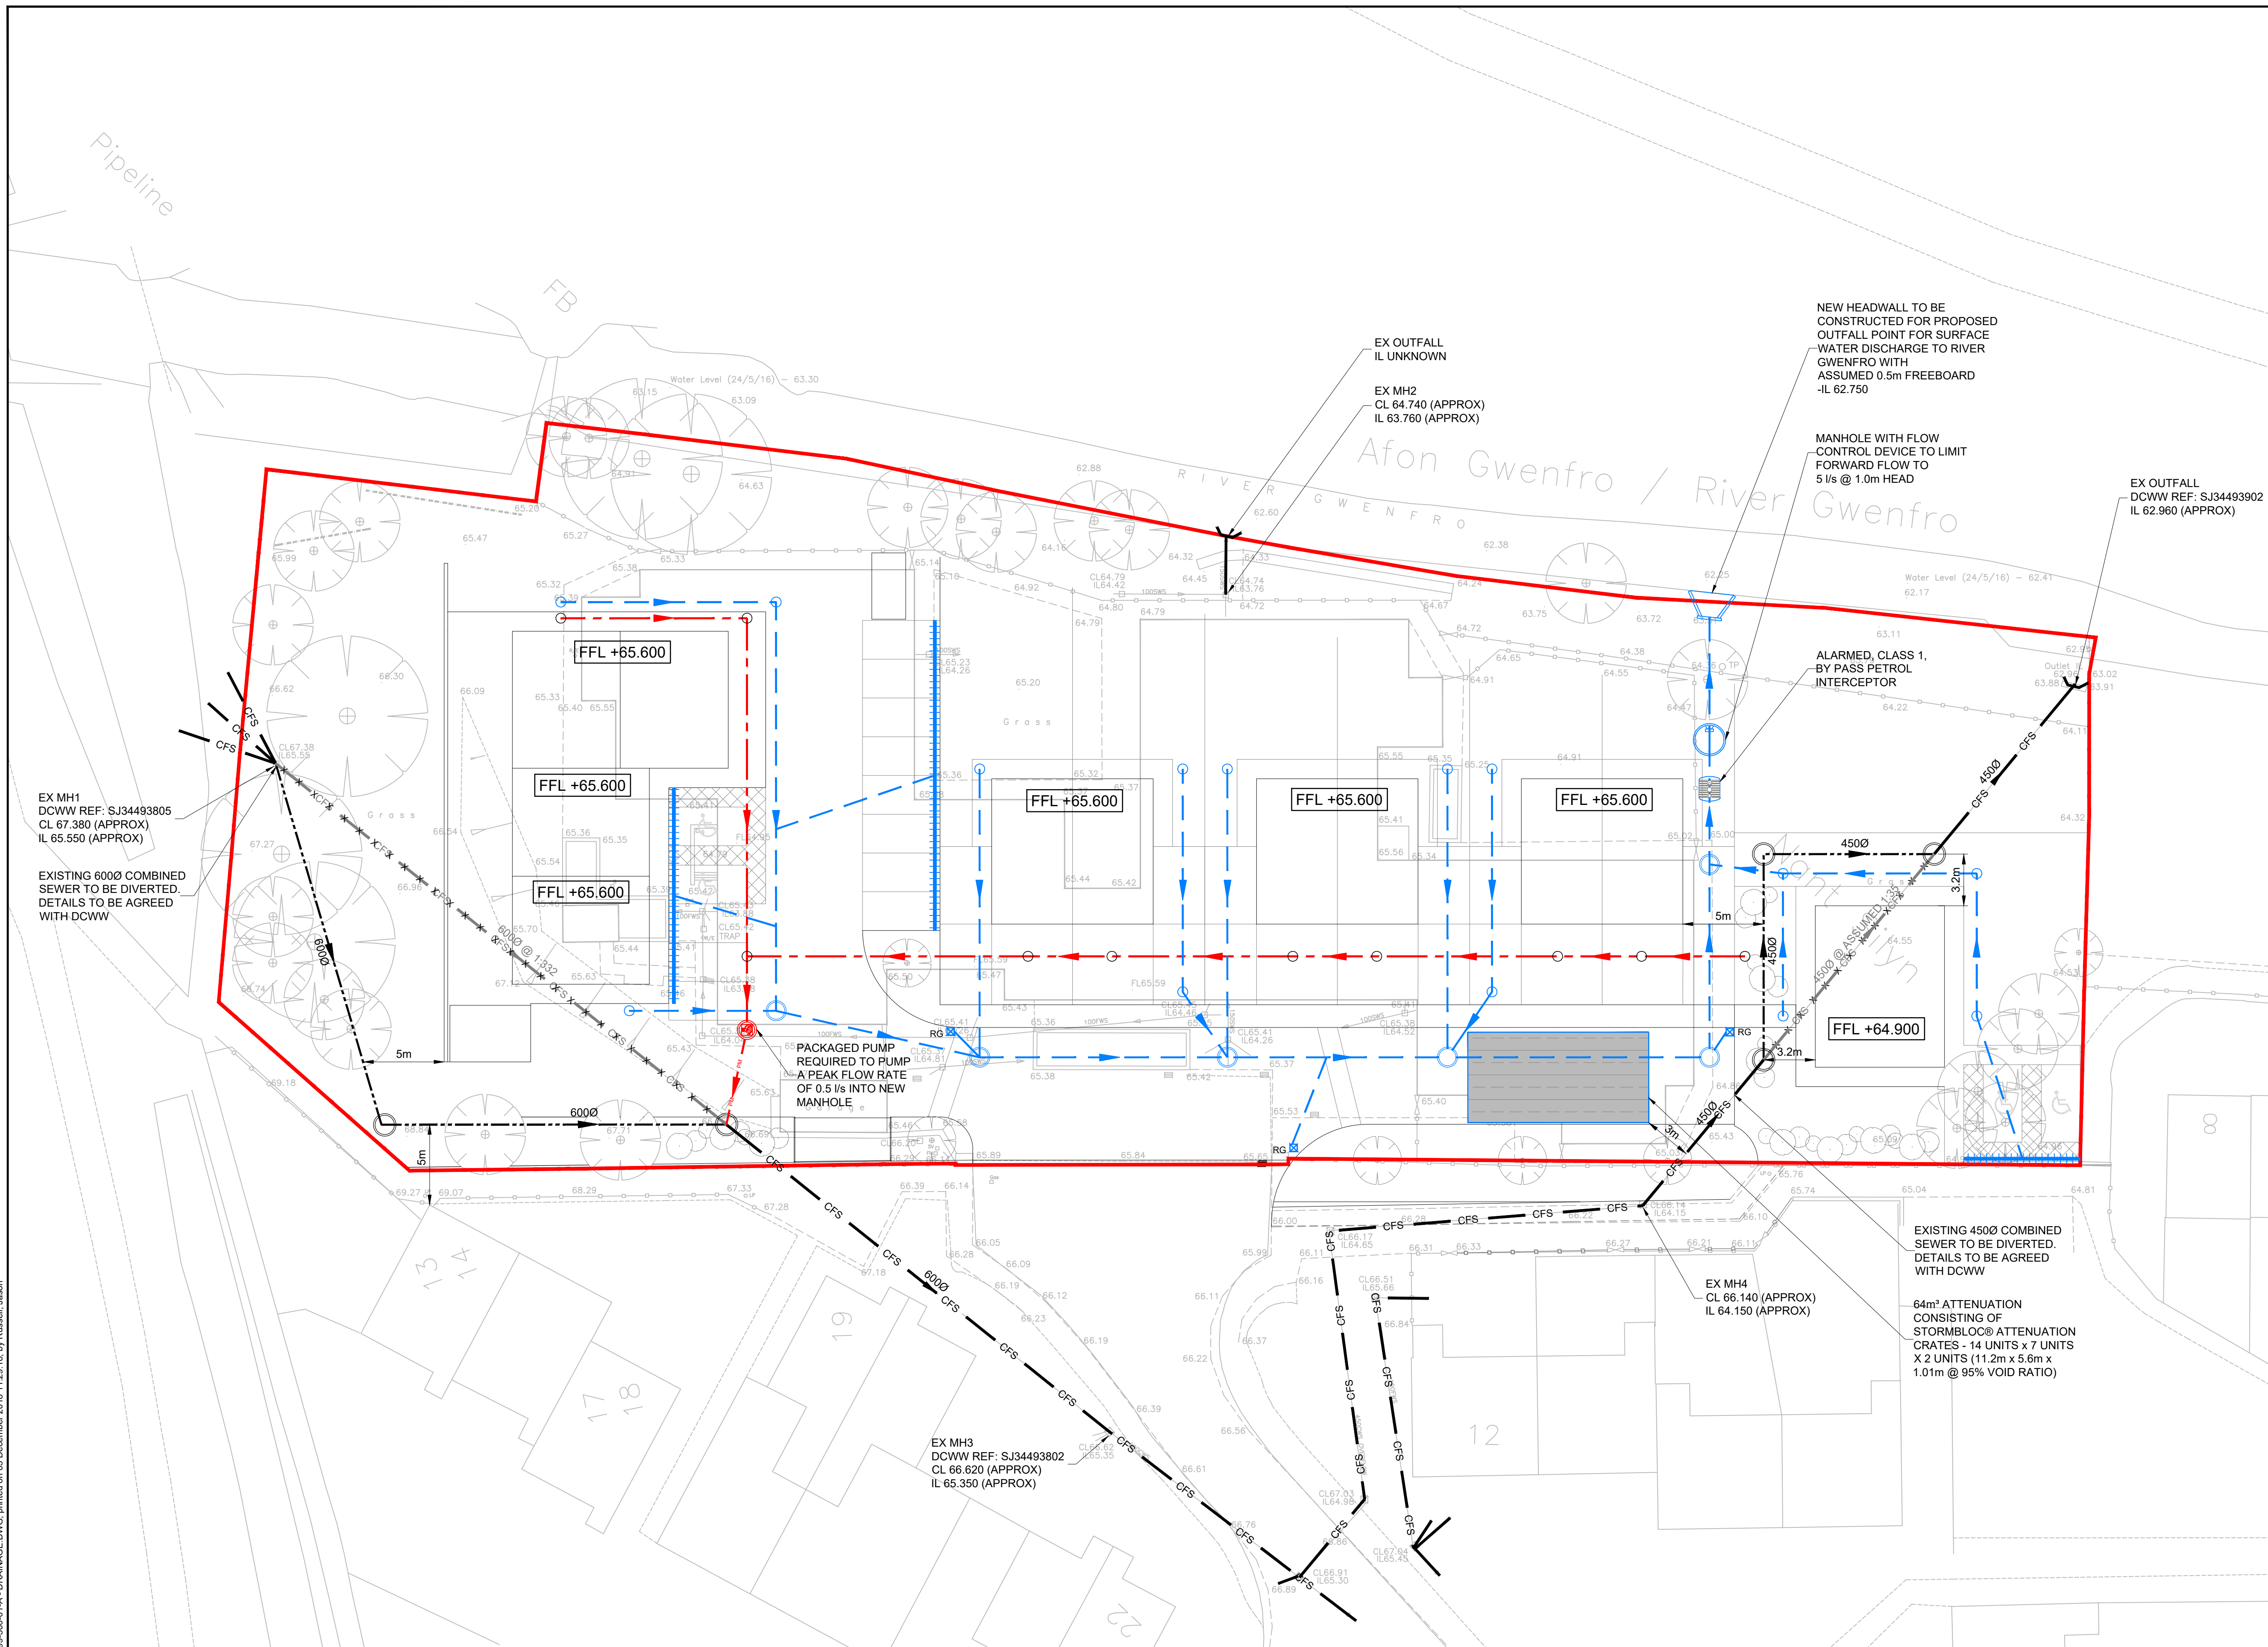

P01	07/12/2018	JR	FIRST ISSUE	GNT	WUG
REV	DATE	BY	DESCRIPTION	CHK	APP

DRAWING STATUS:



Opus House
Yale Business Village
Wrexham Technology
Park
Wrexham
LL13 7YL

T+ 44 (0) 1978 368 100
wsp.com

CLIENT:

ARCHITECT:

PROJECT: NANT SILYN

TITLE:

PROPOSED INDICATIVE
DRAINAGE LAYOUT

SCALE @ A1:	1:200	CHECKED:	VM	APPROVED:	MW
PROJECT No:	0799	DESIGNED:	VM	DRAWN:	JR
				DATE:	07/12/18
DRAWING No:					REV:
0799-100-02					P01
© WSP UK Ltd					