




Elevation A-A
Scale 1:150

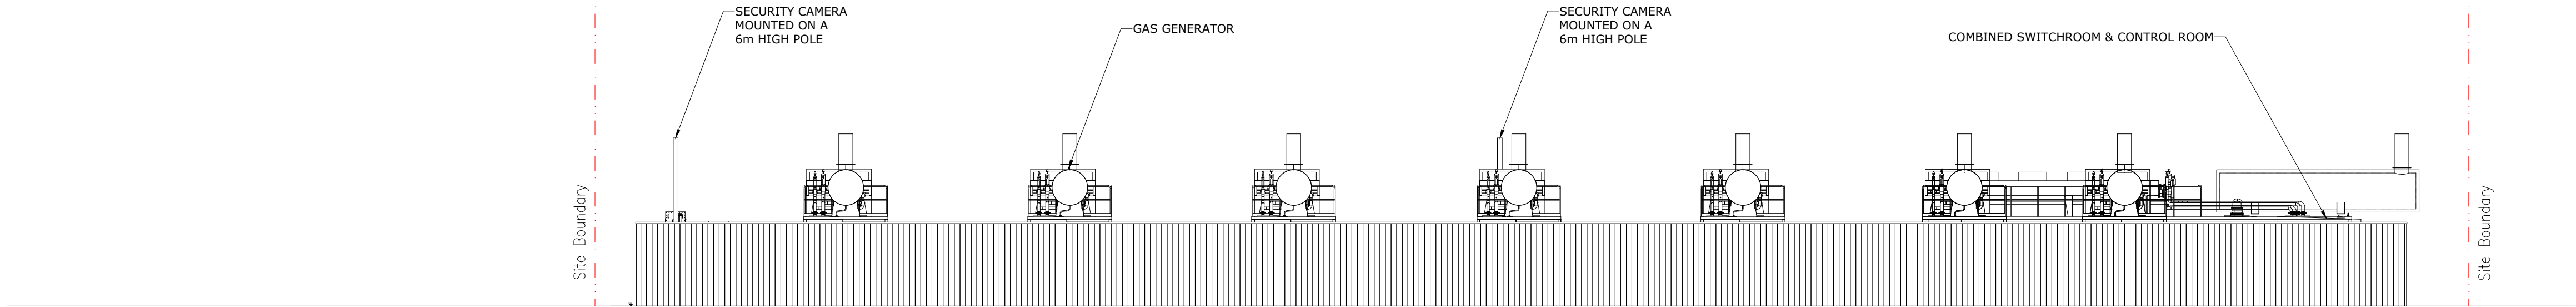



Elevation B-B
Scale 1:150

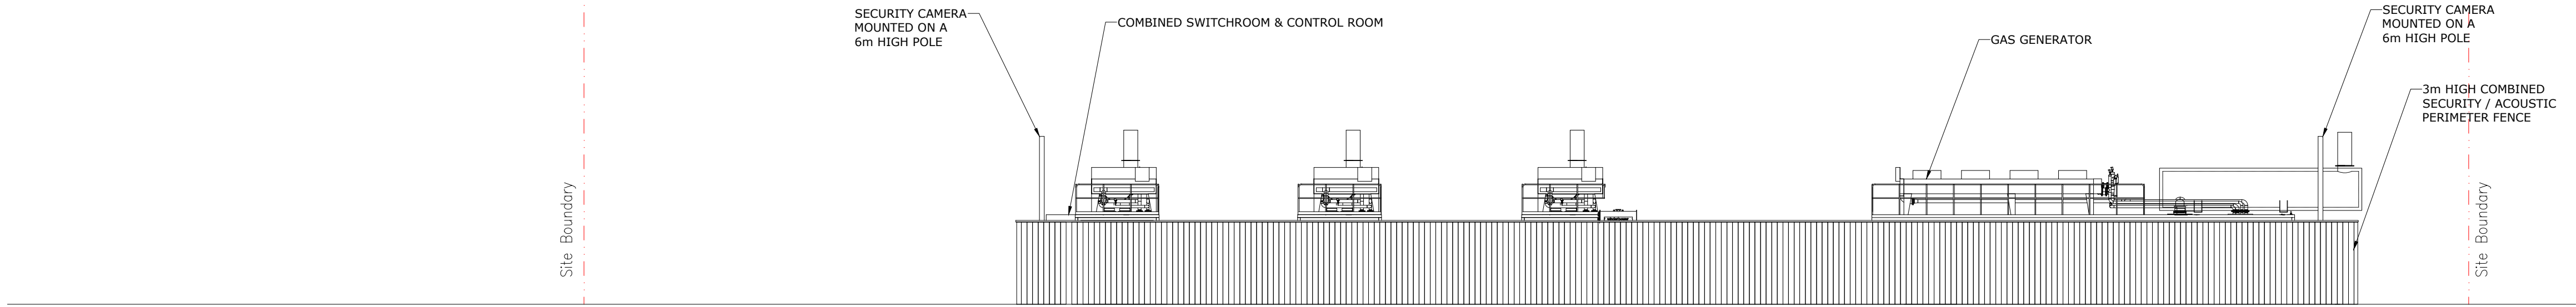

Elevation C-C
Scale 1:150

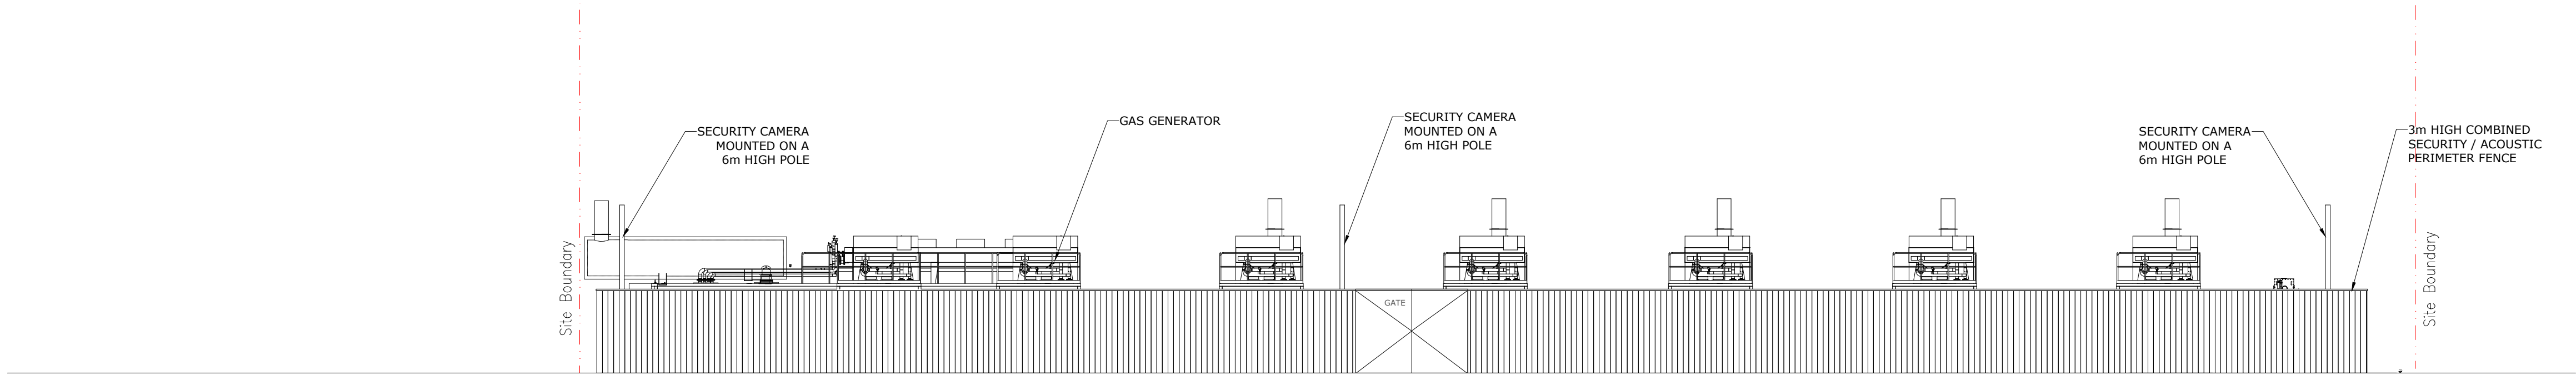

Elevation D-D
Scale 1:150

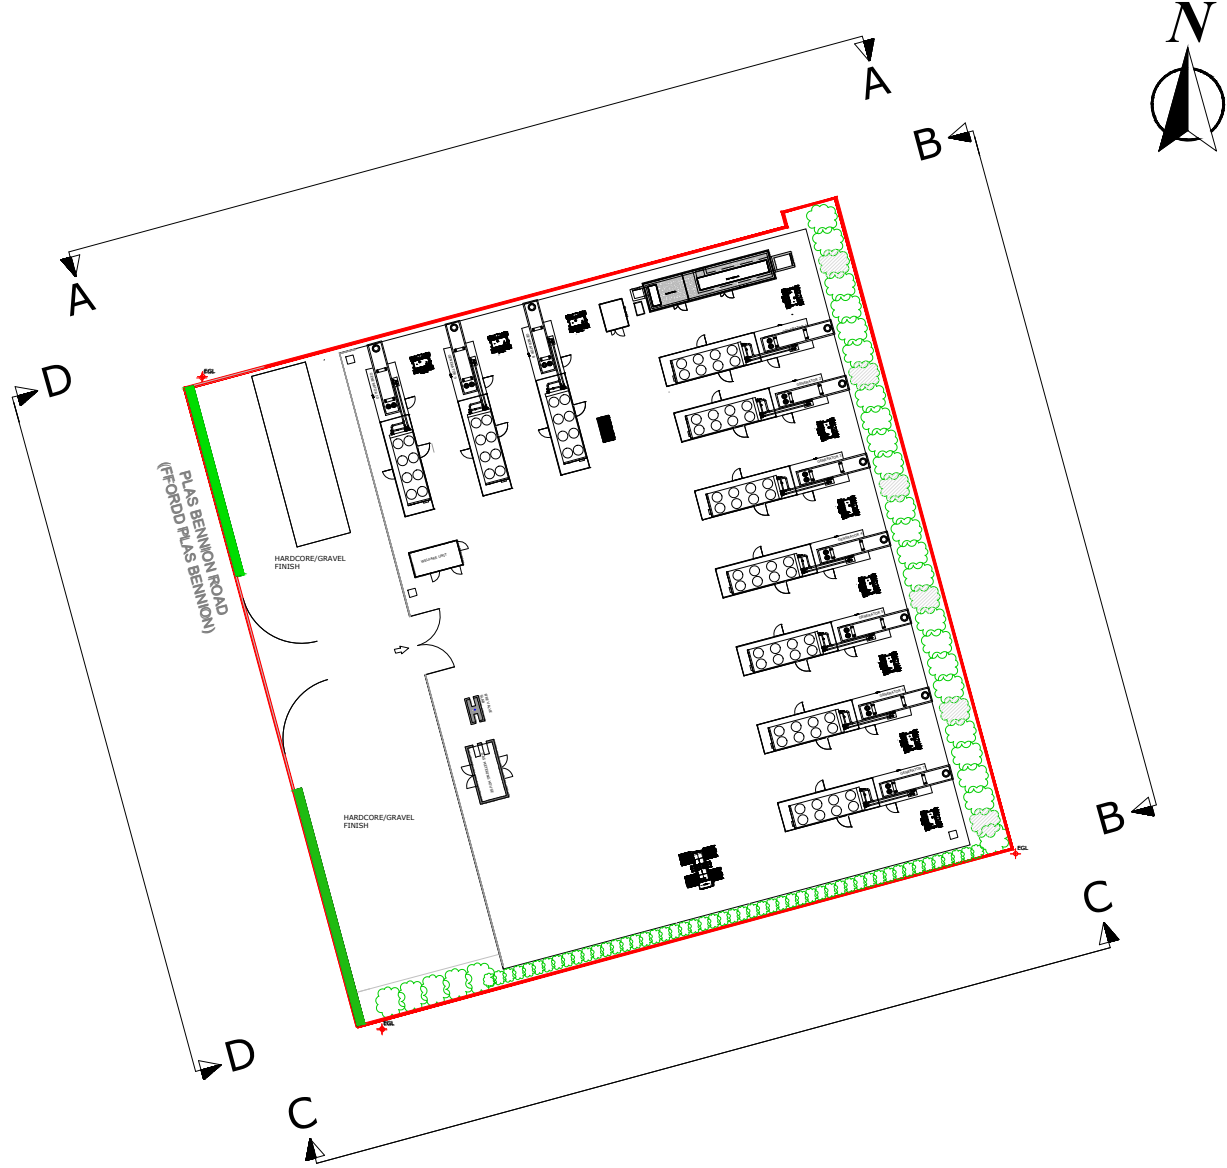 

Notes				
MAXIMUM PLANT DIMENSIONS				
Plant Item	Max. Number	Max. Width (m)	Max. Length (m)	Max. Height (m)
Gas Generator	10	3.0	17.5	6
Gas Metering House	1	2.5	5.5	2.5
Gas Boiler House	1	2	2.5	2.5
0.4/33kVA Transformers @ 2.5MVA	10	2.3	1.9	2.5
Welfare Unit	1	2.4	6.0	3
Combined Switchroom & Control Room	1	3	13	3.2
Acoustic Screen	1	Enclosing generating facility compound	Enclosing generating facility compound	3
Auxiliary Generator	1	1.2	2.3	1.6
Security Camera	2	x	x	6
Current Limiting Reactor	1	3.7	4	3.4

Rev	Description of Revision	Date
5	Revised Generator (Halliwell Exhaust) New intake switchroom Added Current Limiting Reactor Added Revised enclosure's	22/08/18
4	Dimesnsions table updated	14/08/17
3	Revised Text	02/08/17
2	Gensets & Layout Revised	01/08/17
1	Notes Added	17/07/17
0	Issued For Information	14/07/17
Rev	Description of Revision	Date
Revision History		

Rev	Description of Revision	Date
Rev	Description of Revision	Date
Revision History		

Disclaimer
© Copyright of this drawing, is the property of FES Ltd. This drawing must not be reproduced, amended to or for the execution of any works whether in conjunction with the works to which it was prepared or otherwise, without the express permission of FES Ltd.
Do NOT scale. Use figured dimensions.
Architects Base Negative ID
Consultants Base Negative ID

FES Ltd. Forth House Pirnhall Business Park Stirling, FK7 8HW Tel. 01786 819 600 Fax. 01786 811 456
Discipline ☐ Electrical Services ☐ Mechanical Services ☒ High Voltage Services ☐ Communications Services ☐ Fire Protection
Drawn D.S. Checked R.J.B.
Drawing Number 50312-(90)-002(b) Revision 5

Project Cefn Mwar 20MW Emergency Standby Generator Facility
Drawing Title Electrical Plant Elevations
Scale 1:150 Date July 17
Issue Status Planning
Sheet A1