
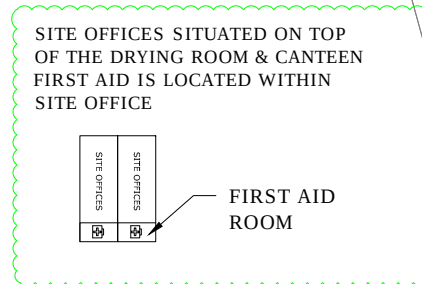


Legend

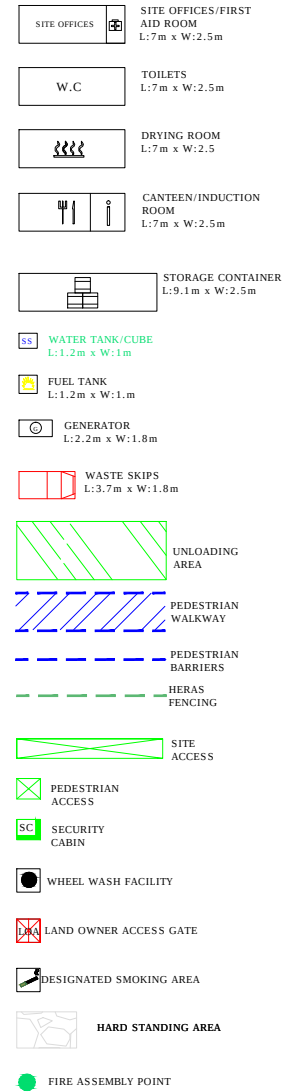

Notes

|                  |                         |      |  |
|------------------|-------------------------|------|--|
|                  |                         |      |  |
| Rev              | Description of Revision | Date |  |
| Revision History |                         |      |  |

Disclaimer

© Copyright of this drawing, is the property of FES Ltd. This drawing must not be reproduced, amended to or for the execution of any works whether in conjunction with the works to which it was prepared or otherwise, without the express permission of FES Ltd.

Do NOT scale. Use figured dimensions.

Architects Base Negative ID

Consultants Base Negative ID

**FES Ltd.**  
Forth House  
Pirnhall Business Park  
Stirling, FK7 8HW  
Tel. 01786 819 600  
Fax. 01786 811 456



Discipline

☐ Electrical Services

☐ Mechanical Services

☒ High Voltage Services

☐ Communications Services

☐ Fire Protection

Drawn D.S

|         |     |
|---------|-----|
| Checked | R.H |
|---------|-----|

Drawing Number  
50312-SK-001(SP)-A

|          |   |
|----------|---|
| Revision | 0 |
|----------|---|

Project  
Cefn Mawr  
20MW Emergency Standby  
Generator Facility

Drawing Title

Site Welfare  
&  
Security Plan Option (A)

|             |                |
|-------------|----------------|
| Scale 1:500 | Date Sept 2017 |
|-------------|----------------|

## Issue Status Information

A3