


DRAINAGE DOES NOT FORM PART OF SCOPE OF WORKS.

LEGEND

- 150Ø 1:150 PROPOSED PRIVATE SURFACE WATER SEWER & MANHOLE
- RWP RAINWATER DOWNPIPE 100Ø CONNECTION
- ACO Qmax 225 CHANNEL DRAIN - OR SIMILAR APPROVED
- ACO ROAD DRAIN PD100C 10.1 - OR SIMILAR APPROVED
- 1:40 PROPOSED SERVICE YARD CROSSFALL
- EXISTING GAS MAIN (ROUTE SHOWN INDICATIVELY)

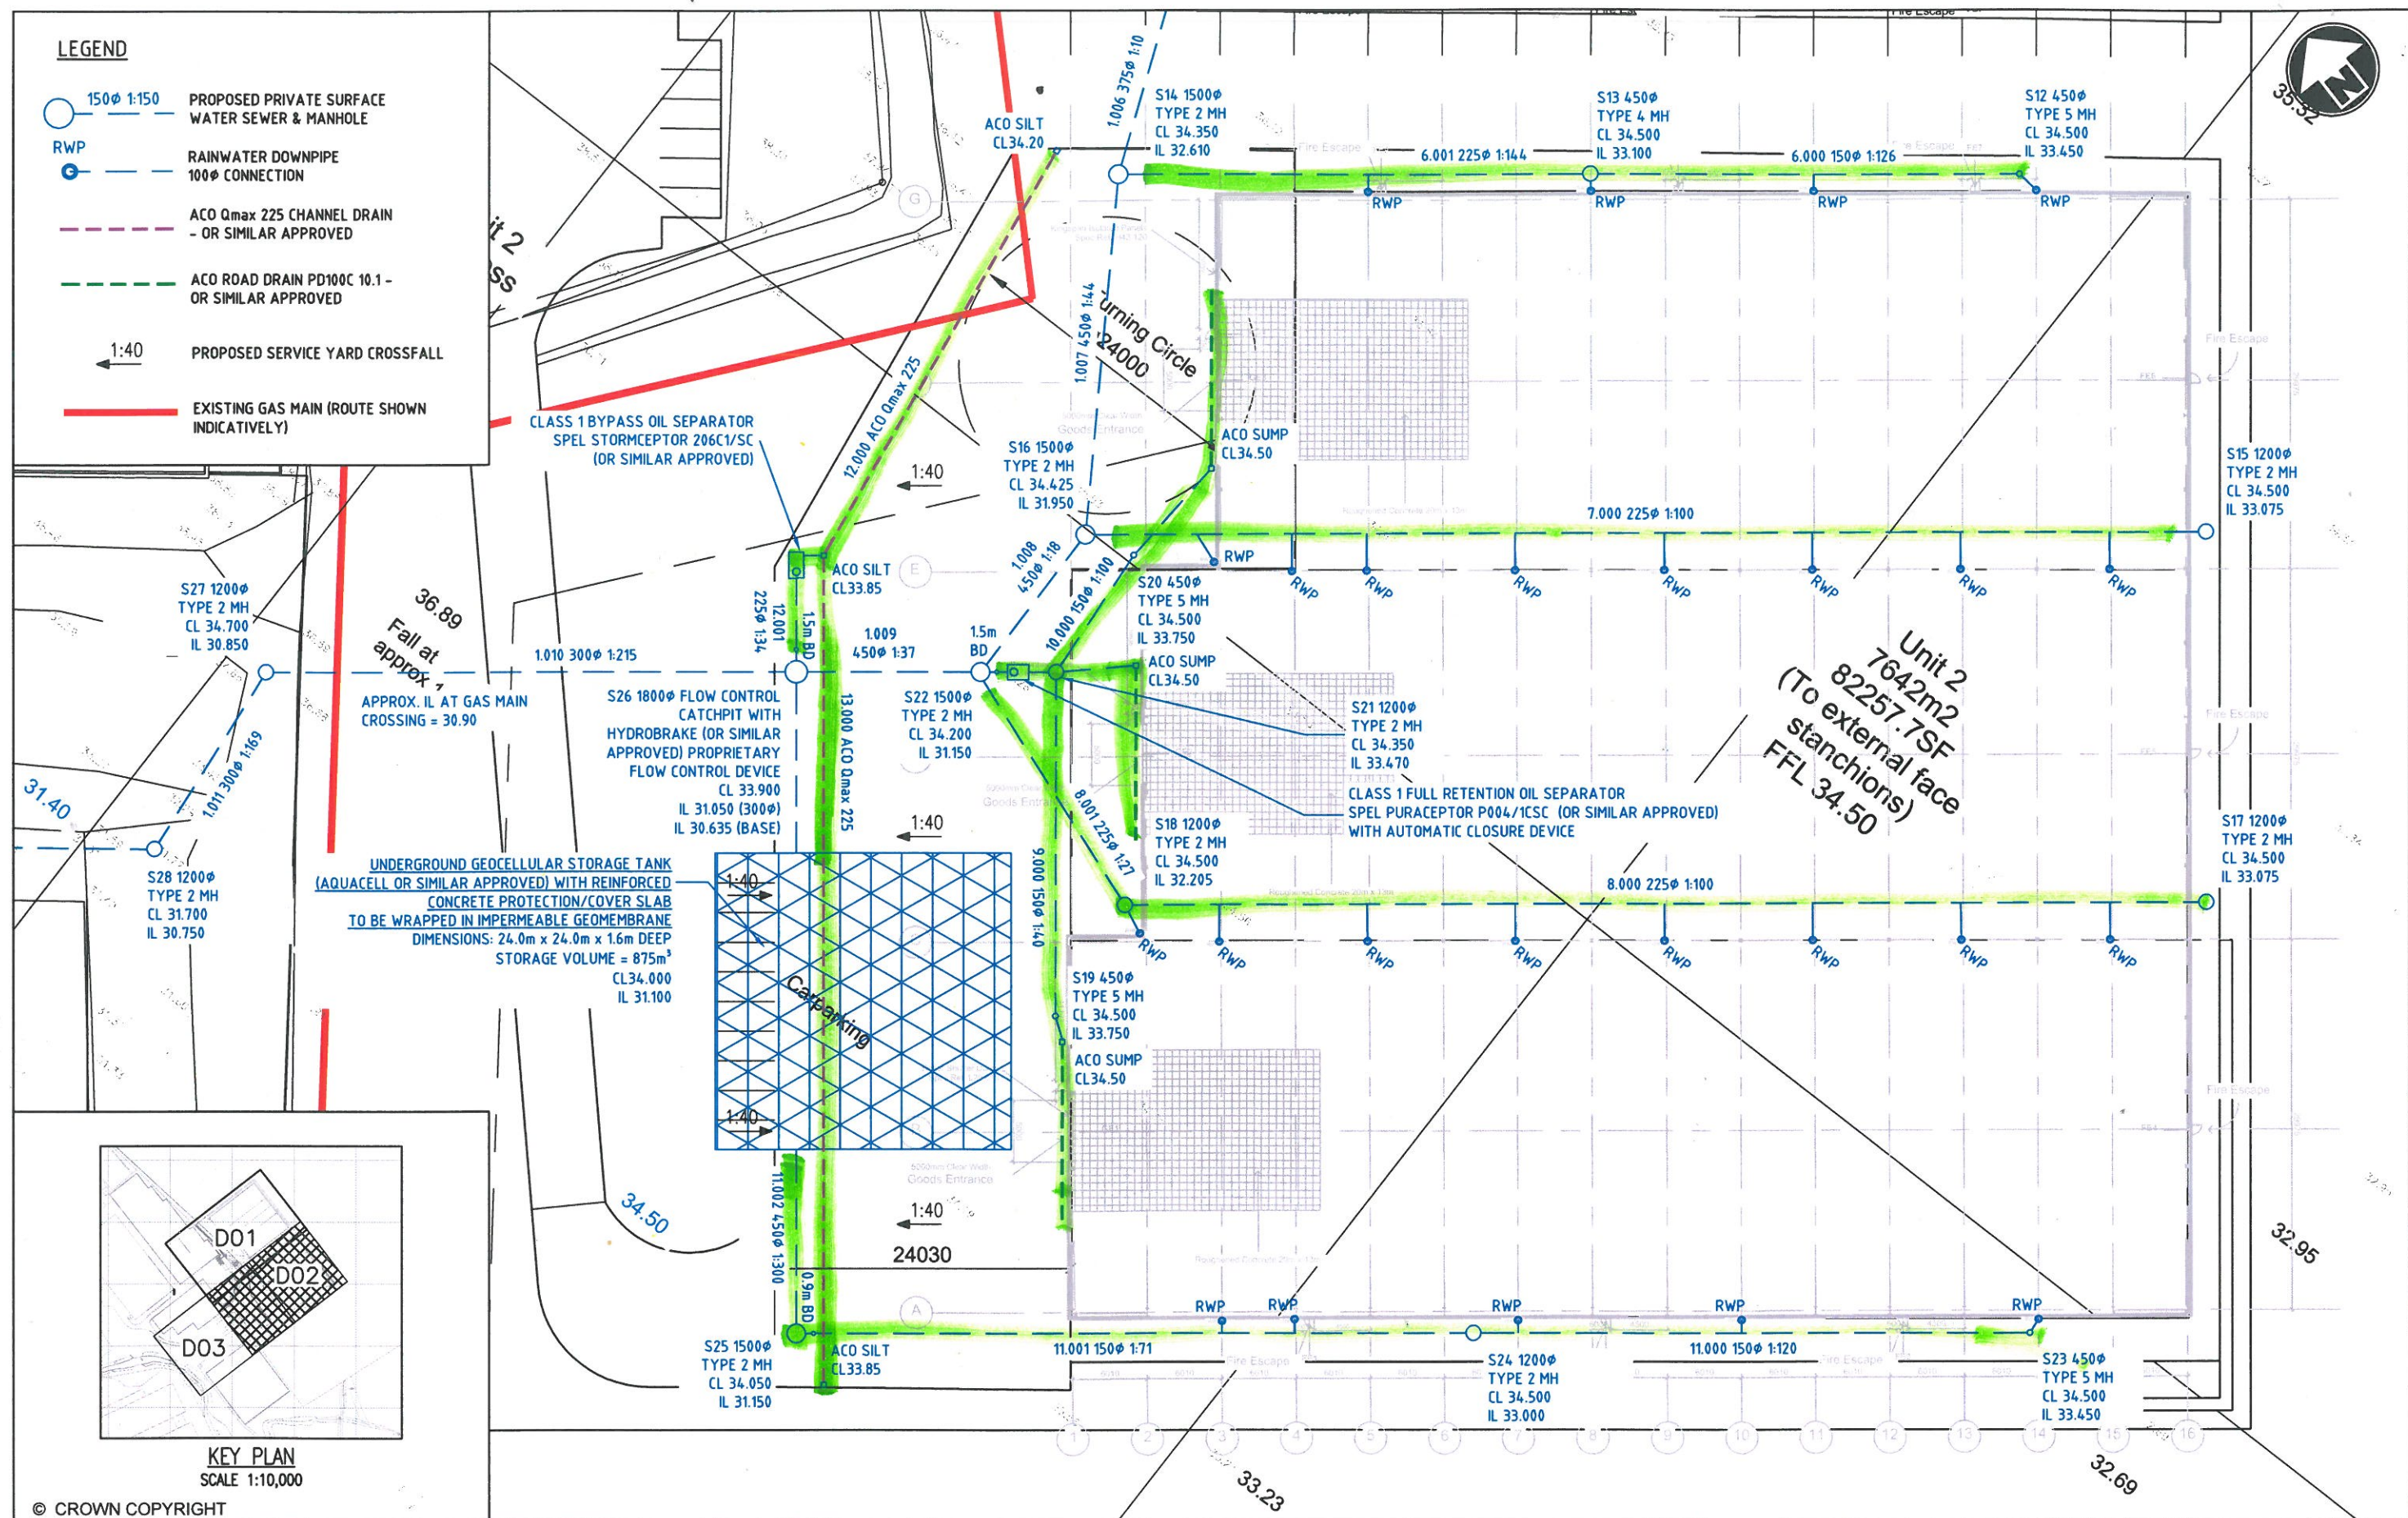

KEY PLAN
SCALE 1:10,000

© CROWN COPYRIGHT

D02 Drainage Layout (Sheet 2 of 3)

NOTES:

- DO NOT SCALE SETTING OUT POSITIONS FROM THIS DRAWING, REFER TO MANHOLE SCHEDULE FOR SETTING OUT CO-ORDINATES
- ALL LEVELS ARE SHOWN INDICATIVELY. CONTRACTOR TO UNDERTAKE TOPOGRAPHICAL SURVEY TO VERIFY ALL EXISTING & PROPOSED LEVELS PRIOR TO COMMENCEMENT
- CONTRACTOR TO UNDERTAKE COMPREHENSIVE SEARCH & SURVEY OF EXISTING UTILITIES PRIOR TO COMMENCEMENT. CONTRACTOR TO OBTAIN ALL RELEVANT STATUTORY LICENSES & APPROVALS FOR ANY WORKS WITHIN MINIMUM STAND-OFF DISTANCE OF EXISTING UTILITIES.

- DETAILS FOR INSTALLATION OF ALL PROPRIETARY PRODUCTS (I.E. GEOCELL, GEOTEXTILES & SEPARATORS) TO BE OBTAINED FROM THE MANUFACTURER PRIOR TO CONSTRUCTION. ALL PROPRIETARY PRODUCTS TO BE CONSTRUCTED ACCORDING TO MANUFACTURERS SPECIFICATION.
- CONTRACTOR TO AVOID CONSTRUCTION PLANT TRAFFICKING OVER THE GEOCELLULAR TANK. IF CONSTRUCTION PLANT ARE TO RUN OVER THE INSTALLATION THE MINIMUM PROTECTIVE COVER SHOULD BE 500mm OF WELL COMPACTED GRANULAR MATERIAL. ONLY TRACKED EXCAVATORS CAN BE USED & MUST NOT EXCEED 14 TONNES. COMPACTION PLANT MUST NOT EXCEED 2300kg/m

Date	04.08.2014	Drawn	PS
Scale	1:500	Checked	BS
Original	A3	Revision	2
File Reference			

