


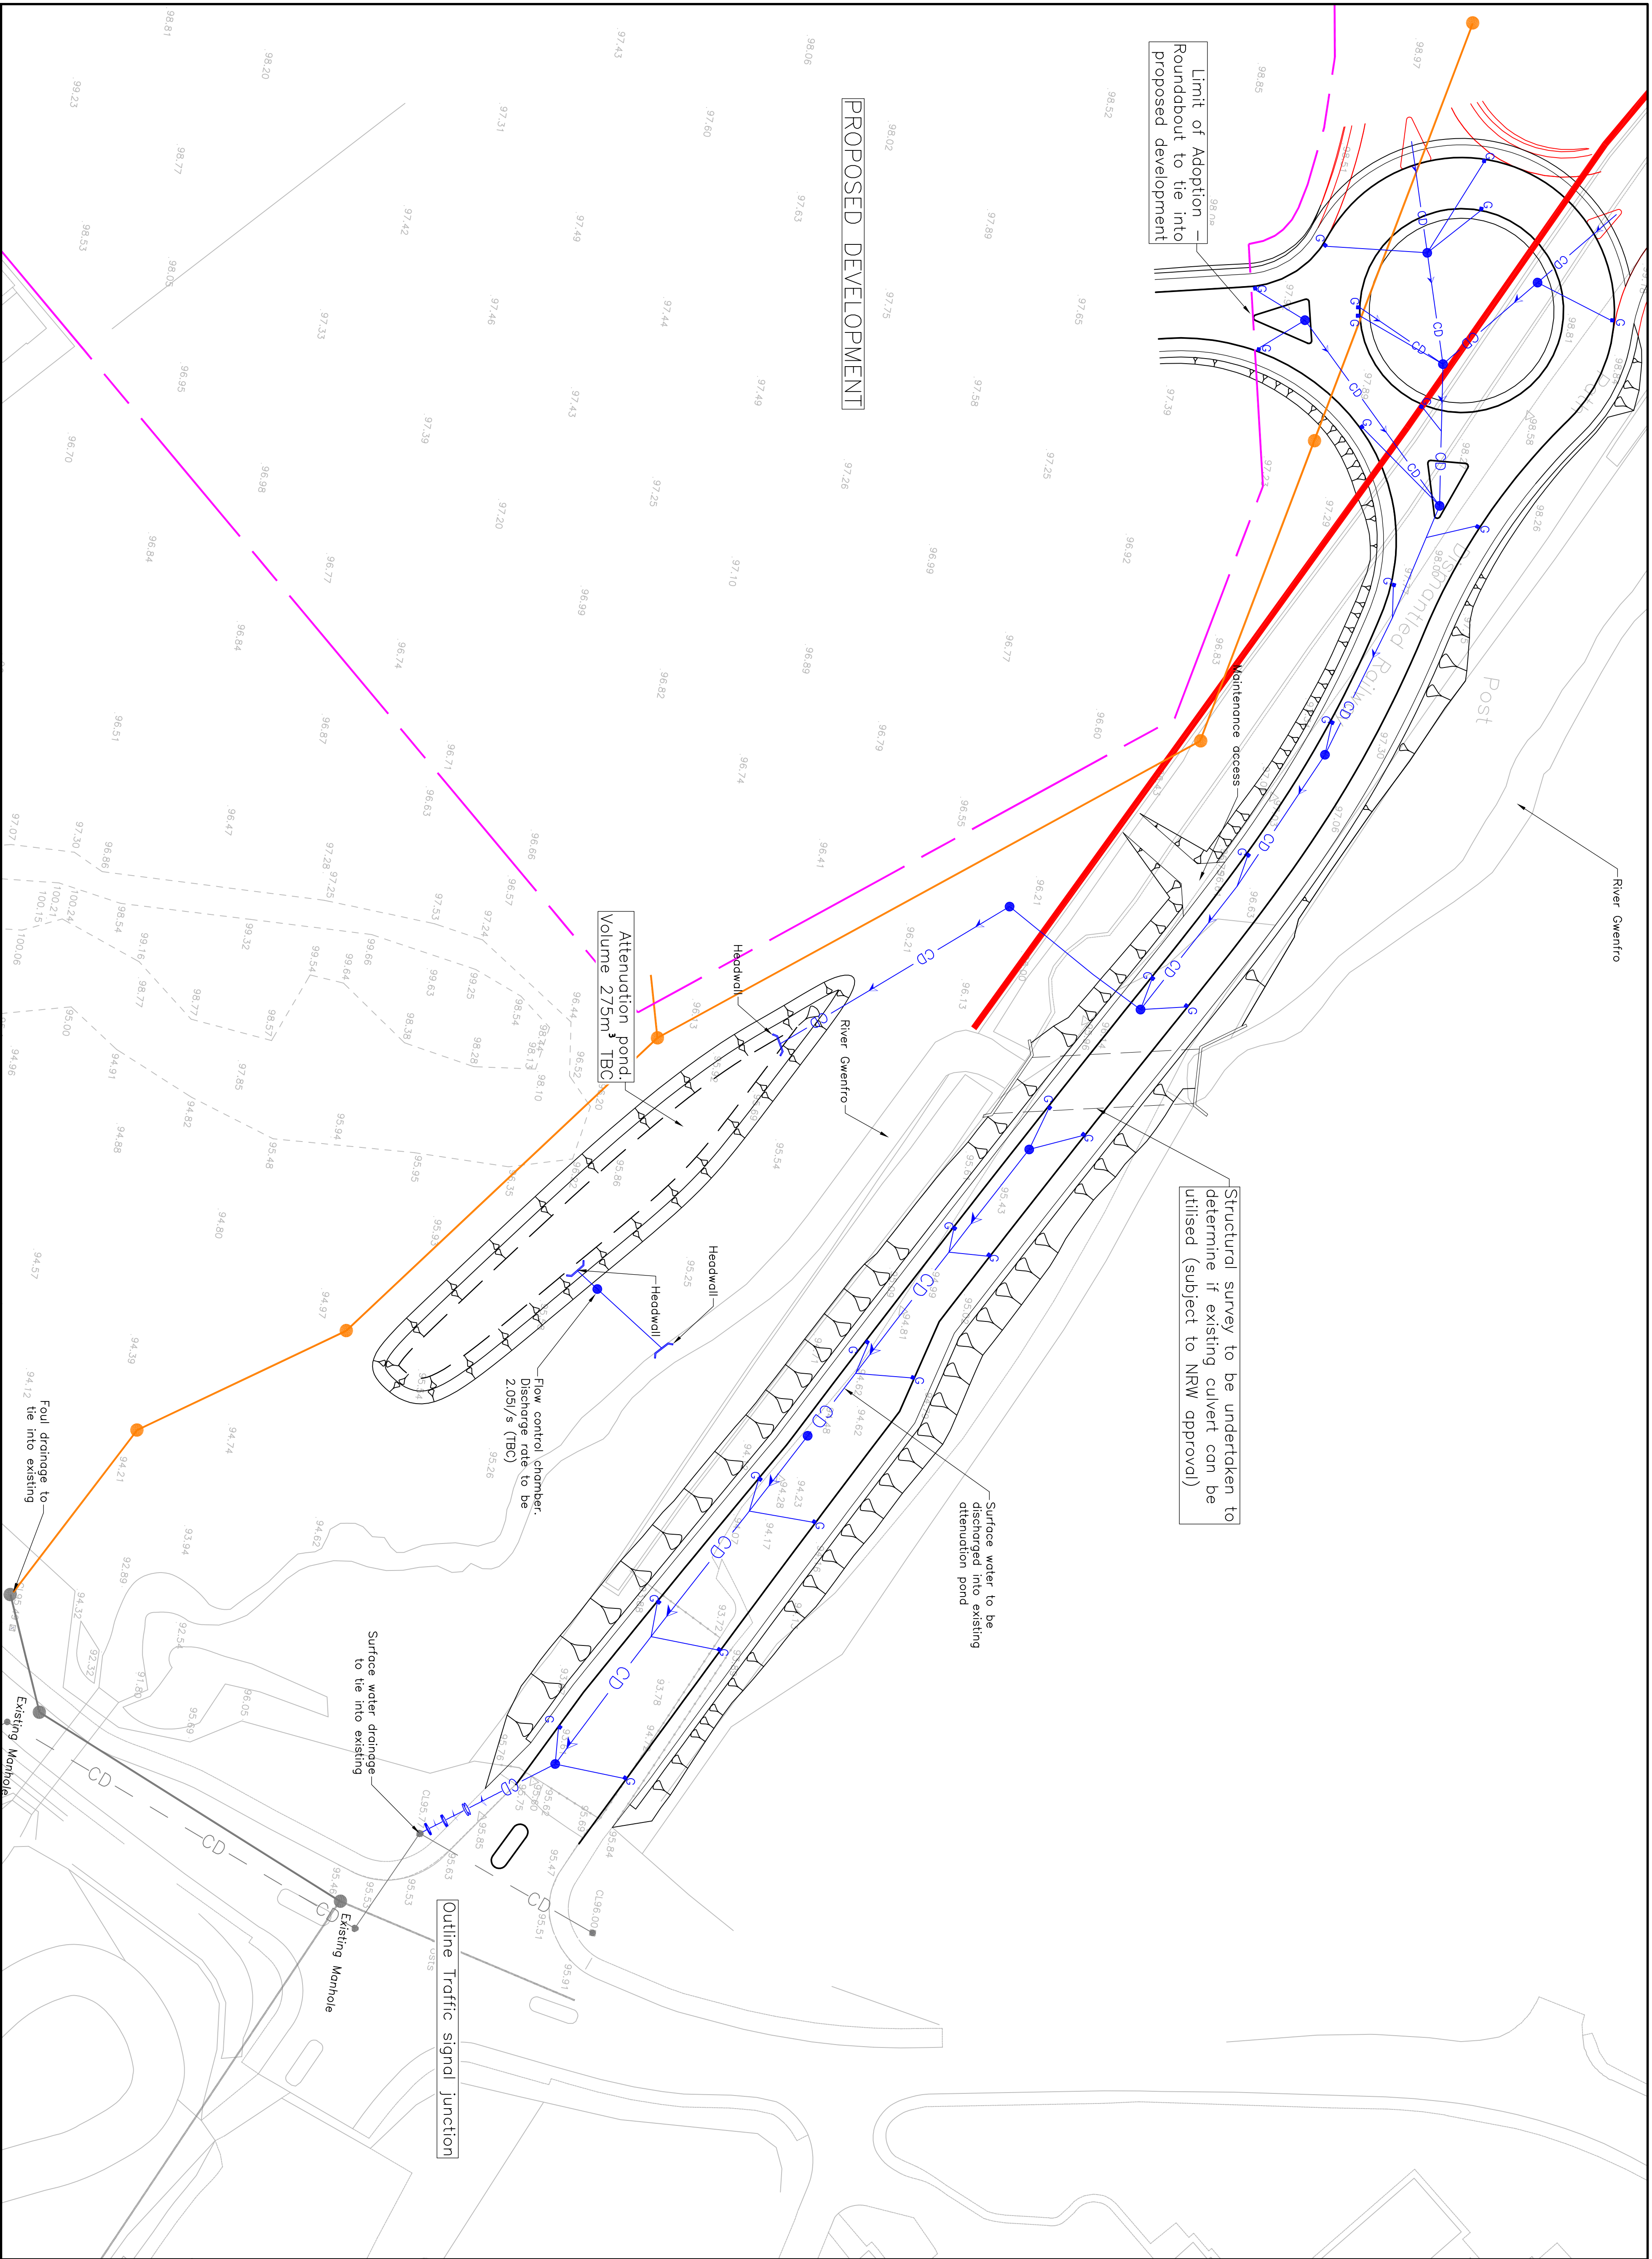

NOTES

1. This drawing should only be read in relation to the subject of the title. Other information shown on this drawing is to be considered indicative only. References should be made to appropriate drawing series for other information.
2. All dimensions are in millimetres unless specified otherwise.
3. Do not scale from this drawing.

KEY

- Stormwater carrier drain
- Stormwater gully
- Stormwater catchpit
- Petrol interceptor
- Existing storm water carrier drain
- Foul drainage
- Foul Manhole
- Existing foul
- Existing Welsh Government Drainage
- Proposed development land boundary

Client

wrexham
COUNTY BOROUGH COUNCIL
CHANCERY ROAD
wrexham

Project

WREXHAM
WESTERN GATEWAY

RAMBOLL

tel 01244 311855 fax 01244 314560 cheser@ramboll.co.uk
www.ramboll.co.uk

Drawing Title

**FOUL AND STORM WATER
DRAINAGE LAYOUT**

D	Rev.	-				
	Drawn	JW	MRD	JW	MRD	AH
	Chkd.	MRD	SC	SC	SC	SC
	Apprvd.	Date	27.06.14	31.07.14	05.08.14	07.08.14
B			FOR PLANNING			
	Rev.	JW		MRD	SC	SC
	Drawn	JW		MRD	SC	SC
	Chkd.	MRD		SC	SC	SC
C			FOR PLANNING			
	Rev.	JW		MRD	SC	SC
	Drawn	JW		MRD	SC	SC
	Chkd.	MRD		SC	SC	SC
A			DRAFT FOR COMMENT			
	Rev.	JW		MRD	SC	SC
	Drawn	JW		MRD	SC	SC
	Chkd.	MRD		SC	SC	SC
AS SHOWN	Scale (at A1)		Description			
	Rev.	JW		MRD	SC	SC
	Drawn	JW		MRD	SC	SC
	Chkd.	MRD		SC	SC	SC
JUNE 2014	Date					
	Rev.	JW		MRD	SC	SC
	Drawn	JW		MRD	SC	SC
	Chkd.	MRD		SC	SC	SC
JW	Drawn					
	Rev.	JW		MRD	SC	SC
	Drawn	JW		MRD	SC	SC
	Chkd.	MRD		SC	SC	SC
61033427-H-500-01	Dwg. no.					
	Rev.	JW		MRD	SC	SC
	Drawn	JW		MRD	SC	SC
	Chkd.	MRD		SC	SC	SC
C	Rev.					
	Rev.	JW		MRD	SC	SC
	Drawn	JW		MRD	SC	SC
	Chkd.	MRD		SC	SC	SC