


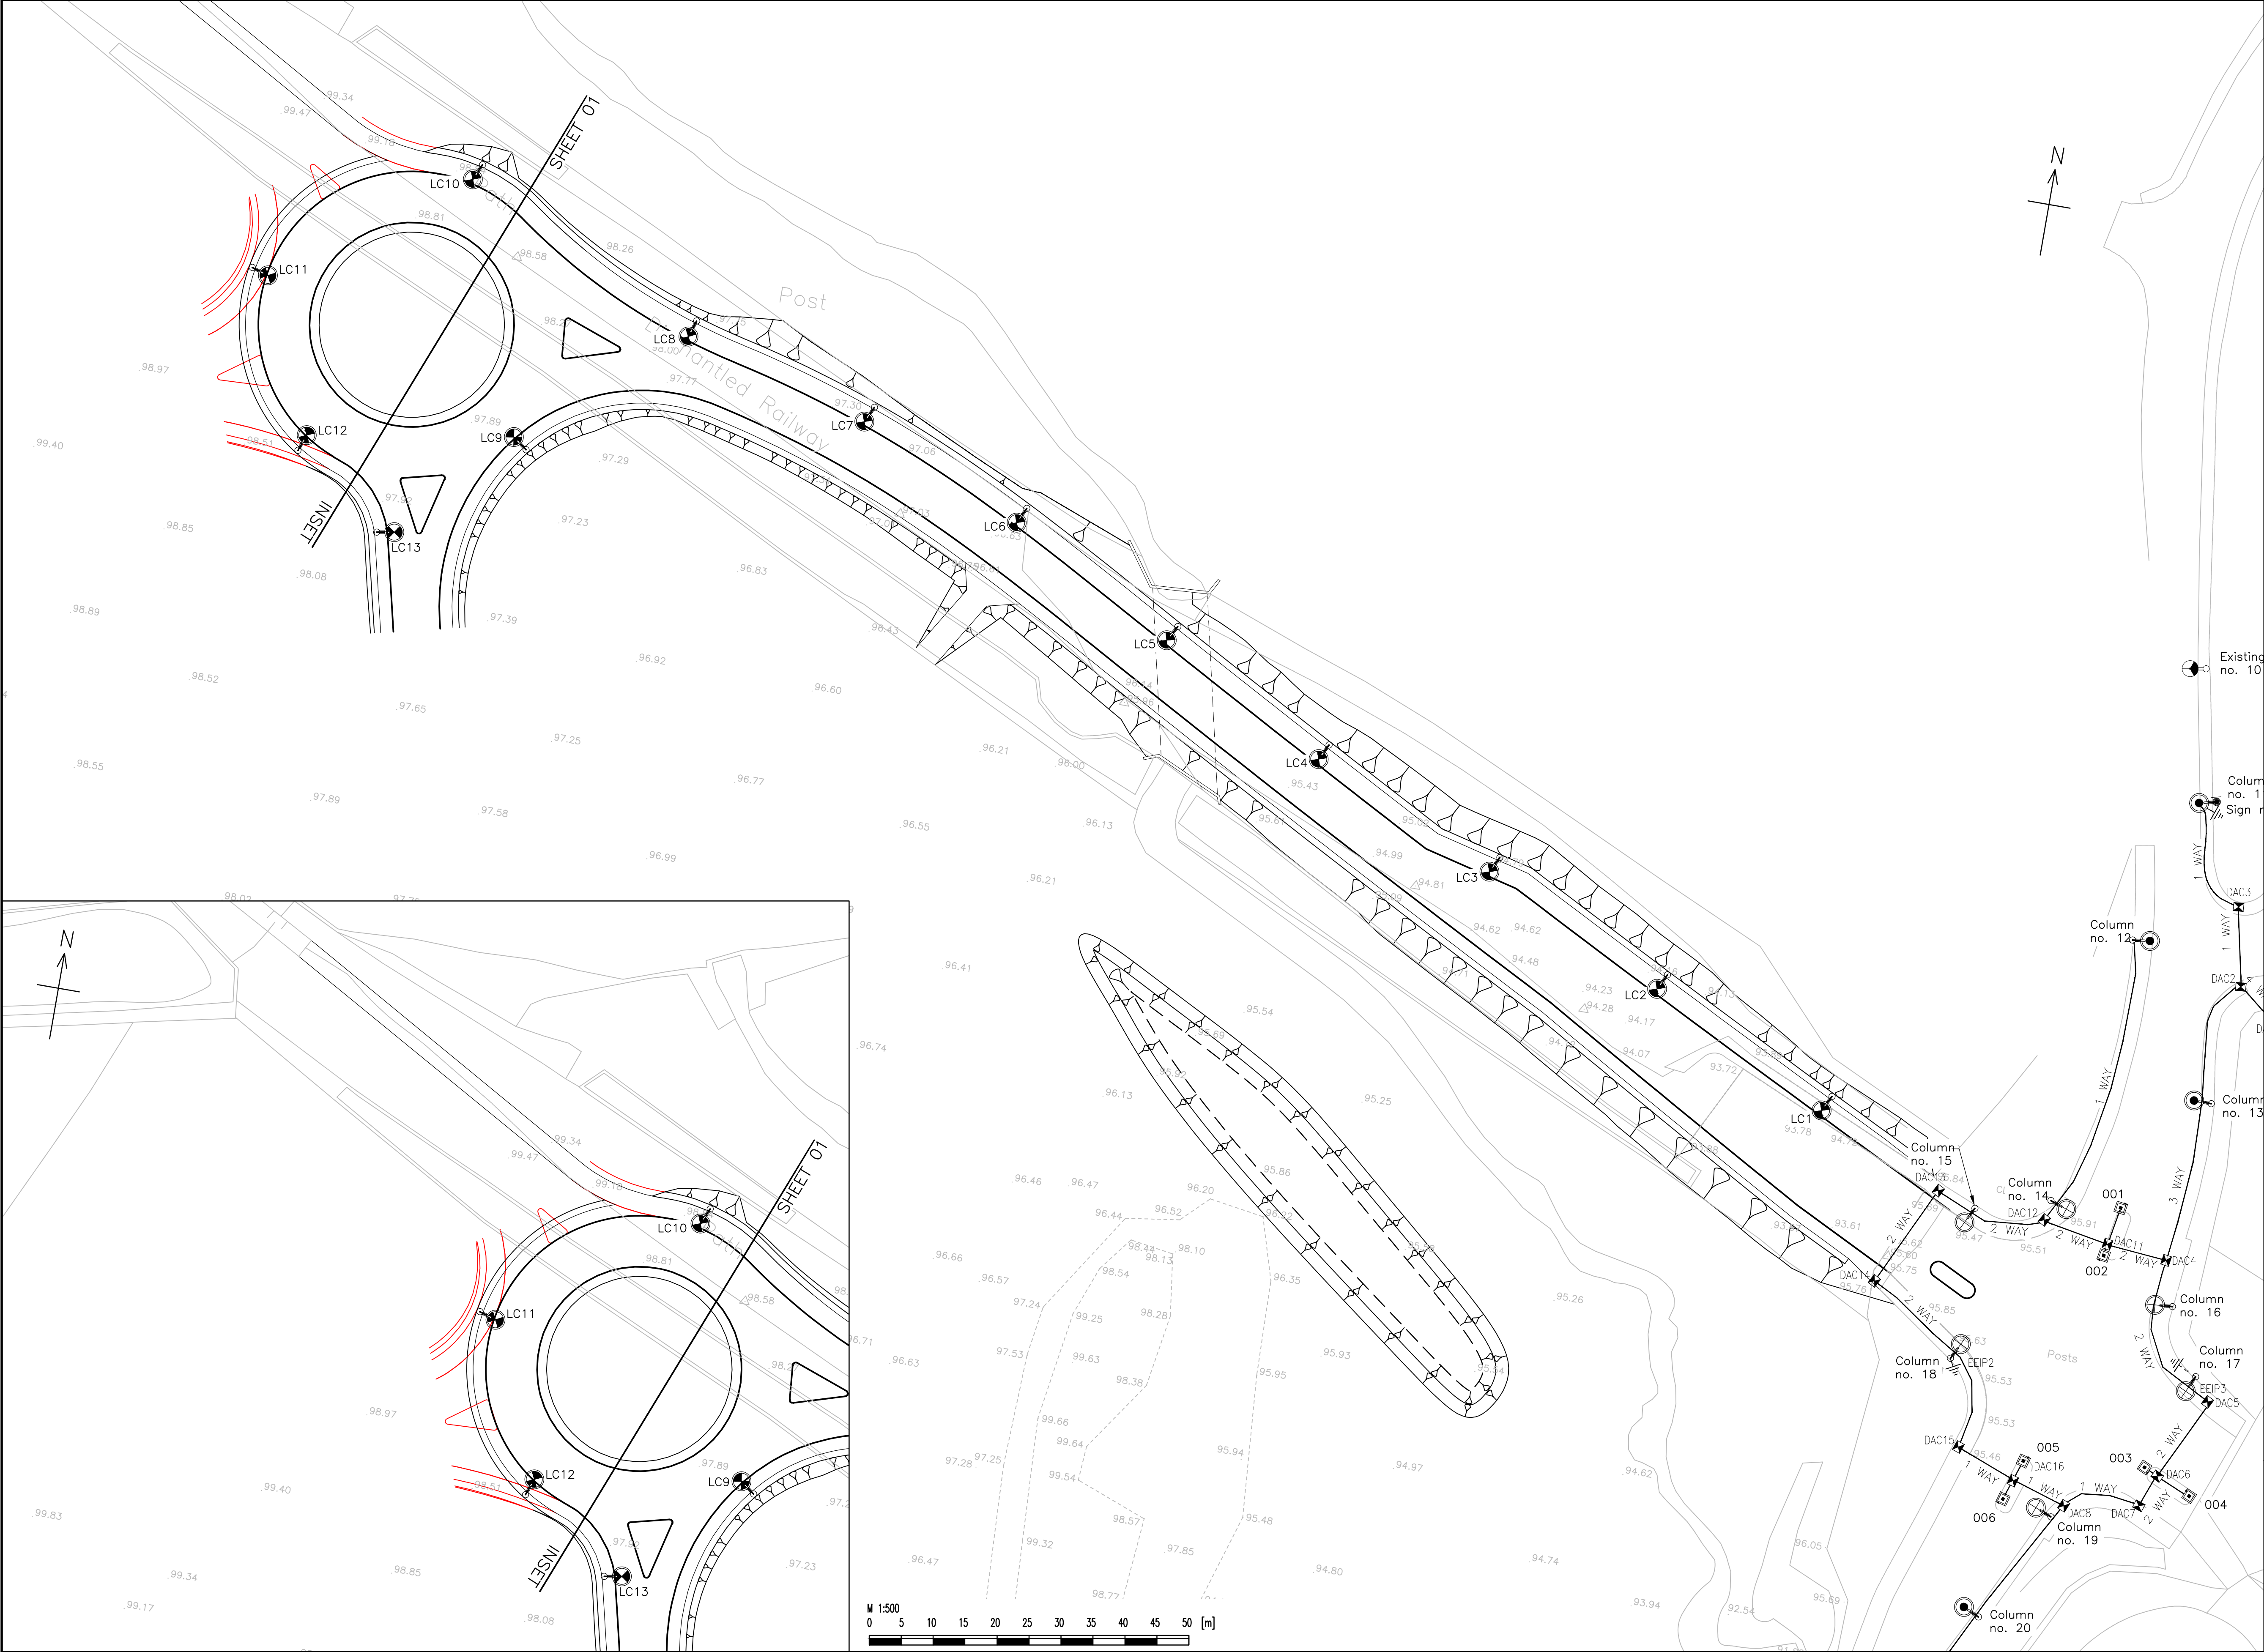

- NOTES**
1. This drawing should only be read in relation to the subject of the title. Other information shown on drawing is to be considered indicative only. Reference should be made to appropriate drawing series for other information.
 2. Do not scale from this drawing.
 3. If this drawing has been received electronically it is the recipients responsibility to print the drawing to the correct scale.
 4. For full notes, key, setting out information and performance quality figures refer to drawing 61033427-H-1300-00.

- KEY**
- Proposed lighting:
- Proposed galvanised steel road lighting column of 10m height with planted base and post top Philips luma 2 lantern (epic: Luma 2A RS_DS_NW 1 17000 NW LED) capable of delivering 17Klm. The bracket and lantern are angled at 0°. Maximum column spacing 34.5m single sided and 32m staggered.
- Existing lighting:
- Galvanised steel road lighting column of 10m height with planted base C/W post top lantern.
 - Galvanised steel road lighting column of 8m height with planted base C/W post top lantern.
 - Pre-existing lighting column.
 - Three phase feeder pillar.
 - Illuminated bollard.
 - Duct access chamber (DAC)
 - Earth electrode inspection pit (EPIP)
 - 100mm Orange street lighting duct.
 - DNO Distribution network operator electricity service.

B	SBO	LSS	MRD	11.08.14	FOR PLANNING
	SBO	LSS	MRD	05.08.14	FOR PLANNING
	SBO	LSS	MRD	27.06.14	PRELIMINARY
Rev.					Description
Scale (at A1)		Date	Drawn		
1:500		MAY 2014	AH		
Org. no.					Rev.
61033427-H-1300-01					B



Project

WREXHAM WESTERN GATEWAY



Drawing Title

WREXHAM GATEWAY STREET LIGHTING LAYOUT