




elite
systems

Bedford St. Westgate
Cleckheaton BD19 5EA
Tel. 01274 873232 Fax. 01274 877779
email: info@elitesystems.co.uk
www.elitesystems.co.uk
the possibilities are endless.....

Rev	Description	Date
A	Update to CJ email 20/10/21.	21/10/21
B	Updated to option 4	16/08/22
C	Updated to new layout	27/09/23

Building Specification:

PROJECT		
Rhostyllen		
TITLE		
M&E		
CLIENT		
Wrexham BC		
DRAWN BY JG	CHECKED BY	DATE 16/08/2022
SCALE (@ A1) 1:50	PROJECT NUMBER 200315	
DRAWING NUMBER 200315-ELT-00-00-DR-A-5000		REV C
STATUS: S2		
A=Approval P=Production T=Tender I=Information		

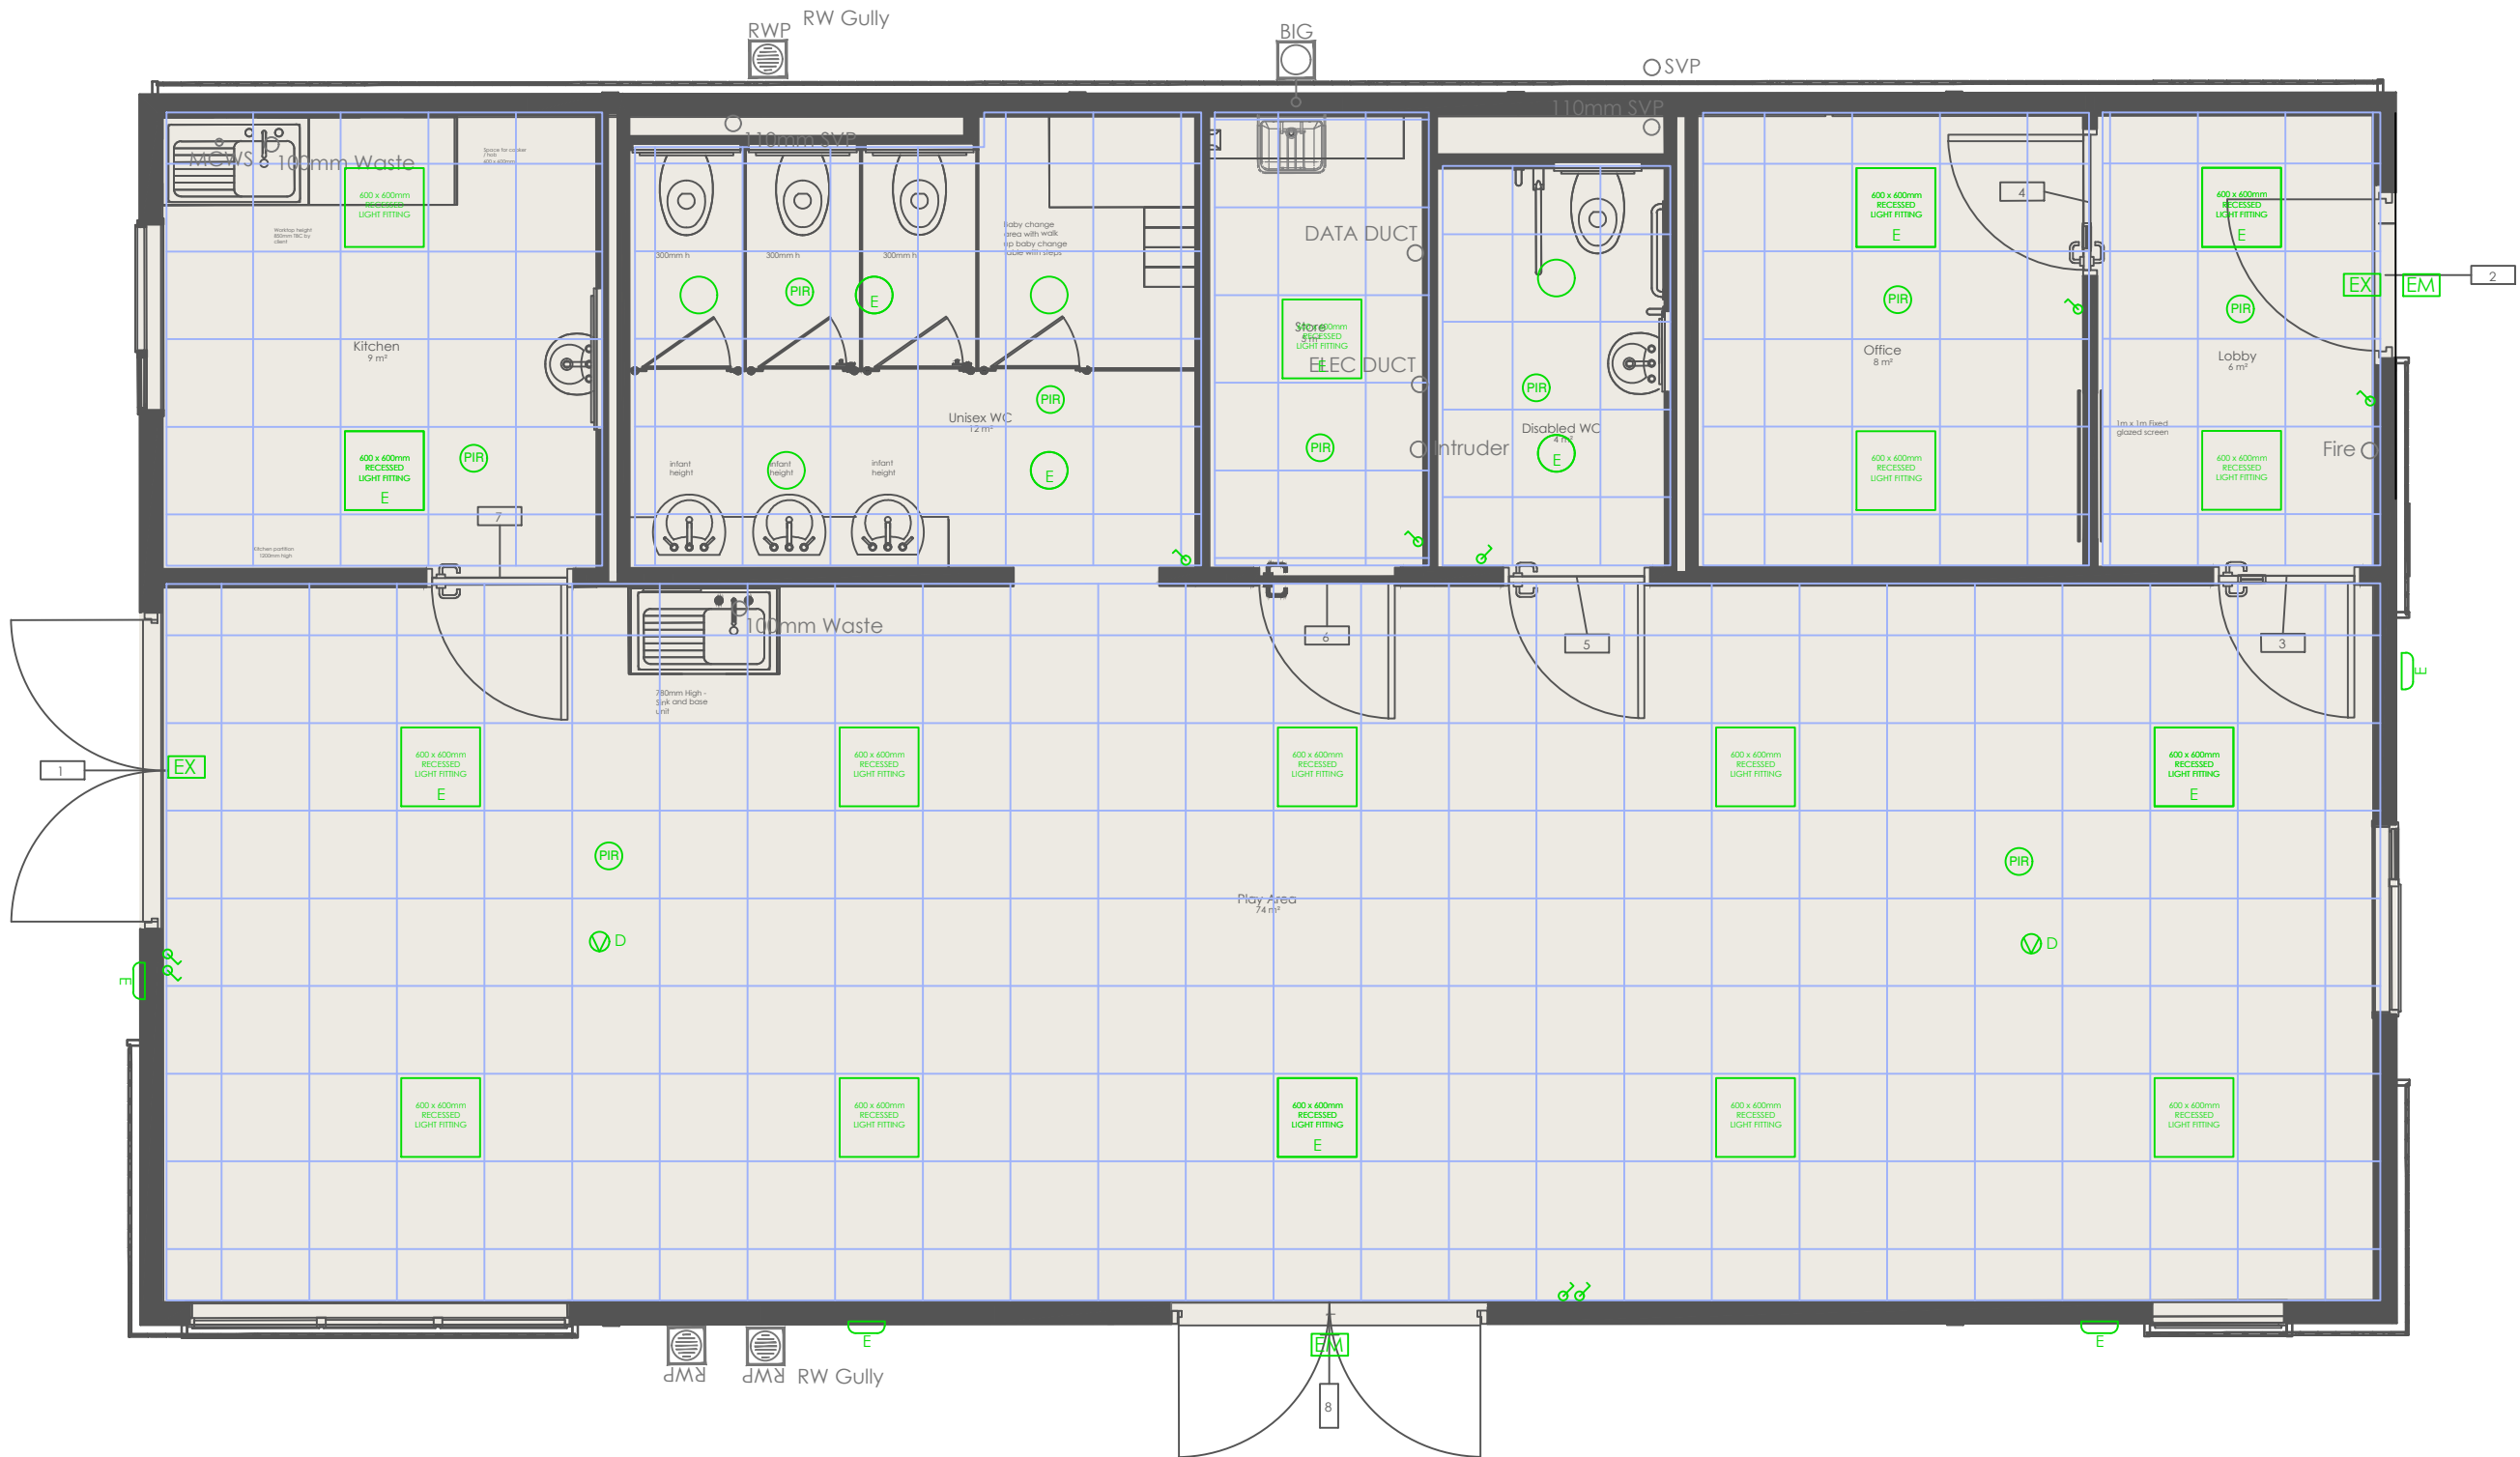

Rhostyllen Classroom
Lighting @ 1:50

LEGEND


- 600 x 600mm RECESSED LIGHT FITTING
- 600 x 600mm RECESSED LIGHT FITTING with integral emergency light
- XCDL LED Circular light
- XCDL LED Circular light with integral emergency light
- Non-maintained emergency exit sign.
- Non-maintained external emergency Light.
- Exterior Bulkhead LED Light fitting with integral emergency light
- Daylight dimming control
- PIR occupancy / absence sensor
- Light switch

ELECTRICAL LEGEND

- DDA Toilet Alarm
- Smoke Detectors
- Smoke Detectors - c/w sounder beacons
- Fire Alarm Call Point
- Fire Alarm Visual warning device
- Fire Alarm Panel
- Intruder alarm PIR Control
- Intruder Alarm Panel
- Door Contact
- Intruder Alarm External Sounder
- Remote keypad
- Data Point
- Telephone Point
- Data Panel
- Cooker circuit
- Dada trunking
- Switched double socket, Wall mounted
- Switched double socket, In trunking
- Switched double socket, Above worktop
- Emergency open button
- Door entry - Fob swipe reader
- Disabled Alarm Reset Button

MECHANICAL LEGEND

- Wall mounted hand dryer
- Whiterock cladding
- In-line 9.5kW Water Heater
- 3 kW 5-30L Storage Water Heater
- DAIKIN 600x600mm Recessed Air con unit FCQG-F
- Wall mount A/C
- Wall mounted A/C unit FTXS-F
- External A/C condensing unit
- 100mm extract fan, through wall
- 150mm extract fan, through wall
- Downflow Heater
- Co2 monitor
- Disabled W/C Beacon

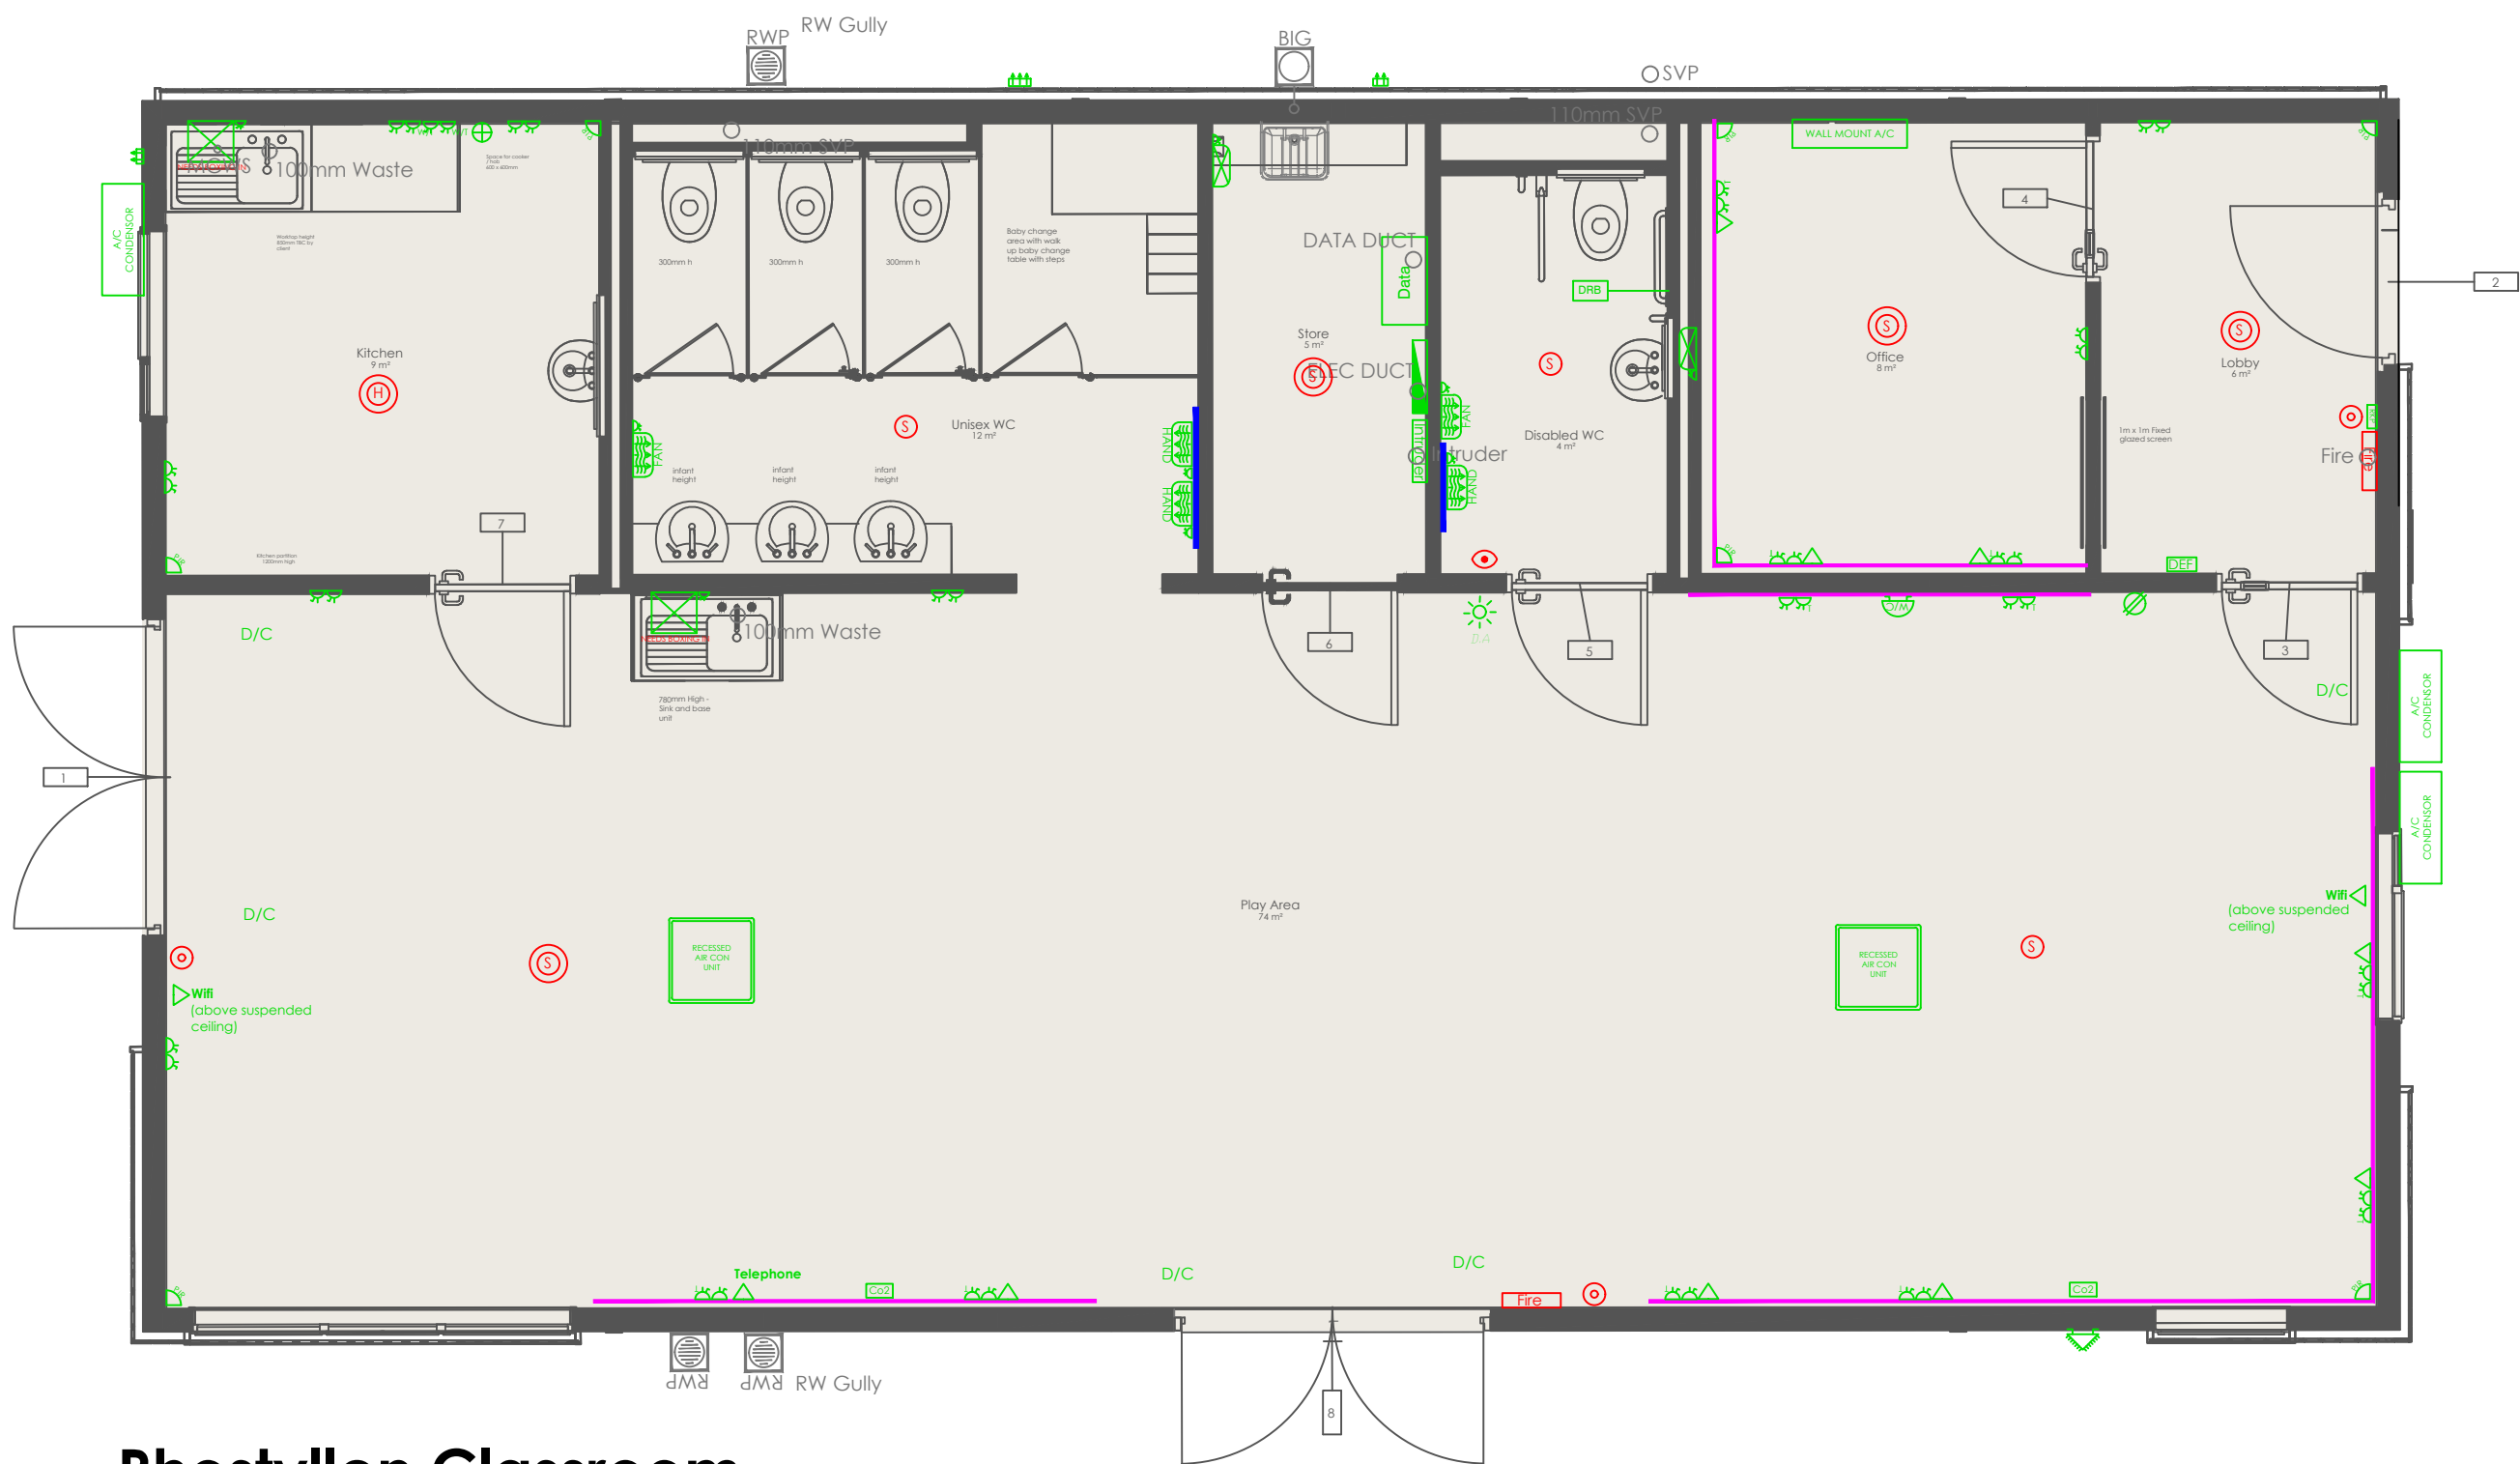

Rhostyllen Classroom
M&E @ 1:50